



EXISTING ELECTRICAL ONE—LINE DIAGRAM

SCALE: NTS

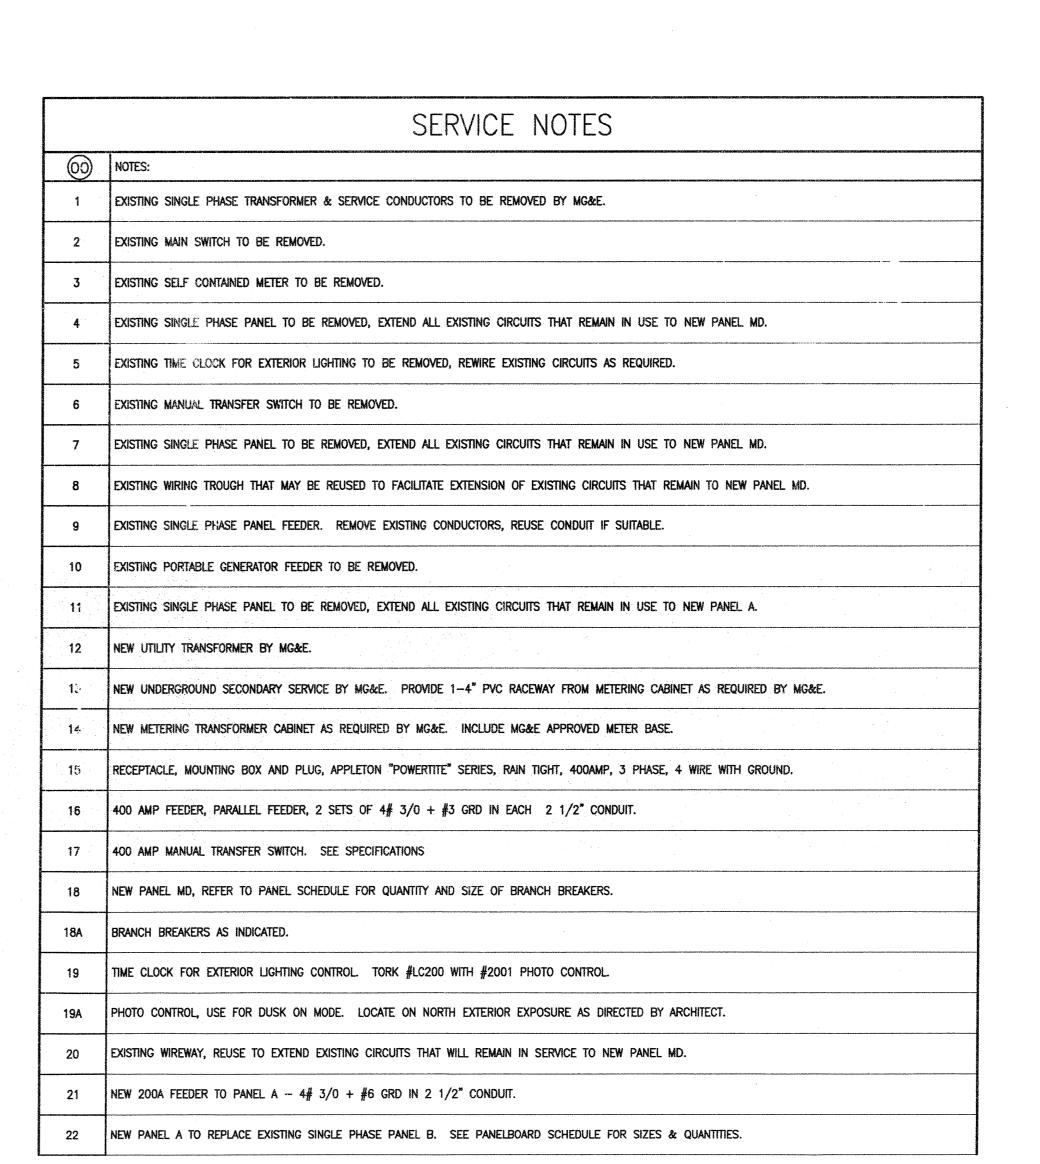

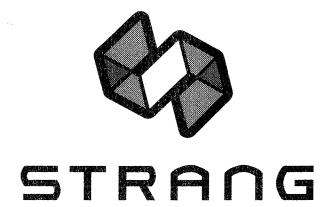

ARCHITECTURE ENGINEERING INTERIOR DESIGN

STRANG INC. 6411 MINERAL POINT ROAD MADISON, WI 53705-4395 T/ 608 276 9200 F/ 608 276 9204

COPYRIGHT STRANG, INC.	2012
FILE NAME	2011009-E601.DWG
REVISIONS	
DRAWN	KK
CHECKED	AS

DRAWING SET

PROJECT NO.

PROJECT TITLE

OWNER REVIEW

2011009

FIRE STATION #2 ADDITION AND REMODELING

ITY OF MADISON

421 GRAND CANYON DRIVE MADISON, WISCONSIN

SHEET TITLE

ELECTRICAL
ONE-LINE DIAGRAM
AND SCHEDULES

E601