



Madison, Wisconsin

CITY OF MADISON

CITY ENGINEERING DIVISION

DEPARTMENT OF PUBLIC WORKS

PLAN OF PROPOSED IMPROVEMENT

INDEX OF SHEETS


SHEET NO. C14-C18 UTILITY PLAN & PROFILES

3030 OHMEDA DRIVE CSM

CITY PROJECT NO. 13825

CONTRACT NO. 9802

PROJECT LOCATION

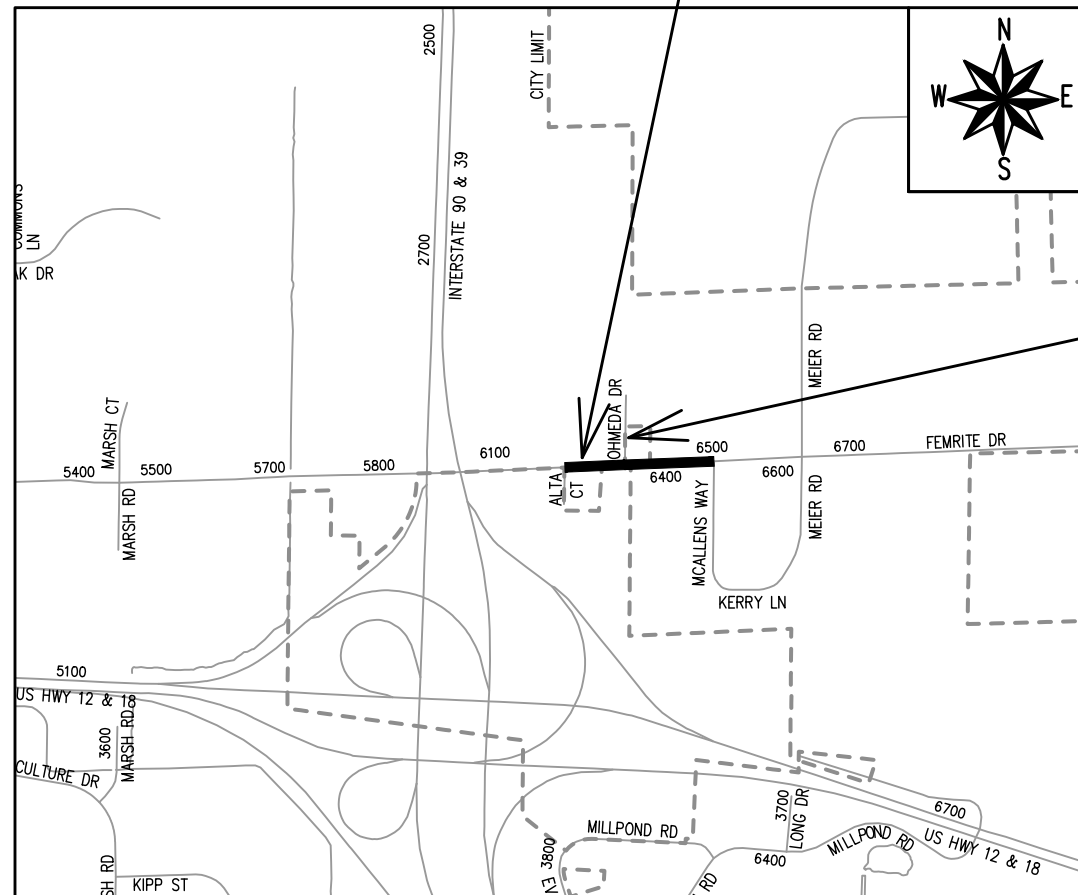

OHMEDA DRIVE STREET PLANS
(SEE PROJECT NO. 13810, CONTRACT NO. 8631)

PUBLIC IMPROVEMENT PROJECT
APPROVED

APPROVED DATE November 16, 2021

BY THE COMMON COUNCIL
OF MADISON, WISCONSIN

PUBLIC IMPROVEMENT DESIGN
APPROVED BY:

City Engineer

Date

SANITARY SEWER
DESIGNED BY:



CONVENTIONAL SIGNS FIELD VERIFY ALL UTILITY LOCATIONS

GAS	— G —
STORM SEWER	— ST —
SANITARY SEWER	— SN —
WATER	— W —
BURIED ELECTRIC	— E —
OVERHEAD ELECTRIC	— OH —
POWER POLE	
ADA COMPLIANT RAMP W/ DETECTABLE WARNING FIELD	
COMBUSTIBLE FLUIDS	

PLOT SCALE: 1 IN=1 FT_XREF



PLOT NAME: ---

REV. DATE: 9/1/2022 11:14 AM

ORIGINATOR: CITY OF MADISON

THESE PLANS AND DESIGNS ARE COPYRIGHT PROTECTED AND MAY NOT BE USED IN WHOLE OR IN PART WITHOUT THE WRITTEN CONSENT OF PINNACLE ENGINEERING GROUP, LLC

DRAFTED: MRG
DESIGNED: TOM
REVIEWED: TOM

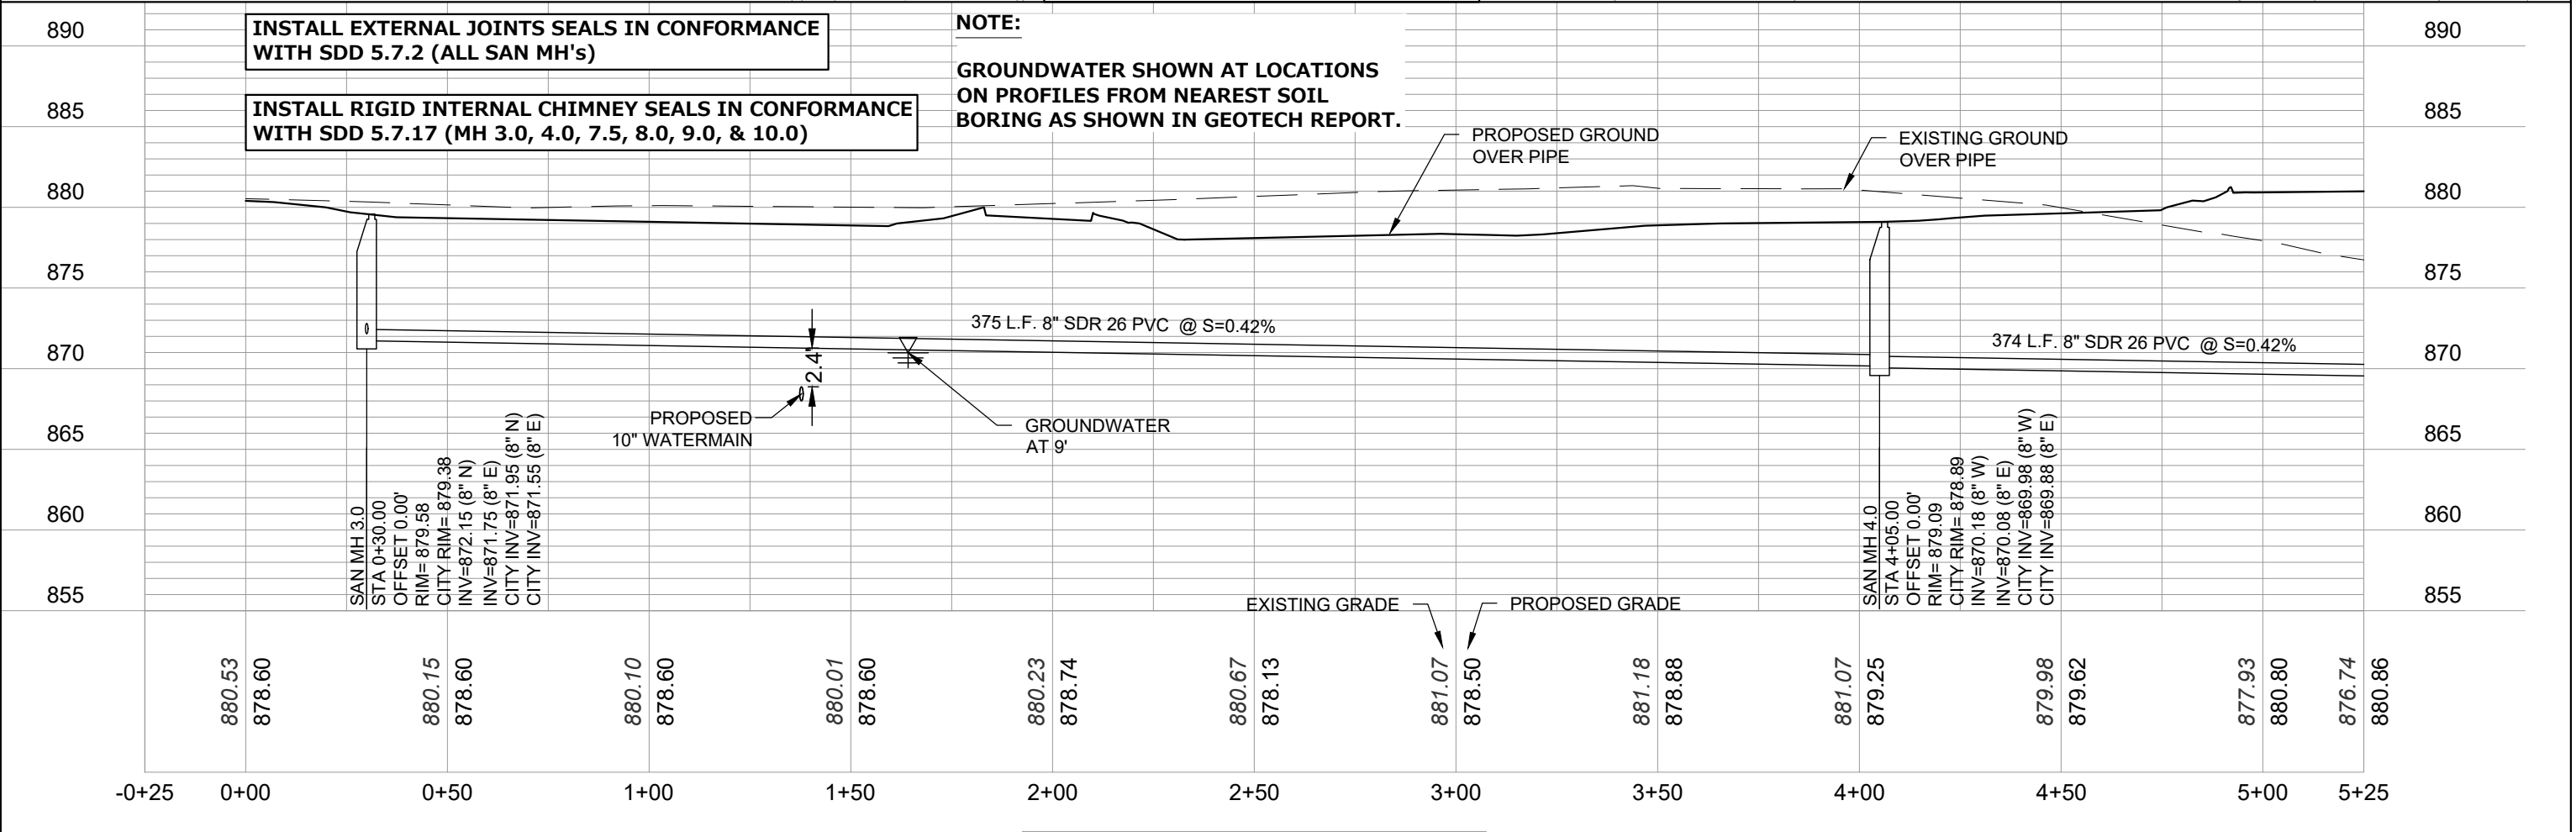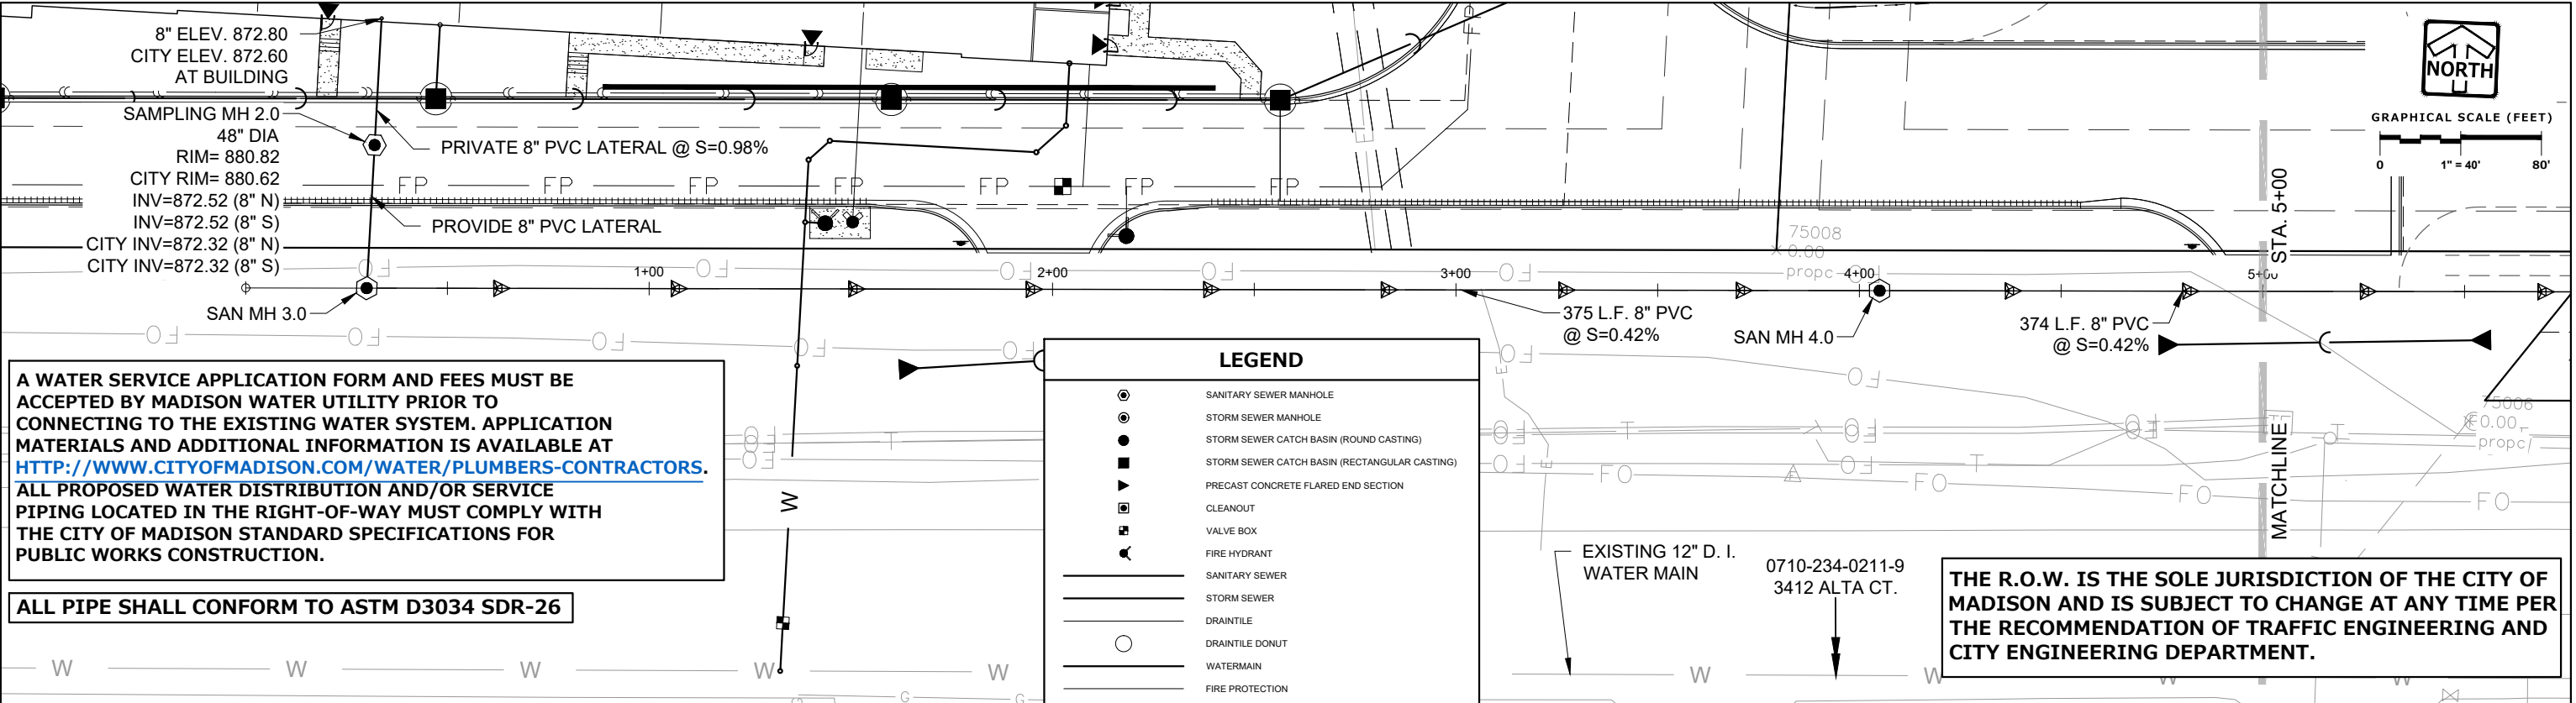

PINNACLE ENGINEERING GROUP
ENGINEERING | NATURAL RESOURCES | SURVEYING

PLAN | DESIGN | DELIVER
www.pinnacle-engr.com

WISCONSIN OFFICE:
20725 WATERTOWN ROAD, SUITE 100
BROOKFIELD, WI 53186
(262) 754-6888

CHICAGO | MILWAUKEE | NATIONWIDE

3030 OHMEDA DRIVE CSM

MADISON, WISCONSIN

UTILITY PLAN

REVISIONS

1	CITY REVISIONS	12/08/22
2	ADD CITY DATUM INVERTS	01/20/23
3	SANITARY REALIGNMENT	05/09/23

PEG JOB No. 1933.00
PEG PM AREA
START DATE 08/05/20
SCALE 1" = 40'



SHEET C-14 C-29

THESE PLANS AND DESIGNS ARE COPYRIGHT PROTECTED AND MAY NOT BE USED IN WHOLE OR IN PART WITHOUT THE WRITTEN CONSENT OF PINNACLE ENGINEERING GROUP, LLC

DESIGNED: TGM

REVIEWED: TGM

DRAFTED: MRG

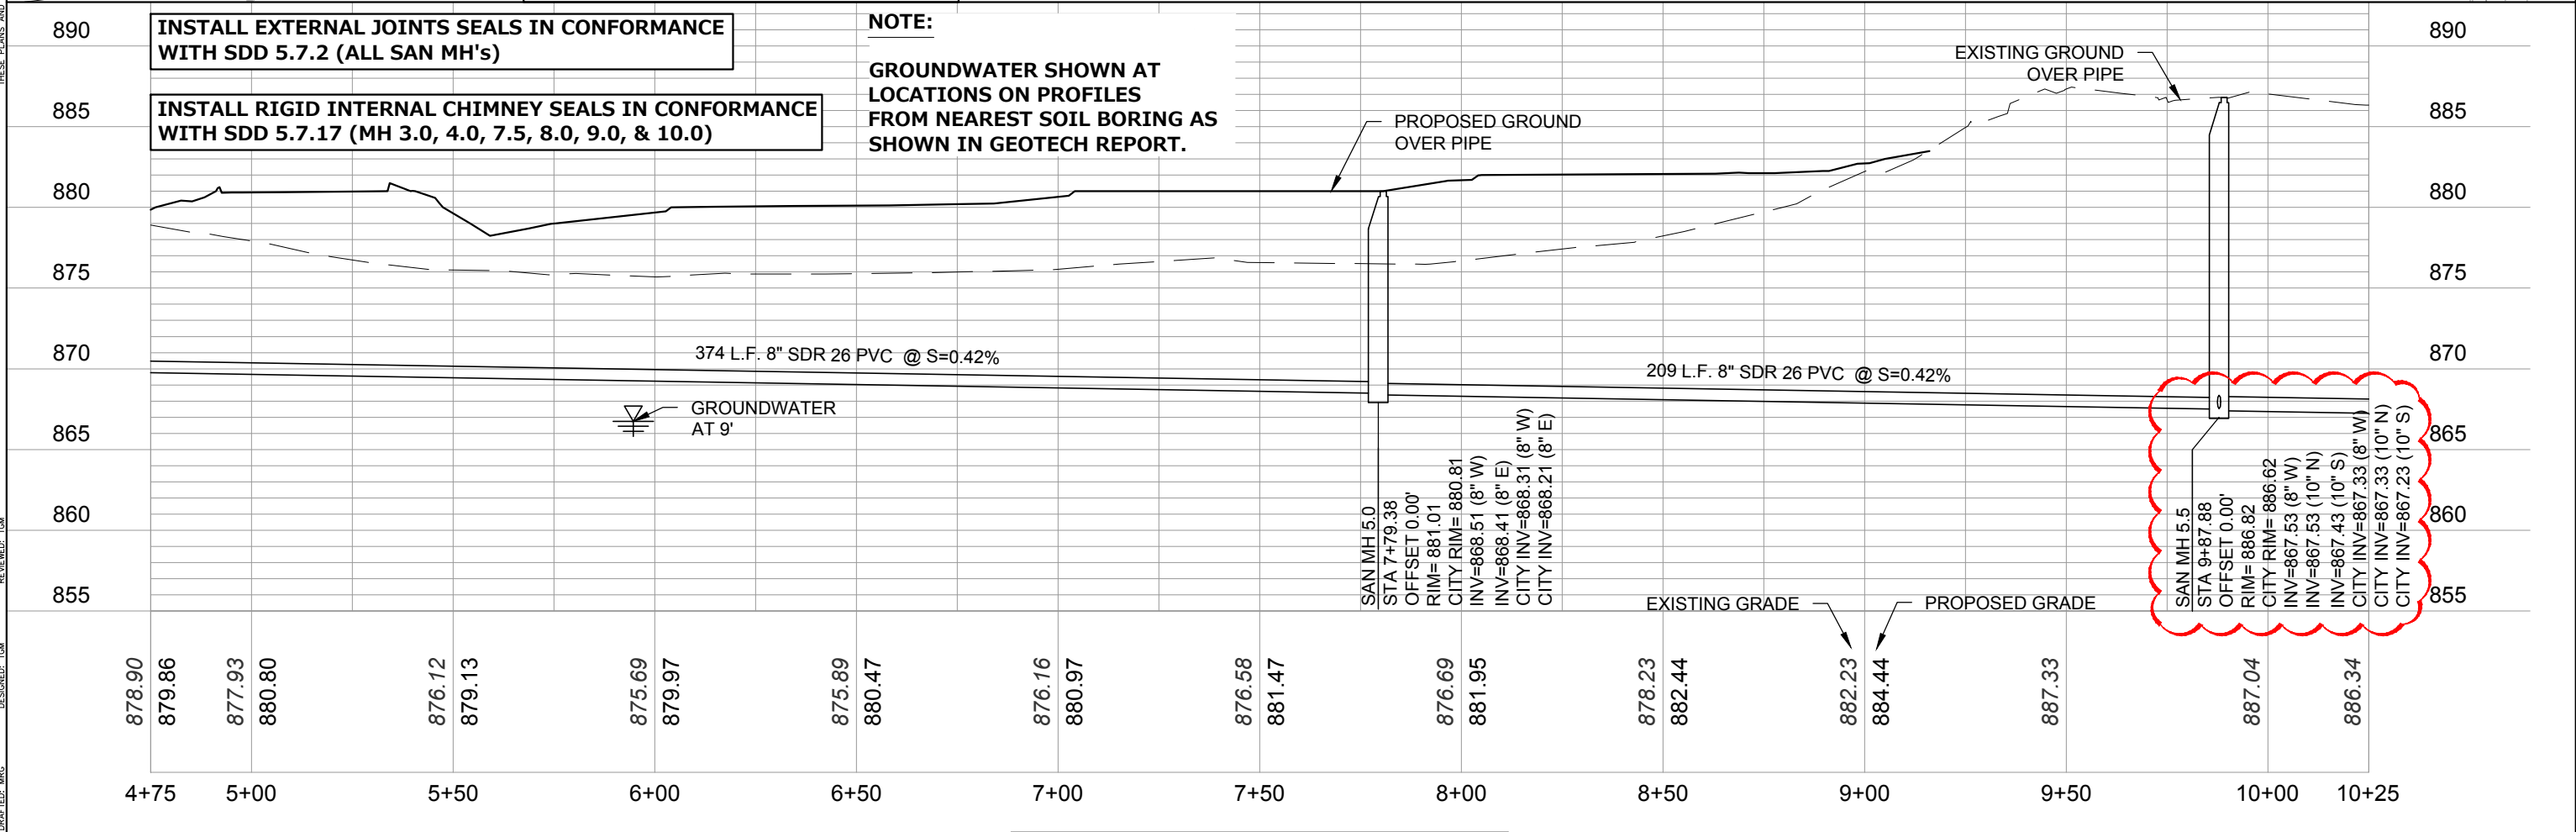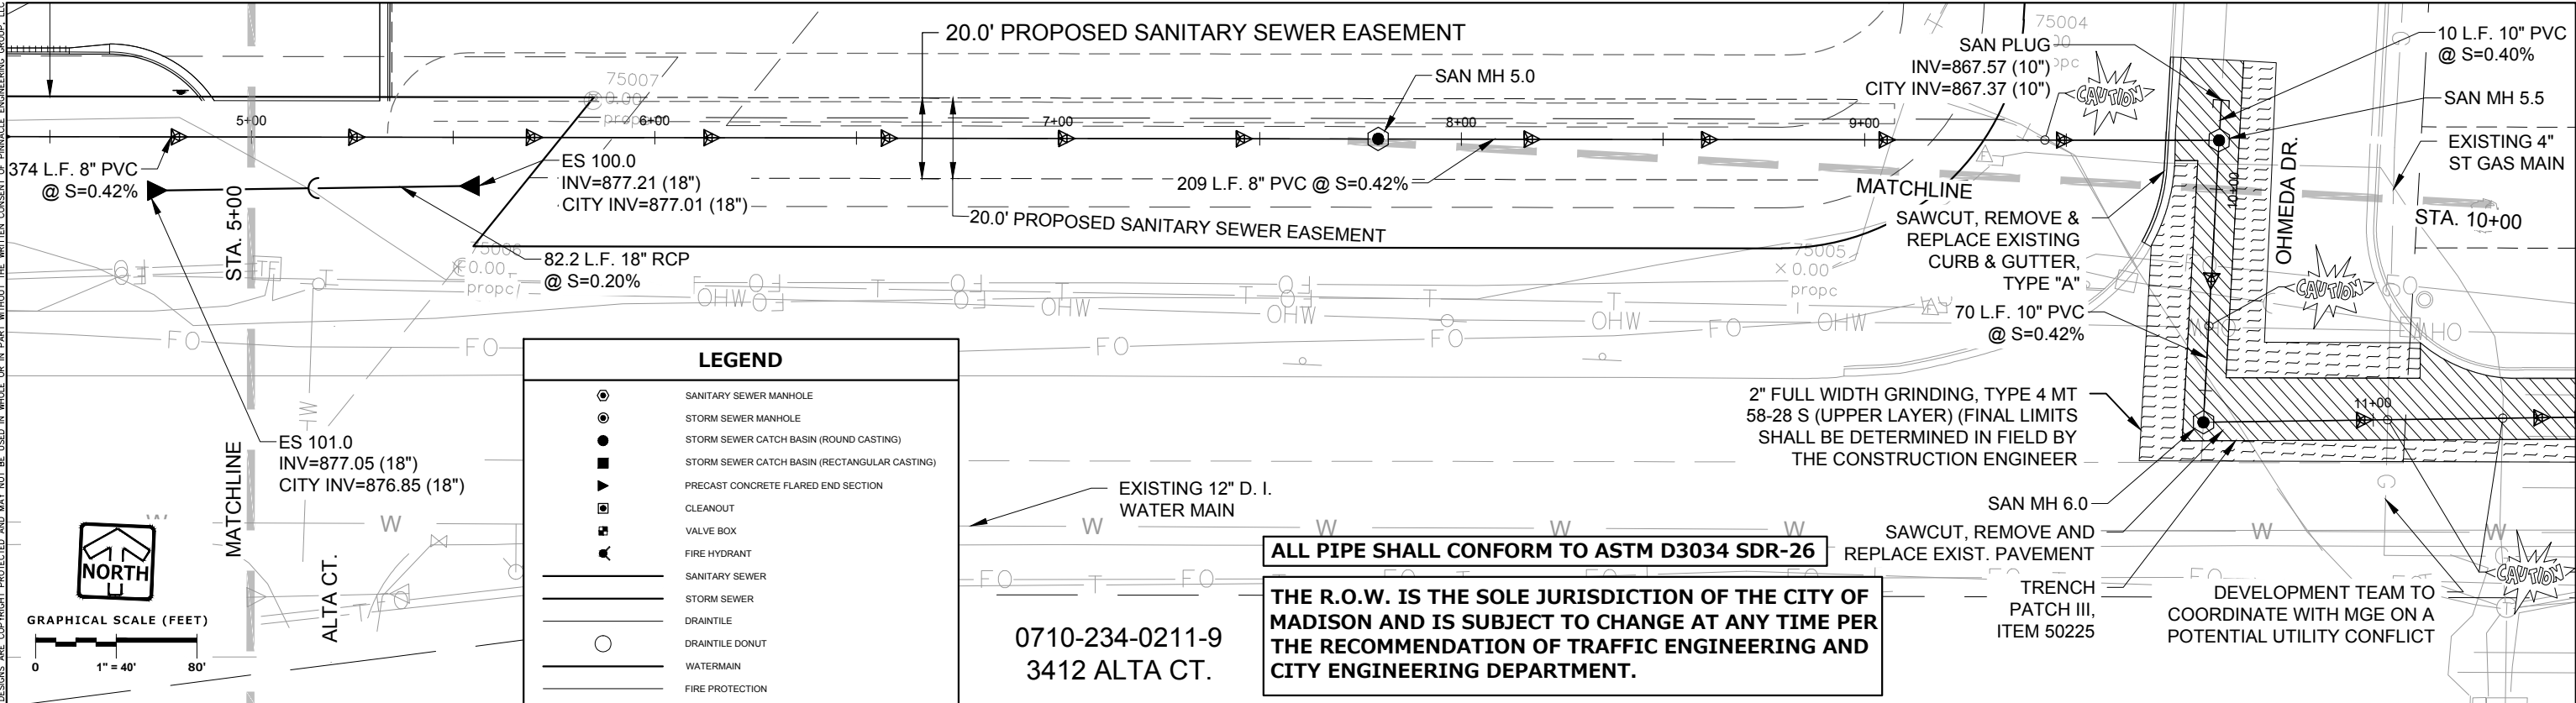

PINNACLE ENGINEERING GROUP
ENGINEERING | NATURAL RESOURCES | SURVEYING

WISCONSIN OFFICE:
20725 WATERTOWN ROAD, SUITE 100
BROOKFIELD, WI 53186
(262) 754-6888
CHICAGO | MILWAUKEE | NATIONWIDE

PLAN | DESIGN | DELIVER
www.pinnacle-engr.com

3030 OHMEDA DRIVE CSM

MADISON, WISCONSIN

UTILITY PLAN

REVISIONS

1	CITY REVISIONS	12/08/22
2	ADD CITY DATUM INVERTS	01/20/23
3	SANITARY REALIGNMENT	05/09/23

PEG JOB No. 1933.00

PEG PIN AREA

START DATE 08/05/20


SCALE 1" = 40'

SHEET **C-15**
C-29

© COPYRIGHT 2019

THESE PLANS AND DESIGNS ARE COPYRIGHT PROTECTED AND MAY NOT BE USED IN WHOLE OR IN PART WITHOUT THE WRITTEN CONSENT OF PINNACLE ENGINEERING GROUP, LLC

DESIGNED: TGM
DRAFTED: MRG
REVIEWED: TGM

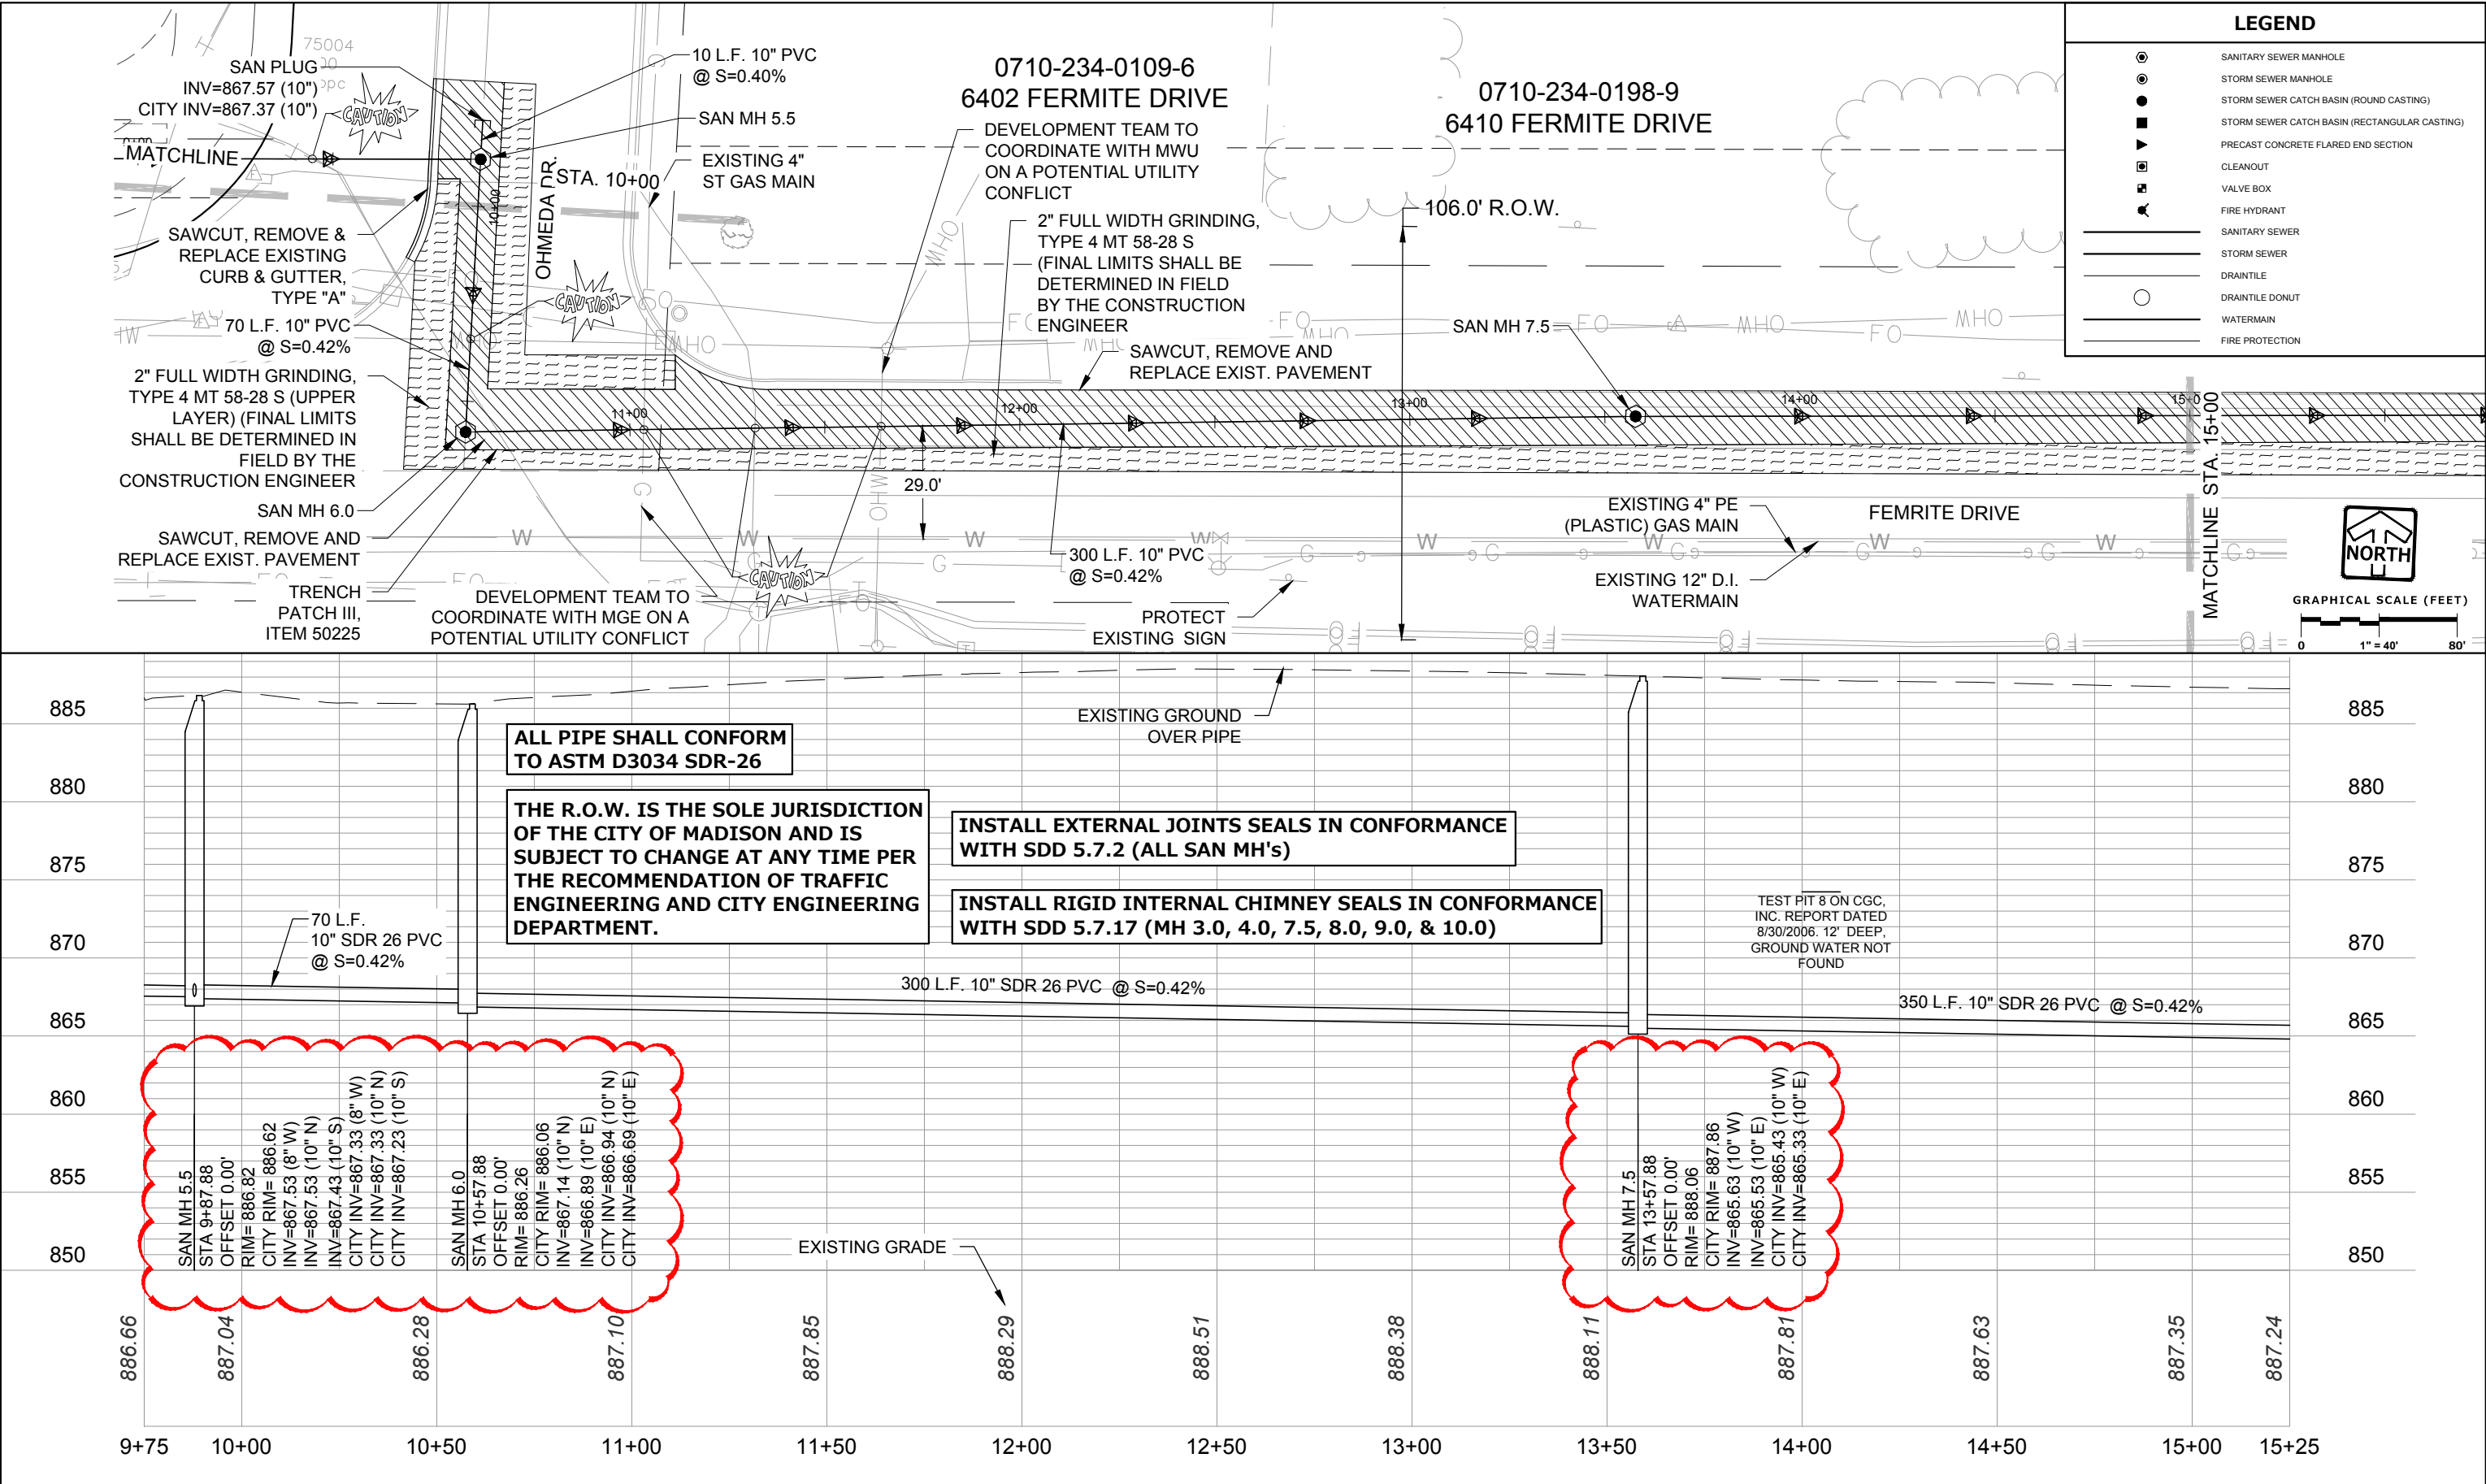

PINNACLE ENGINEERING GROUP
ENGINEERING | NATURAL RESOURCES | SURVEYING

WISCONSIN OFFICE:
20725 WATERTOWN ROAD, SUITE 100
BROOKFIELD, WI 53186
(262) 754-8888

CHICAGO | MILWAUKEE | NATIONWIDE

PLAN | DESIGN | DELIVER
www.pinnacle-engr.com

3030 OHMEDA DRIVE CSM

MADISON, WISCONSIN

UTILITY PLAN

REVISIONS

1	CITY REVISIONS	12/08/22
2	ADD CITY DATUM INVERTS	01/20/23
3	SANITARY REALIGNMENT	05/09/23

PEG JOB No. 1933.00

PEG PM AREA

START DATE 08/05/20

SCALE 1" = 40'

SHEET C-16 C-29

© COPYRIGHT 2019



