


CHARTER STREET REBUILD

UNIVERSITY OF WISCONSIN

DAYTON STREET BUILDING SIP-01

DSF# 092AL

SIP DRAWING LIST		
ISSUANCE 1	Sheet Number	Sheet Name
5.24.10	CD001	COVER DRAWING
5.24.10	CD002	SITE CONTEXT
5.24.10	C000	COVER SHEET
5.24.10	C001	SITE PLAN
5.24.10	C060	TRUCK AUTOTURN EXHIBIT MAXIMUM MAINTENANCE TRUCK
5.24.10	C061	TRUCK AUTOTURN EXHIBIT ANTICIPATED MAINTENANCE TRUCK
5.24.10	C201	DEMOLITION PLAN
5.24.10	C301	UNDERGROUND UTILITIES PLAN
5.24.10	C330	TYPICAL U/G UTILITY AND SEWER SECTIONS
5.24.10	C350	TYPICAL U/G UTILITY AND SEWER DETAILS
5.24.10	C401	FIRE WATER PLAN
5.24.10	C501	GRADING AND DRAINAGE PLAN
5.24.10	L001	LANDSCAPE PLAN
5.24.10	L010	LANDSCAPE DETAILS
5.24.10	A100	SITE REFERENCE PLAN
5.24.10	A101	BASEMENT FLOOR PLAN
5.24.10	A102	FIRST FLOOR PLAN
5.24.10	A103	SECOND FLOOR PLAN
5.24.10	A104	ROOF PLANS
5.24.10	A201	BUILDING ELEVATIONS
5.24.10	A202	BUILDING ELEVATIONS
5.24.10	A213	EXTERIOR RENDERINGS
5.24.10	A214	EXTERIOR RENDERINGS
5.24.10	A301	BUILDING SECTIONS
5.24.10	A302	BUILDING SECTIONS
5.24.10	A303	BUILDING SECTIONS
5.24.10	A311	WALL SECTIONS
5.24.10	E100	EXTERIOR LIGHTING PLAN
5.24.10	E400	DAYTON STREET BUILDING LUMINAIRE SCHEDULE, LEGEND AND ABBREVIATIONS
ADDITIONAL ATTACHMENTS: LUMINAIRE CUT SHEETS BOILER GENERAL ARRANGMENT DRAWING		

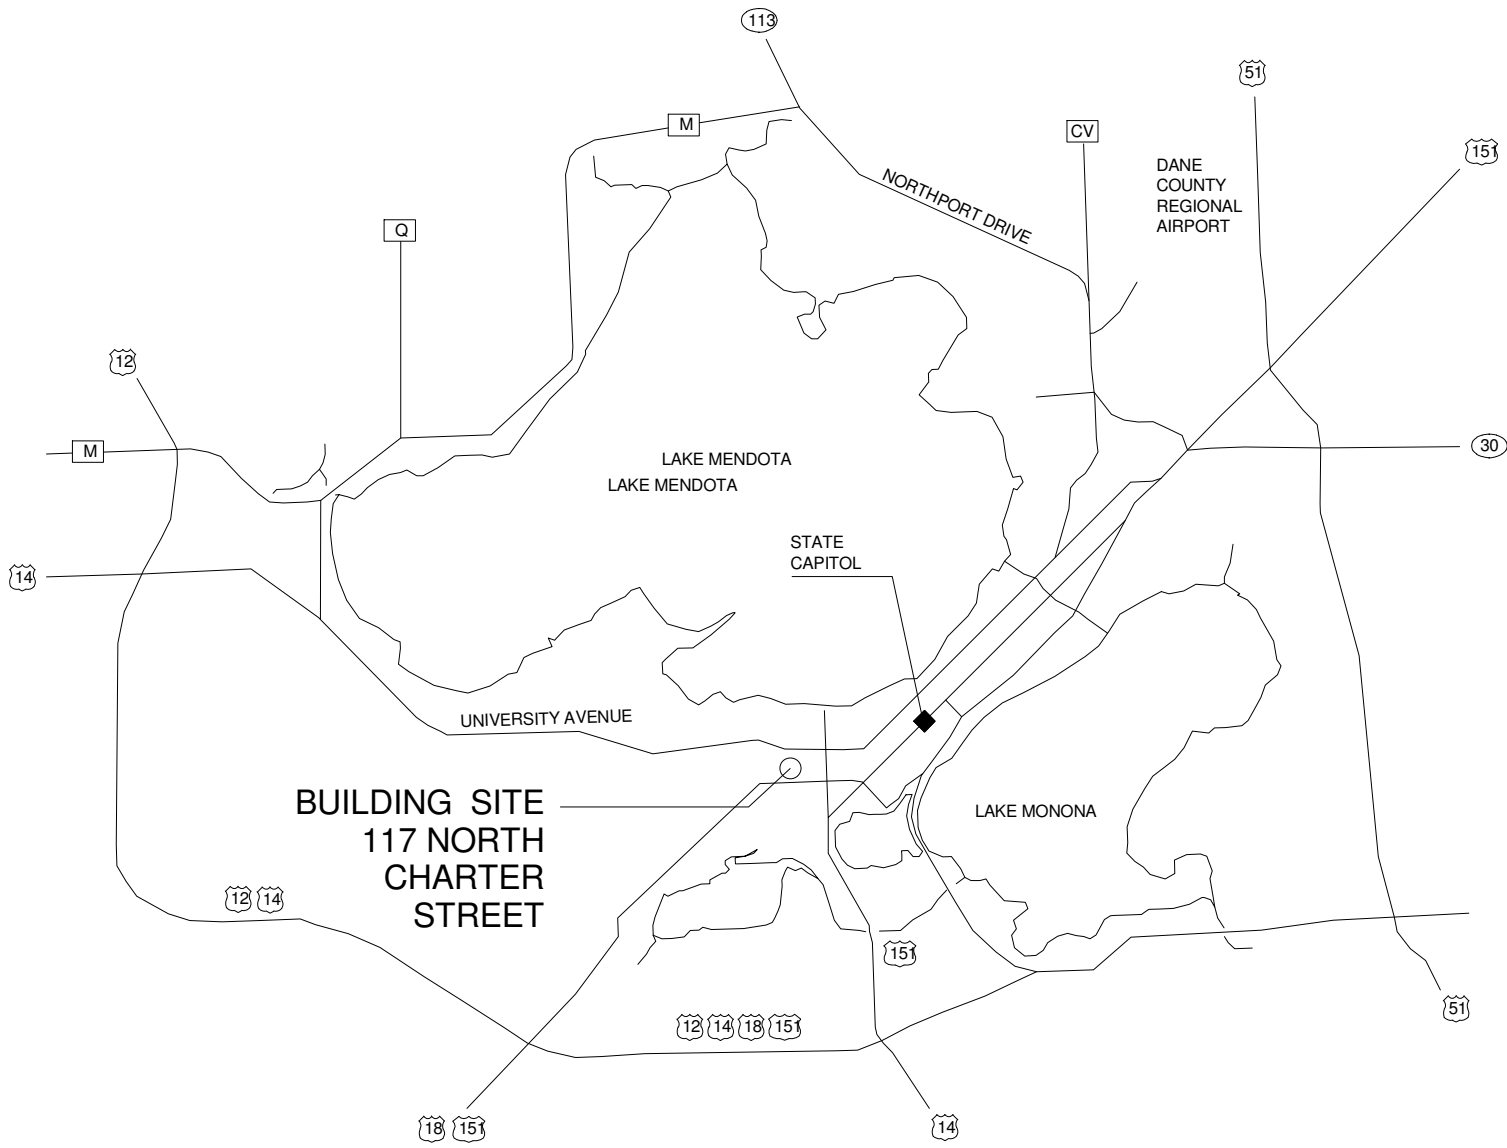

DAYTON STREET BUILDING

117 NORTH CHARTER STREET

MADISON, WI

PEC

POWER ENGINEERS
COLLABORATIVE LLC

150 Sunny Slope Road
Suite 110
Brookfield, Wisconsin 53005
WWW.PECLLC.COM

PÖYRY


POWER ARCHITECTS
ARCHITECTS WISCONSIN

middough

Potter Lawson

PLI Project No:
2009.07.00

State of Wisconsin
Department of Administration
Division of State Facilities

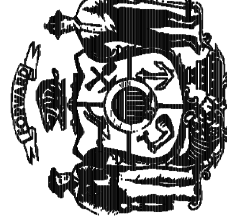
Agency / Institution:
UNIVERSITY OF WISCONSIN SYSTEM

CHARTER STREET REBUILD

Project Location:
MADISON, WI

Sheet Title:
COVER DRAWING

Revisions:

No.	Date:	By:	Description:

Graphic Scale

DSF Number
09A2L

Set Type
PR

Date Issued
05-24-10

Sheet Number
CD001



1



2



3



4



5



6



7



8



9



10





11



12



13

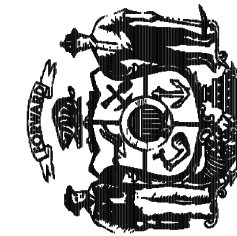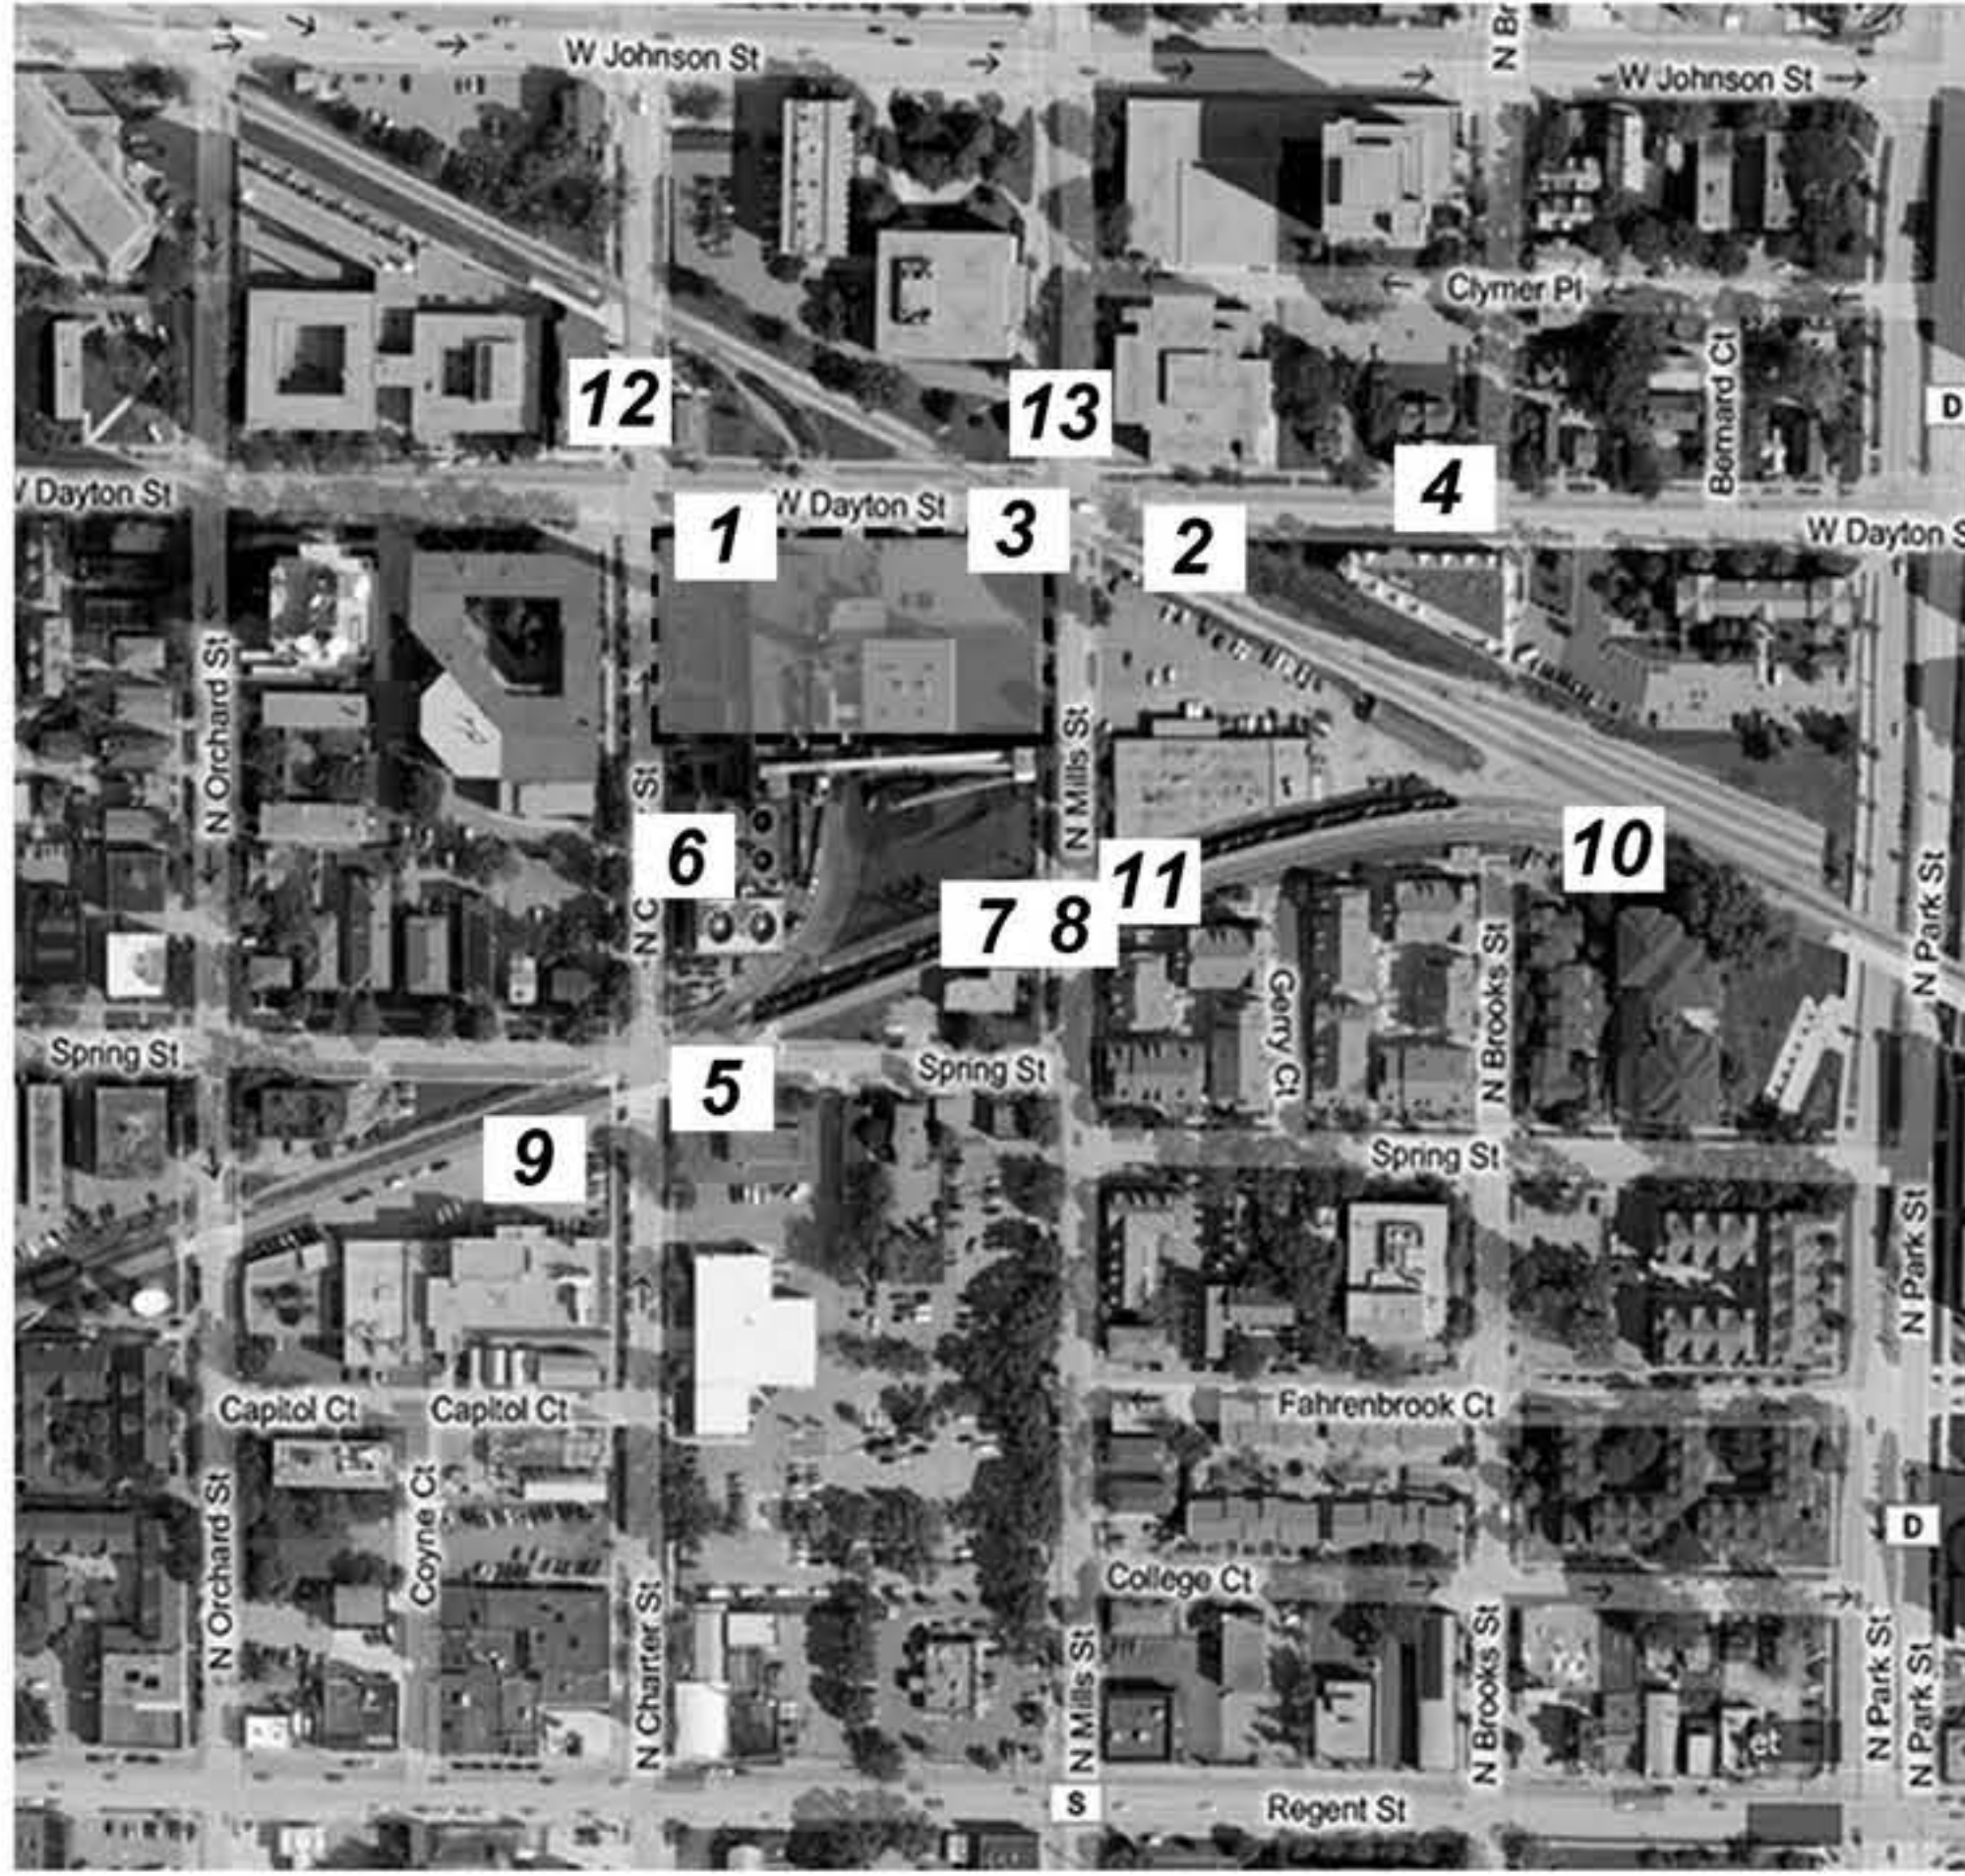

Revisions:			
No.	Date:	By:	Description:

Graphic Scale	
DSF Number	09A2L
Set Type	PR
Date Issued	05-24-10
Sheet Number	CD002

GENERAL NOTES

UTILITIES AS SHOWN ARE APPROXIMATE AND ARE BASED ON DIGGERS HOTLINE. MARKOUTS PER TICKET NUMBER 20092910251, OBSERVED EVIDENCE AND RECORD DRAWINGS PROVIDED BY UTILITY COMPANIES.

HORIZONTAL CONTROL AND BEARINGS ARE REFERENCED TO UW-MADISON CONTROL MONUMENTS #4 AND #3 ON THE WISCONSIN COUNTY COORDINATE SYSTEM, DANE COUNTY ZONE.

VERTICAL CONTROL BASED ON UW-MADISON CONTROL MONUMENTS #3, #4 AND #10 ON NAVD88 DATUM.


PROJECT LIMITS LIE OUTSIDE THE 100 YEAR FLOODPLAIN PER FEMA FLOOD INSURANCE RATE MAP 55025C0408G AND 55025C0409G DATED JANUARY 2, 2009.

FIELD SURVEY DATA ACQUIRED JULY AND AUGUST 2009 BY AYERES ASSOCIATES.


EXIST. RAILROAD RAILS ARE 112# & 115# ALONG MAIN LINE BETWEEN W. WASHINGTON AVE. AND CHARTER ST.; 80-85# ALONG SPUR BETWEEN RANDALL AVE. AND FIRST SWITCH TO THE NORTHEAST; 90# FROM SAID SWITCH NORTHEAST TO MAIN LINE. ALL NEW RAIL SHALL BE 115#.

STATIONING ON PLAN (NOT INCLUDED WITH THIS SIP)S REFERENCES THE DANE COUNTY COORDINATE SYSTEM. PROFILE REPRESENTS TOP OF RAIL.

SHEET LAYOUT

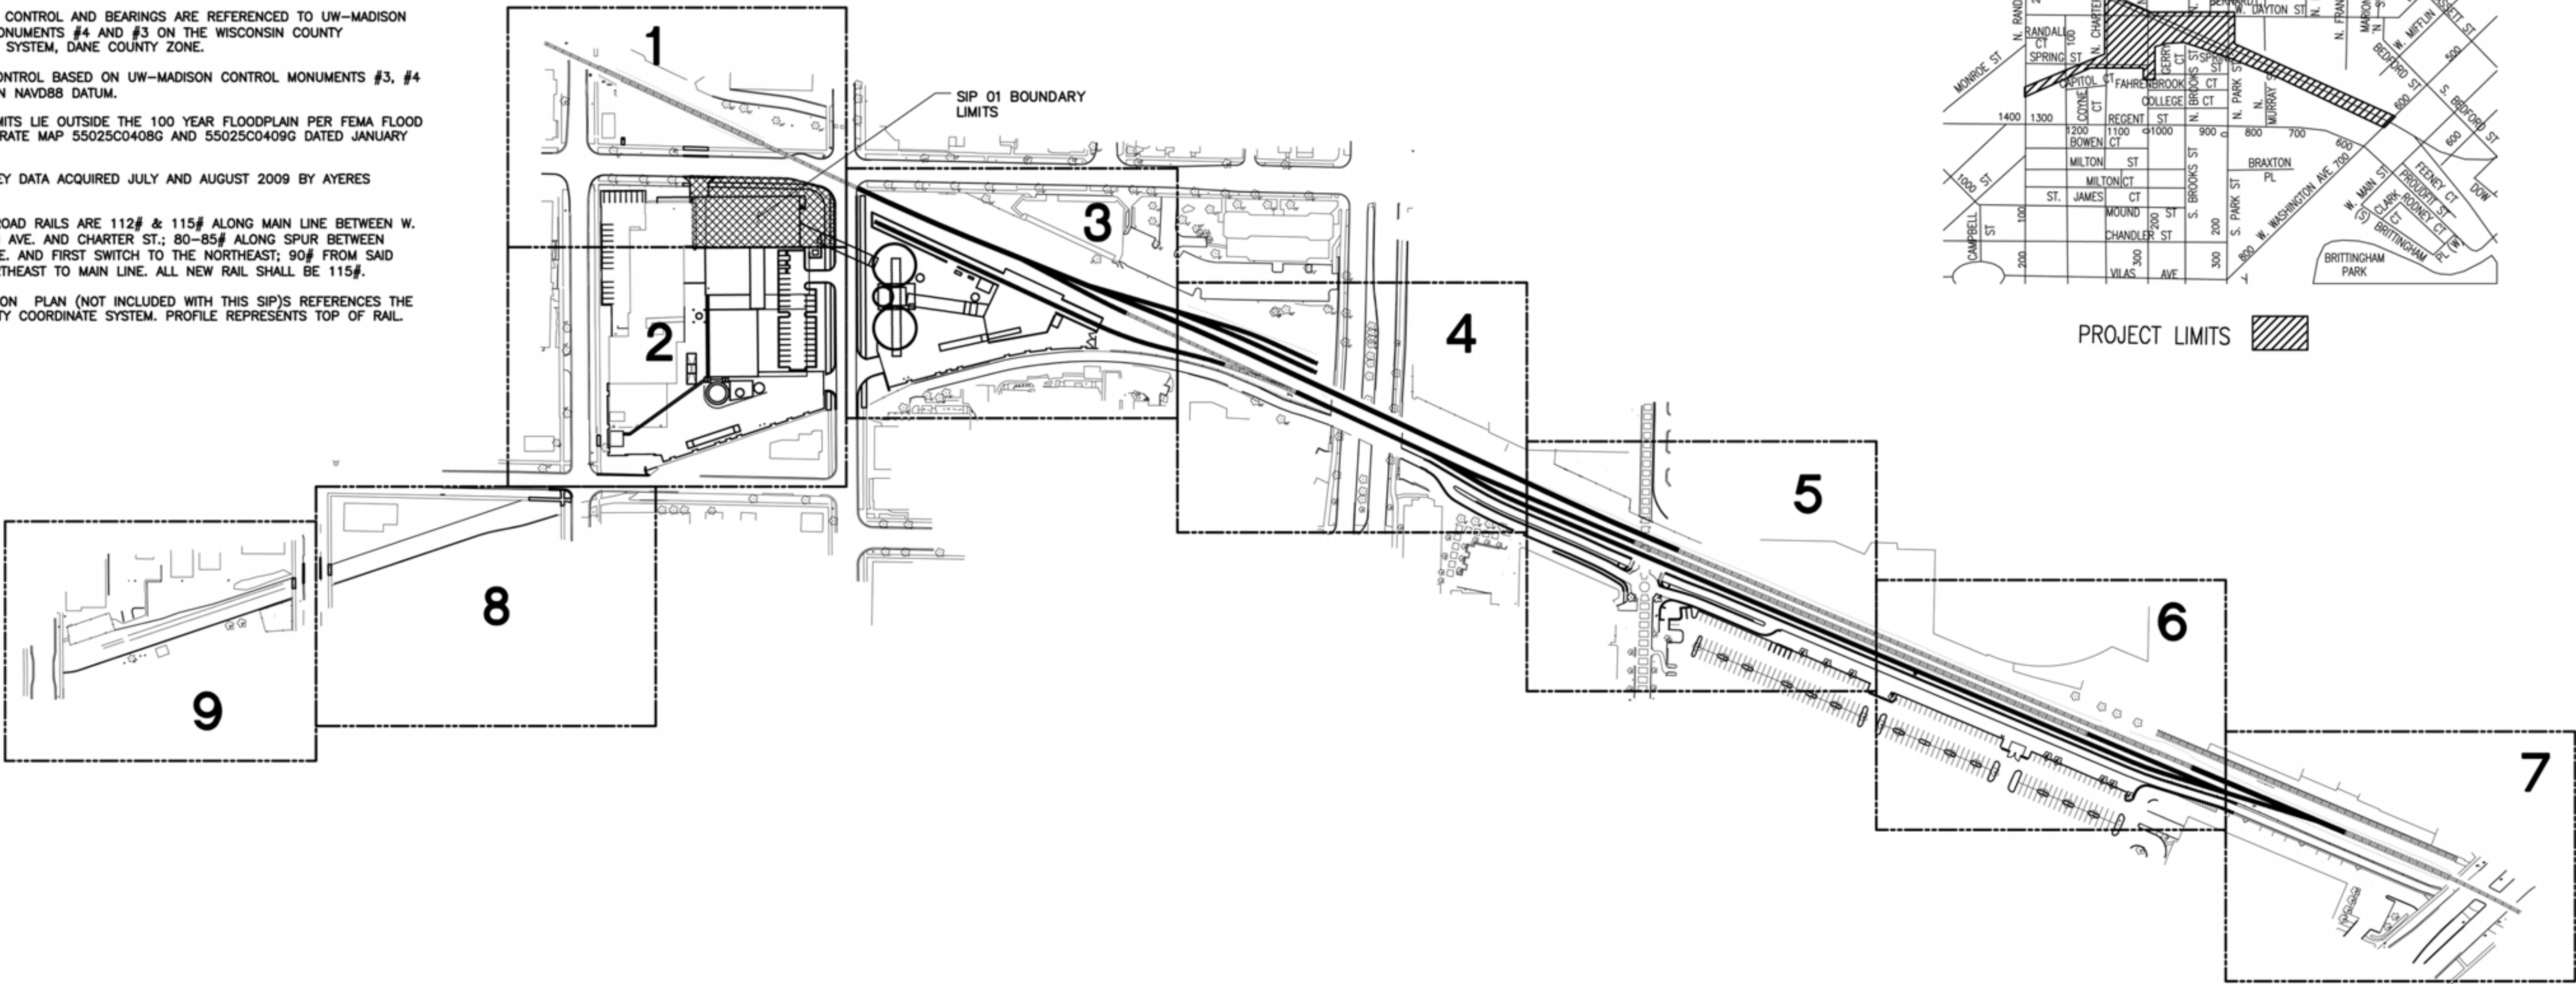

LOCATION MAP (NO SCALE)

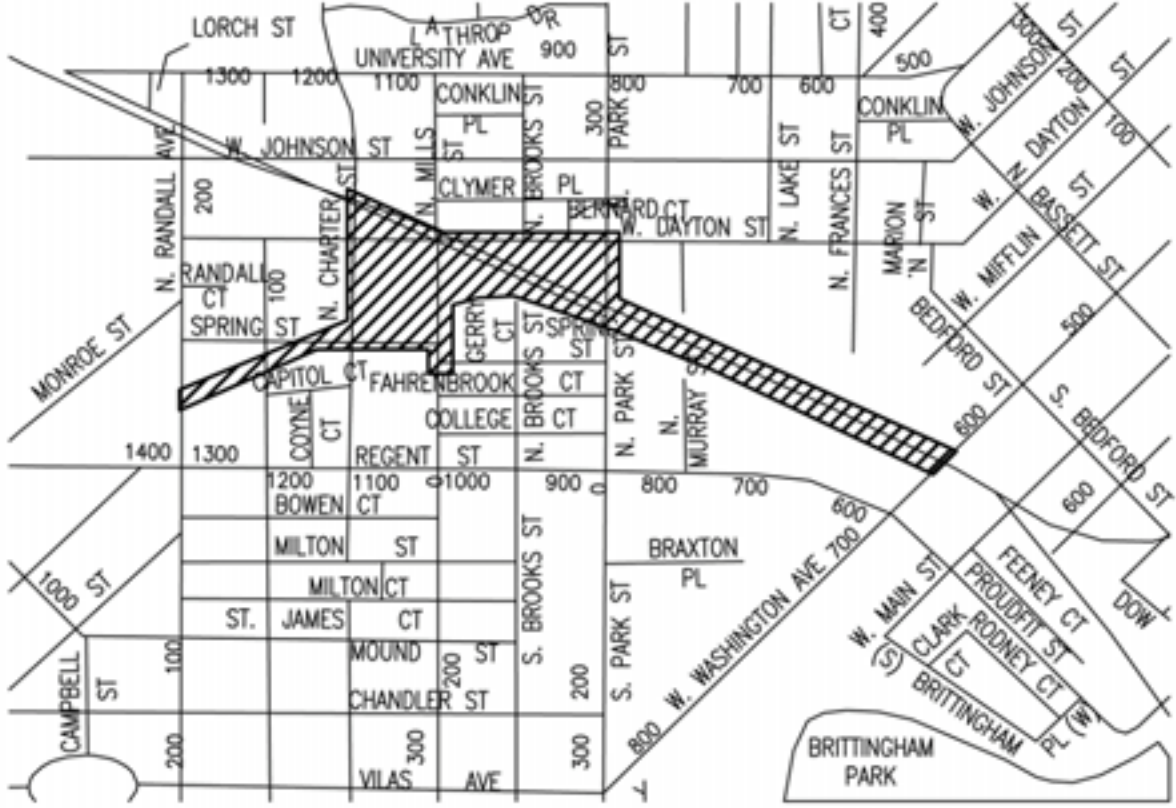

PROJECT LIMITS

LEGEND

○ MH	MANHOLE	---	RIGHT-OF-WAY LINE
□ INLET	INLET	---	LOT LINES
○ WV	WATER VALVE	---	EASEMENT LINES
○ GV	GAS VALVE	---	RR SWITCH
✱	STREET LIGHT	---	RR SIGNAL BOX
✱	FIRE HYDRANT	---	RR SIGNAL
✱	CONIFEROUS TREE	---	ELECTRIC METER
✱	DECIDUOUS TREE	---	GAS METER
-x-	FENCE	---	TRAFFIC SIGNAL LIGHT
---	EDGE OF GRAVEL AREA	---	TRAFFIC SIGNAL
-T-	UNDERGROUND TELEPHONE	---	W/LIGHT MAST ARM
-E-	UNDERGROUND ELECTRIC	---	POWER POLE
-FO-	UNDERGROUND FIBER OPTIC	---	W/LIGHT MAST ARM
-SAN-	UNDERGROUND SANITARY	---	GUY WIRE ANCHOR
-G-	UNDERGROUND GAS	---	POWER POLE
-W-	UNDERGROUND WATER	---	TELEPHONE POLE
-CW-	CHILLED WATER LINE	---	ABOVE GROUND TANK
-SS-	STORM SEWER	---	EDGE OF RR TIES
-STM-	STEAM LINE	---	RR TACKS
-FW-	FIRE WATER LINE	---	EXISTING TO BE DEMOLISHED
-OH-	OVERHEAD ELECTRIC	---	EXISTING TO BE DEMOLISHED BY OTHERS
-PS-	OILY WATER & PROCESS SEWER	---	GAS VENT
-SIG-	SIGNAL LINE	---	BRUSHLINE
□	STEAM ACCESS STRUCTURE	---	ELECTRIC PEDESTAL
○ B	MISC. SINGLE POLE SIGN	---	PARKING METER
○ B	CONCRETE/STEEL BOLLARD	---	POST INDICATOR VALVE
○ B	ELECTRIC PULLBOX	---	FIRE DEPT. CONNECTION
△ CP #18	SURVEY CONTROL POINT	---	TERMINAL POINT
⊕	BENCH MARK	---	
902.44	SPOT ELEVATION	---	
-25-	INTERMEDIATE CONTOUR	---	
-25-	INDEX CONTOUR	---	
○	3/4" X 18" IRON STAKE SET	---	
•	3/4" IRON STAKE FOUND	---	
+	CHISLED CROSS FOUND	---	
⊙	IRON PIPE FOUND (1" UNLESS OTHERWISE NOTED)	---	
x	CHISLED CROSS SET	---	
+	PK NAIL FOUND	---	

CIVIL DRAWINGS LIST

C000	COVER SHEET
C001	SITE PLAN
C002	SITE PLAN (NOT INCLUDED WITH THIS SIP)
C003	SITE PLAN (NOT INCLUDED WITH THIS SIP)
C004	SITE PLAN (NOT INCLUDED WITH THIS SIP)
C005	SITE PLAN (NOT INCLUDED WITH THIS SIP)
C006	SITE PLAN (NOT INCLUDED WITH THIS SIP)
C007	SITE PLAN (NOT INCLUDED WITH THIS SIP)
C008	SITE PLAN (NOT INCLUDED WITH THIS SIP)
C009	SITE PLAN (NOT INCLUDED WITH THIS SIP)
C060	TRUCK AUTOTURN EXHIBIT MAXIMUM MAINTENANCE TRUCK
C061	TRUCK AUTOTURN EXHIBIT ANTICIPATED MAINTENANCE TRUCK
C201	DEMOLITION PLAN
C202	DEMOLITION PLAN (NOT INCLUDED WITH THIS SIP)
C203	DEMOLITION PLAN (NOT INCLUDED WITH THIS SIP)
C204	DEMOLITION PLAN (NOT INCLUDED WITH THIS SIP)
C205	DEMOLITION PLAN (NOT INCLUDED WITH THIS SIP)
C206	DEMOLITION PLAN (NOT INCLUDED WITH THIS SIP)
C207	DEMOLITION PLAN (NOT INCLUDED WITH THIS SIP)
C208	DEMOLITION PLAN (NOT INCLUDED WITH THIS SIP)
C209	DEMOLITION PLAN (NOT INCLUDED WITH THIS SIP)
C301	UTILITIES PLAN
C302	UTILITIES PLAN (NOT INCLUDED WITH THIS SIP)
C303	UTILITIES PLAN (NOT INCLUDED WITH THIS SIP)
C304	UTILITIES PLAN (NOT INCLUDED WITH THIS SIP)
C305	UTILITIES PLAN (NOT INCLUDED WITH THIS SIP)
C306	UTILITIES PLAN (NOT INCLUDED WITH THIS SIP)
C307	UTILITIES PLAN (NOT INCLUDED WITH THIS SIP)
C308	UTILITIES PLAN (NOT INCLUDED WITH THIS SIP)
C309	UTILITIES PLAN (NOT INCLUDED WITH THIS SIP)
C330	TYPICAL U/G UTILITY AND SEWER SECTIONS
C350	TYPICAL U/G UTILITY AND SEWER DETAILS
C401	FIRE WATER PLAN
C402	FIRE WATER PLAN (NOT INCLUDED WITH THIS SIP)
C403	FIRE WATER PLAN (NOT INCLUDED WITH THIS SIP)
C501	GRADING AND DRAINAGE PLAN
C502	GRADING AND DRAINAGE PLAN (NOT INCLUDED WITH THIS SIP)
C503	GRADING AND DRAINAGE PLAN (NOT INCLUDED WITH THIS SIP)
C504	GRADING AND DRAINAGE PLAN (NOT INCLUDED WITH THIS SIP)
C505	GRADING AND DRAINAGE PLAN (NOT INCLUDED WITH THIS SIP)
C506	GRADING AND DRAINAGE PLAN (NOT INCLUDED WITH THIS SIP)
C507	GRADING AND DRAINAGE PLAN (NOT INCLUDED WITH THIS SIP)
C508	GRADING AND DRAINAGE PLAN (NOT INCLUDED WITH THIS SIP)
C509	GRADING AND DRAINAGE PLAN (NOT INCLUDED WITH THIS SIP)

PEC

POWER ENGINEERS
COLLABORATIVE LLC

150 Sunny Slope Road
Suite 110
Brookfield, Wisconsin 53005
WWW.PECLLC.COM

PÖYRY
PÖYRY (APPLETON) LLC
APPLETON, WISCONSIN

middough

Potter Lawson

State of Wisconsin
Department of Administration
Division of State Facilities



Agency / Institution:
UNIVERSITY OF WISCONSIN, MADISON

Project Title:
CHARTER STREET REBUILD

Project Location:
MADISON, WI.


Sheet Title:
COVER SHEET

No.	Date:	By:	Description:
△	03-10-10	MCI	GDP SUBMITTAL
△	03-12-10	MCI	EPC CONCEPT
△	04-15-10	MCI	EPC CONCEPT
△	05-24-10	MCI	SIP 01 SUBMITTAL

Graphic Scale	
DSF Number	09A2L
Set Type	PR
Date Issued	03-10-10
Sheet Number	C000



Number	Elevation	Description
1	861.24	NW bolt of base or railroad signal
2	860.08	Chisled "+\" in manhole rim
3	871.07	Brass disk in bridge
4	861.30	Chisled "+\" in curb
5	863.59	Top operating nut of fire hydrant
6	860.88	Chisled "+\" in sidewalk
7	864.45	Chisled "+\" in curb
8	864.31	Top operating nut of fire hydrant
9	859.63	Chisled "+\" in curb
10	865.12	Chisled "+\" in se corner concrete porch
11	873.50	Top operating nut of fire hydrant

BENCHMARKS

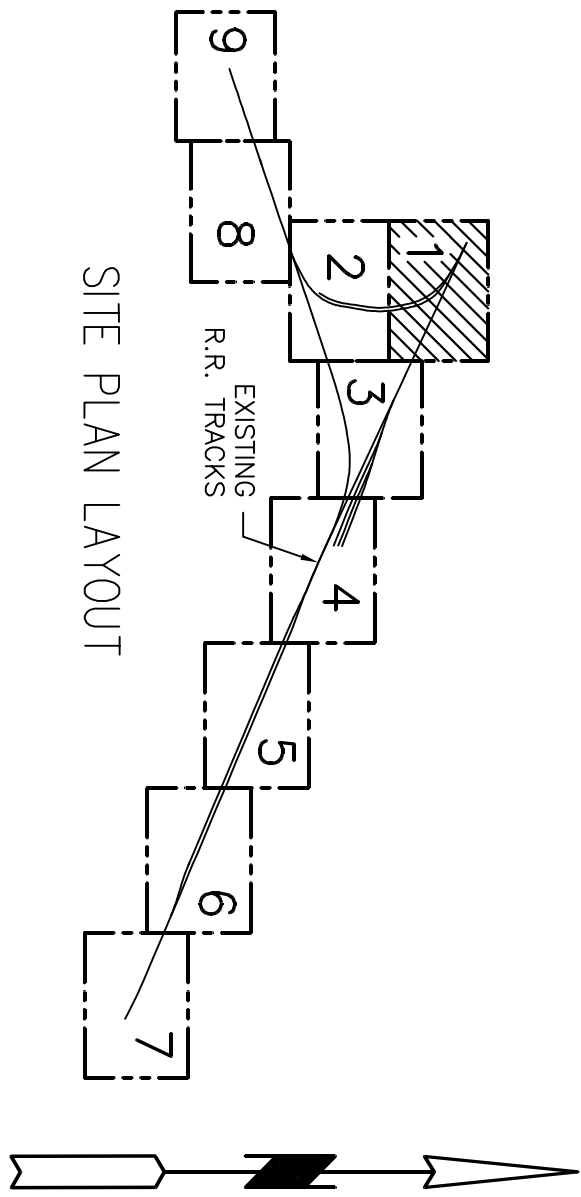

SITE PLAN LAYOUT

- NOTE
1. NAD 88 873.30 ELEVATION - 100'-0" PLANT ELEVATION
 2. FOR LEGEND AND NOTES SEE TITLE SHEET C000
 3. PROJECT INFORMATION ON THIS SHEET OUTSIDE THE SIP BOUNDARY WILL BE DETAILED IN FUTURE SIP SUBMITTALS

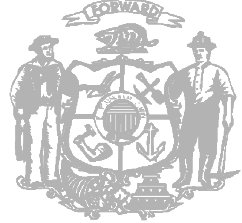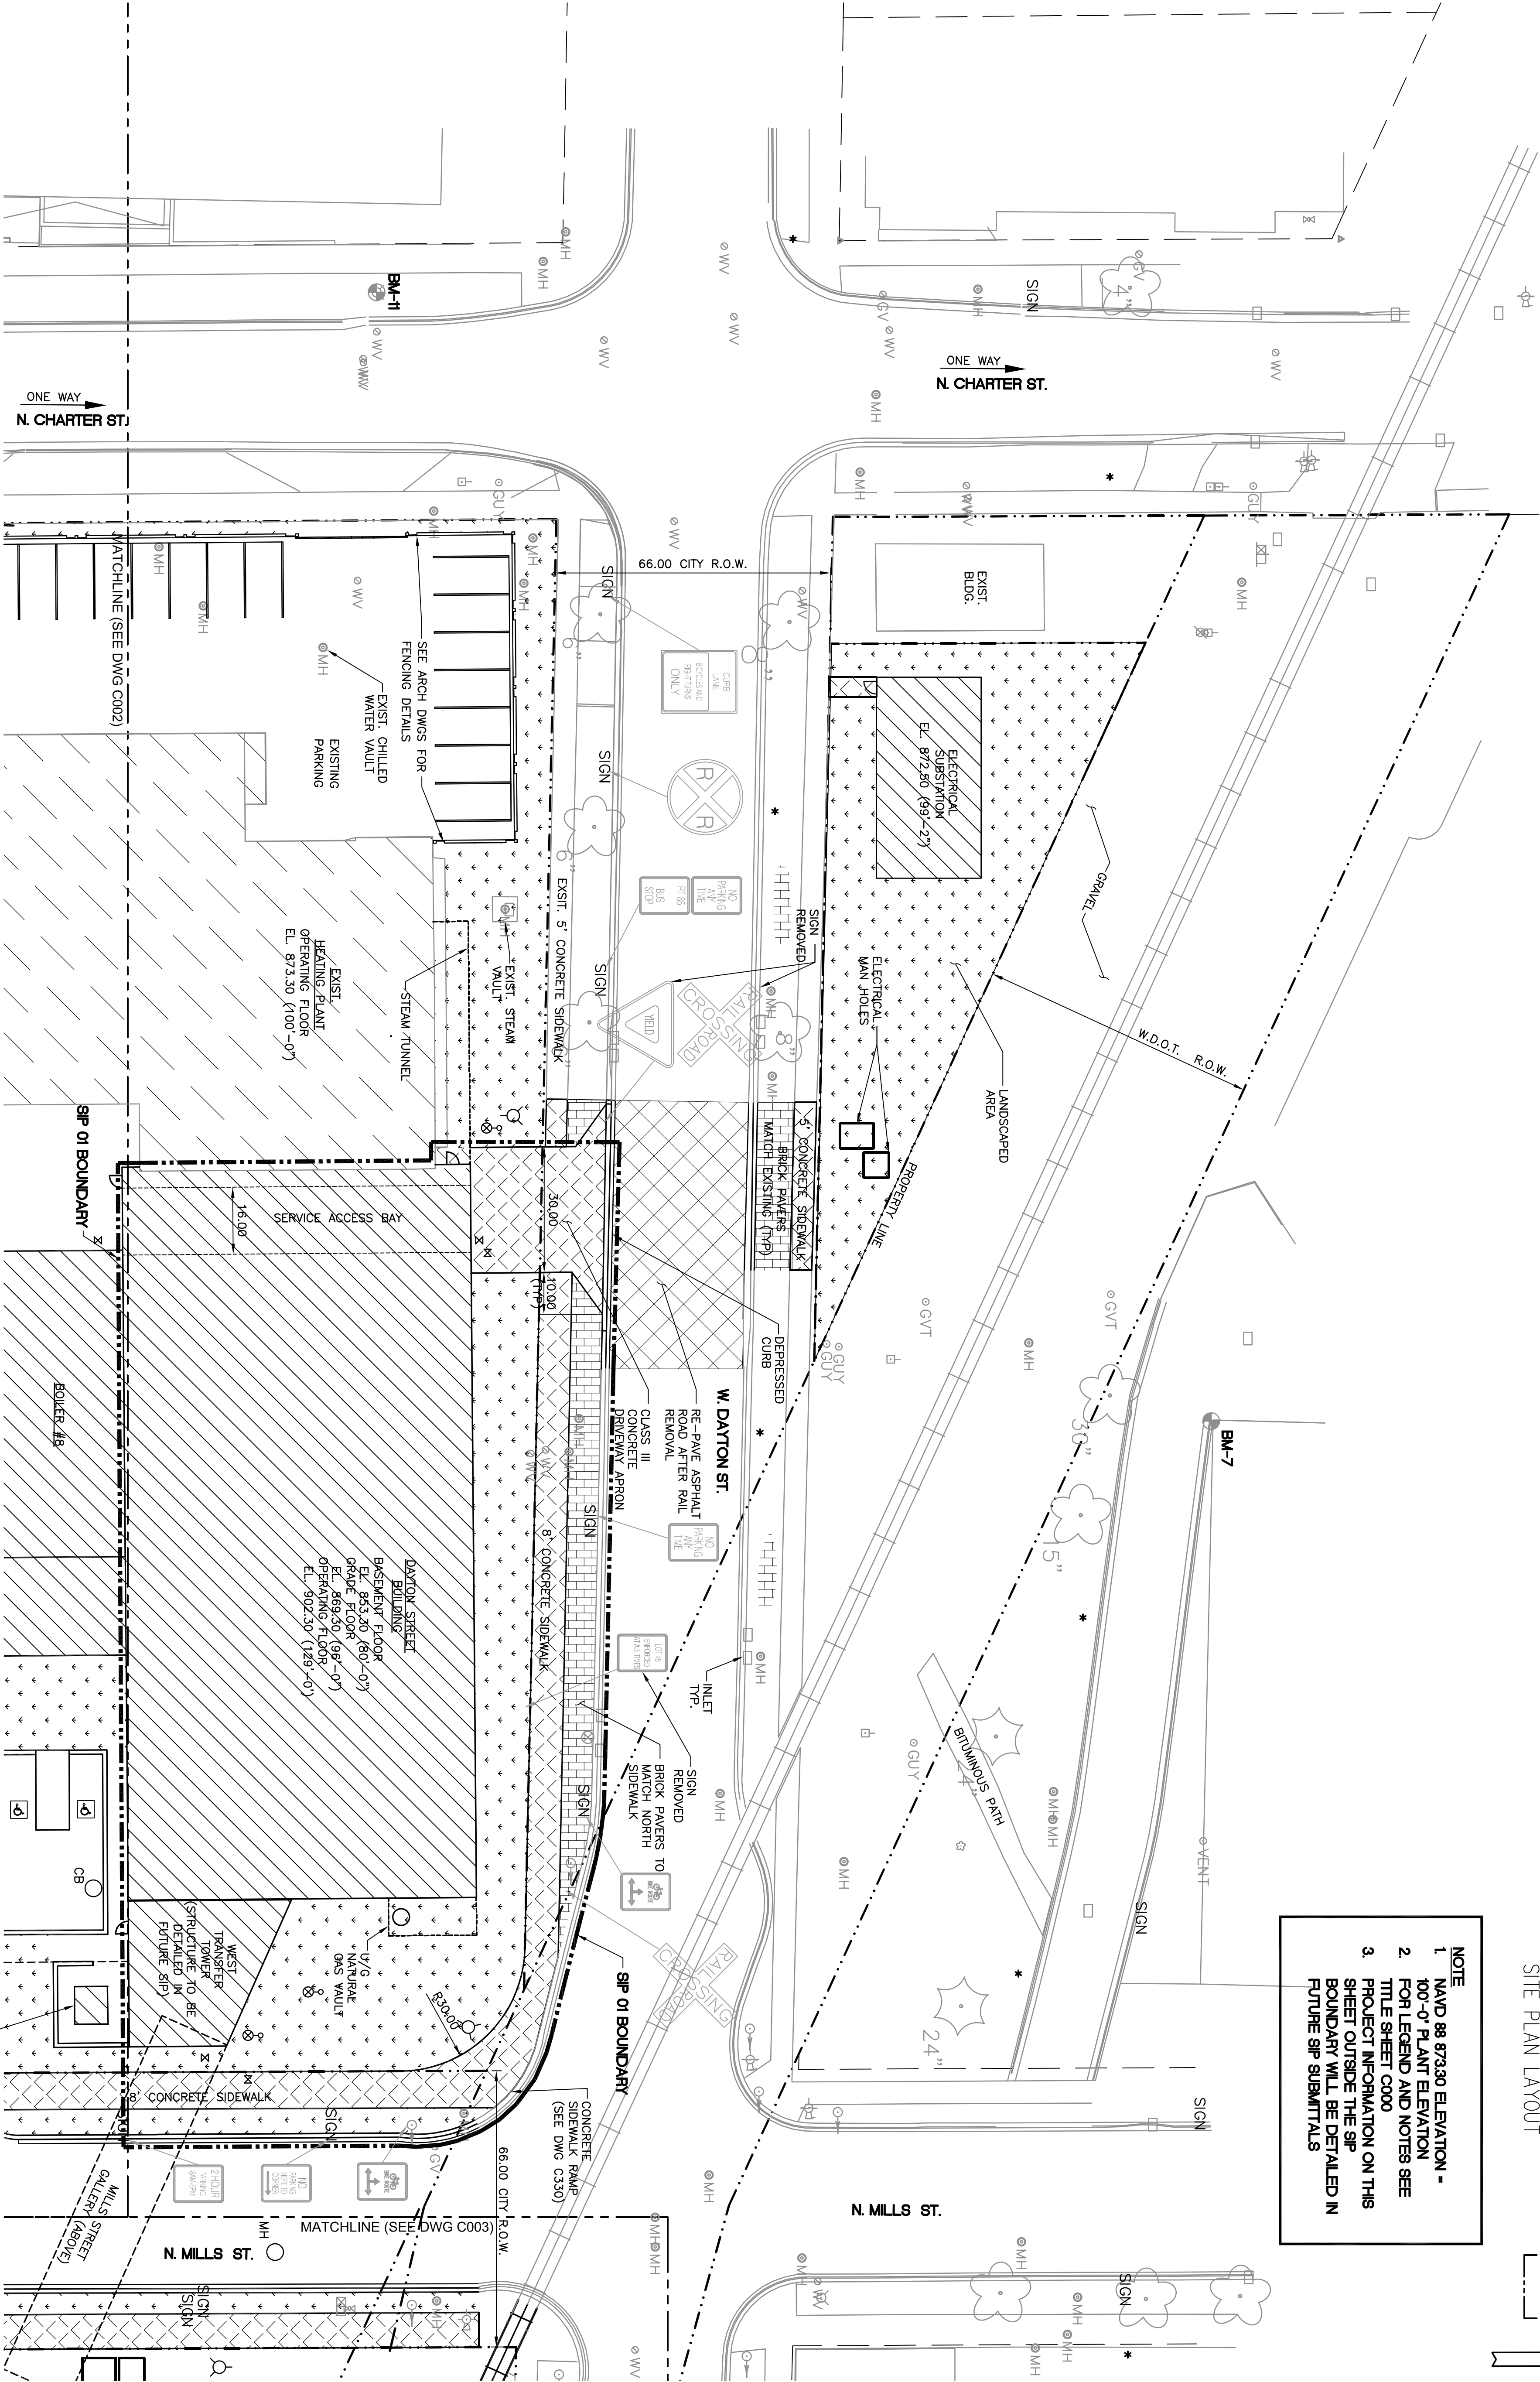

State of Wisconsin
Department of Administration
Division of State Facilities

Agency / Institution:
UNIVERSITY OF WISCONSIN, MADISON

Project Title:
CHARTER STREET REBUILD





Project Location:
MADISON, WI.

Sheet Title:
SITE PLAN

No.	Date:	By:	Description:
1	12-04-09	WJS	FOR REVIEW
2	01-15-10	WJS	FOR REVIEW
3	03-10-10	WJS	FOR SUBMITTAL
4	03-12-10	WJS	EPC CONCEPT
5	03-19-10	WJS	EPC CONCEPT
6	04-15-10	WJS	FOR SUBMITTAL
7	05-24-10	WJS	SIP 01 SUBMITTAL

Graphic Scale	10' 0' 20'
DSF Number	09A2L
Set Type	PR
Date Issued	12-04-09

Sheet Number
C001

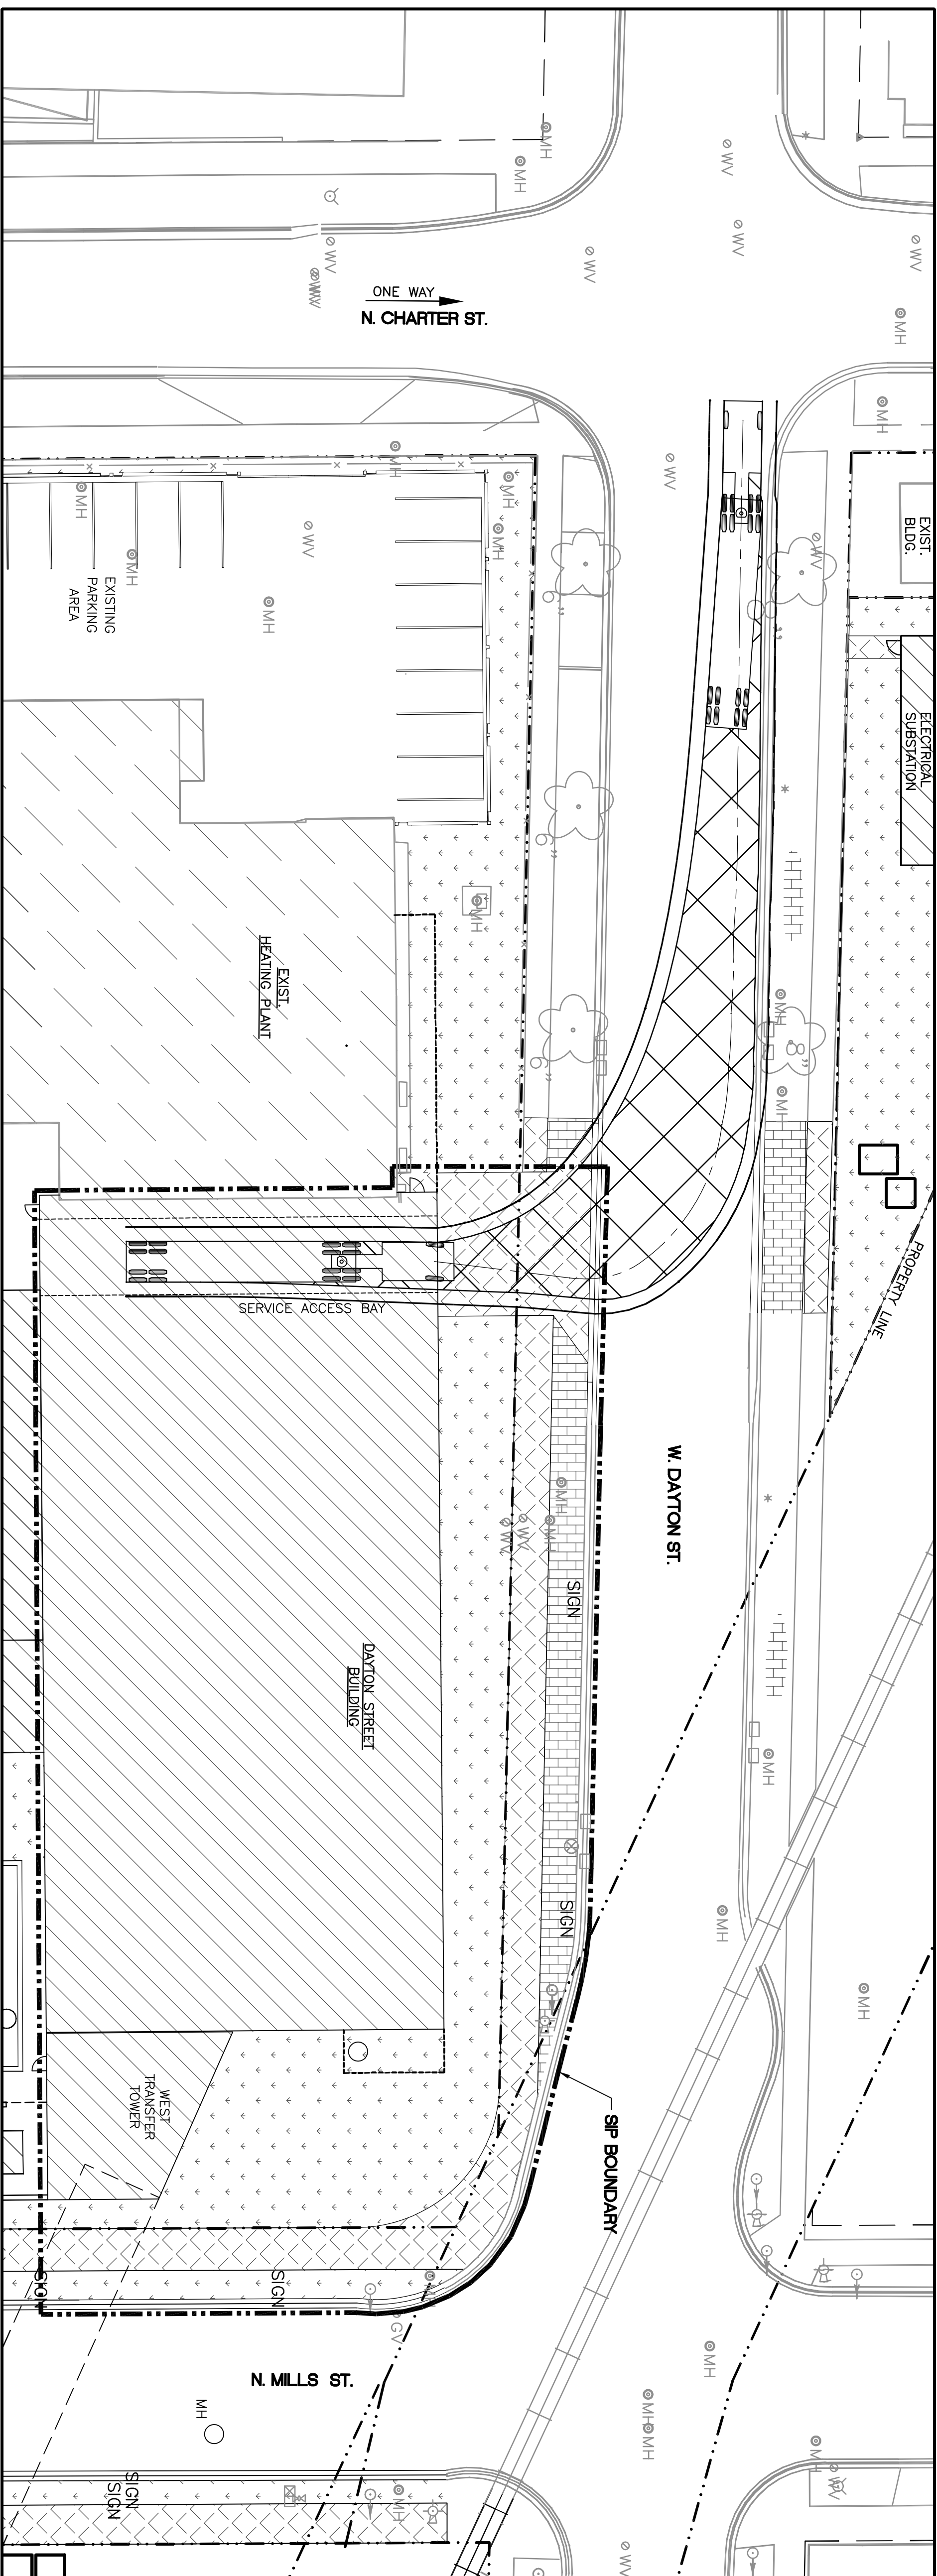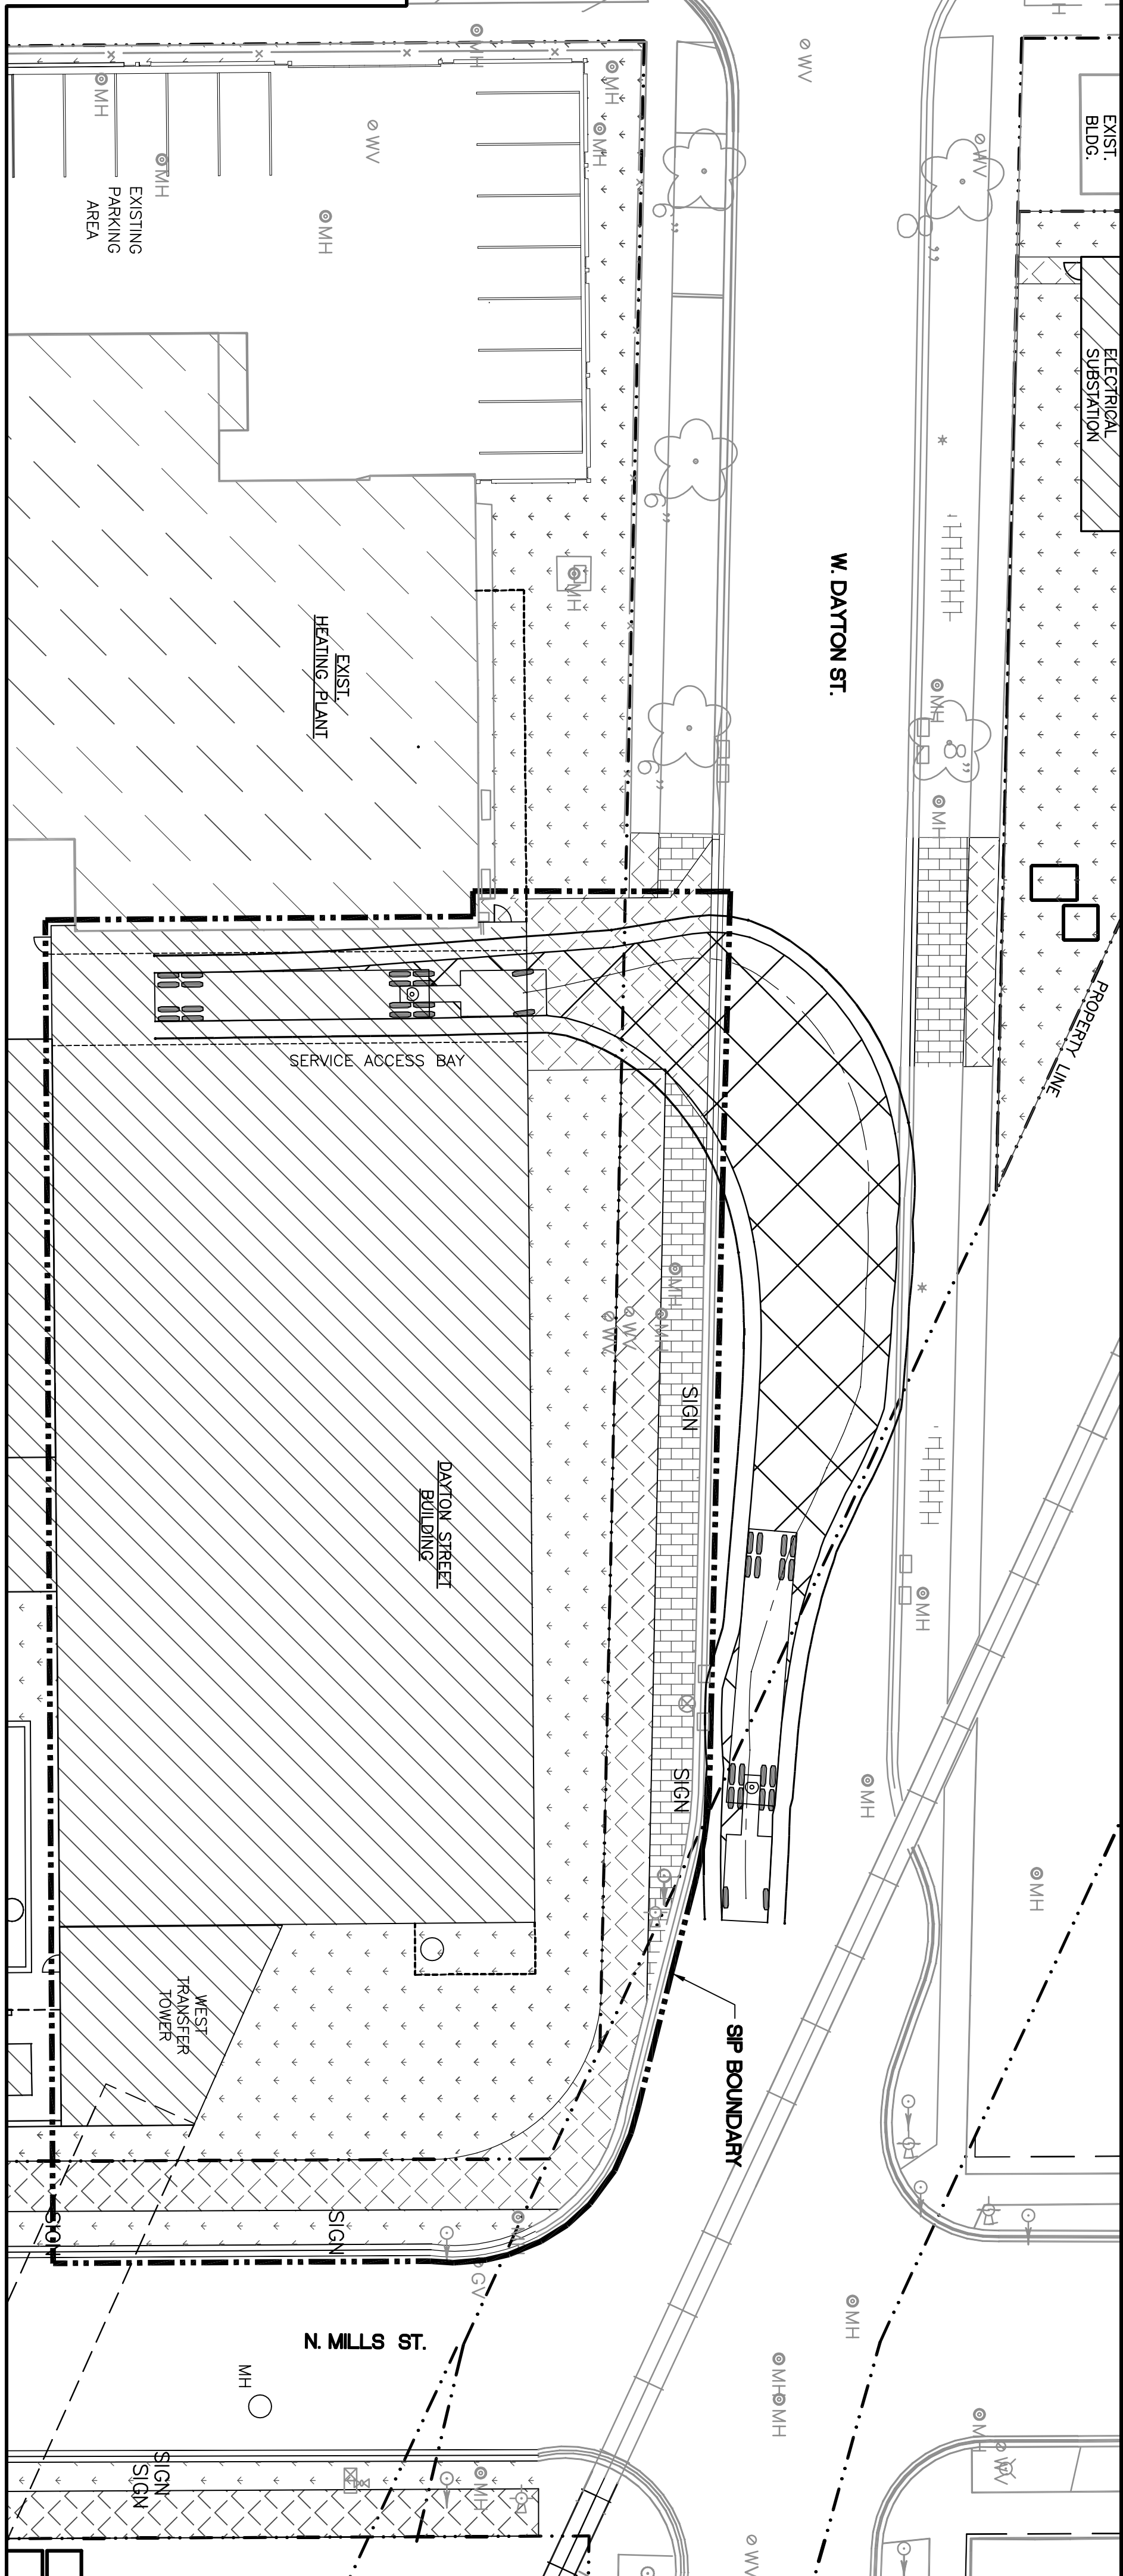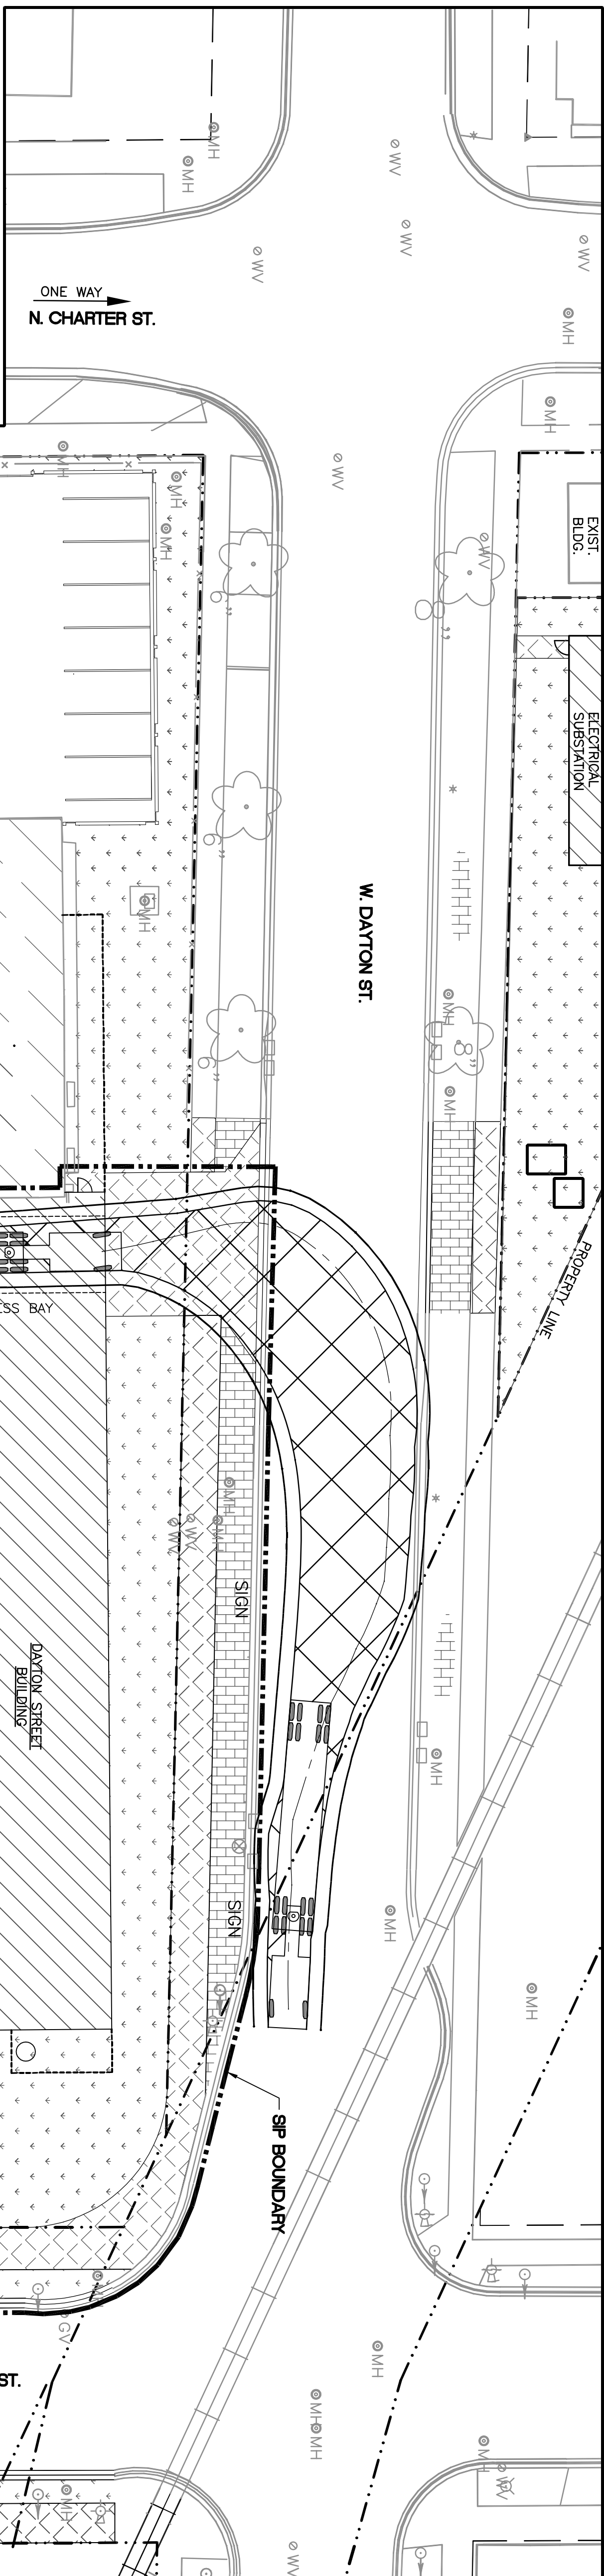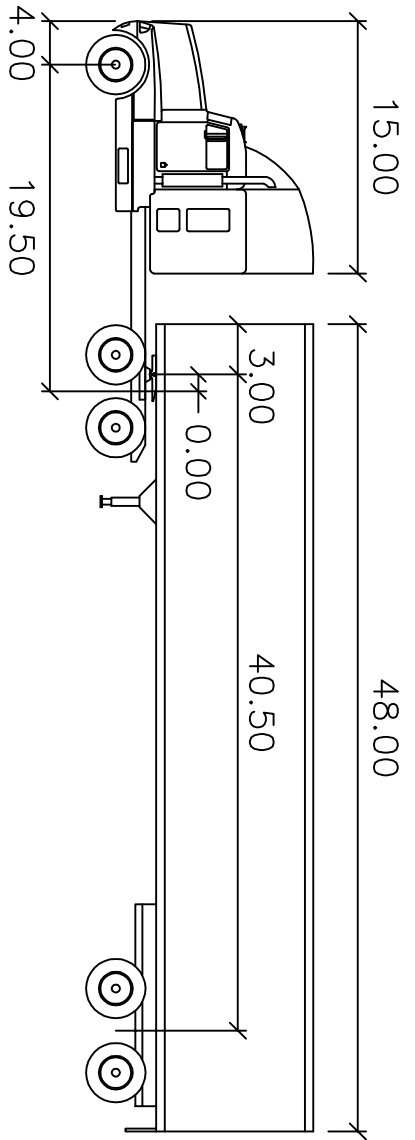


No.	Date:	By:	Description:
05-24-10	MCI	SIP 01 SUBMITTAL	

Project Title:
CHARTER STREET REBUILD

Project Location:
MADISON, WI.

Sheet Title:
**TRUCK AUTOTURN EXHIBIT
MAXIMUM MAINTENANCE TRUCK**


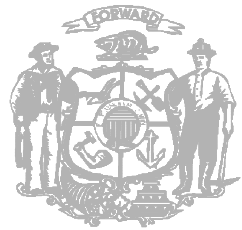


Agency / Institution:
UNIVERSITY OF WISCONSIN, MADISON





**POWER ENGINEERS
COLLABORATIVE LLC**
150 Sunny Slope Road
Suite 110
Brookfield, Wisconsin 53005
WWW.PECOLL.COM



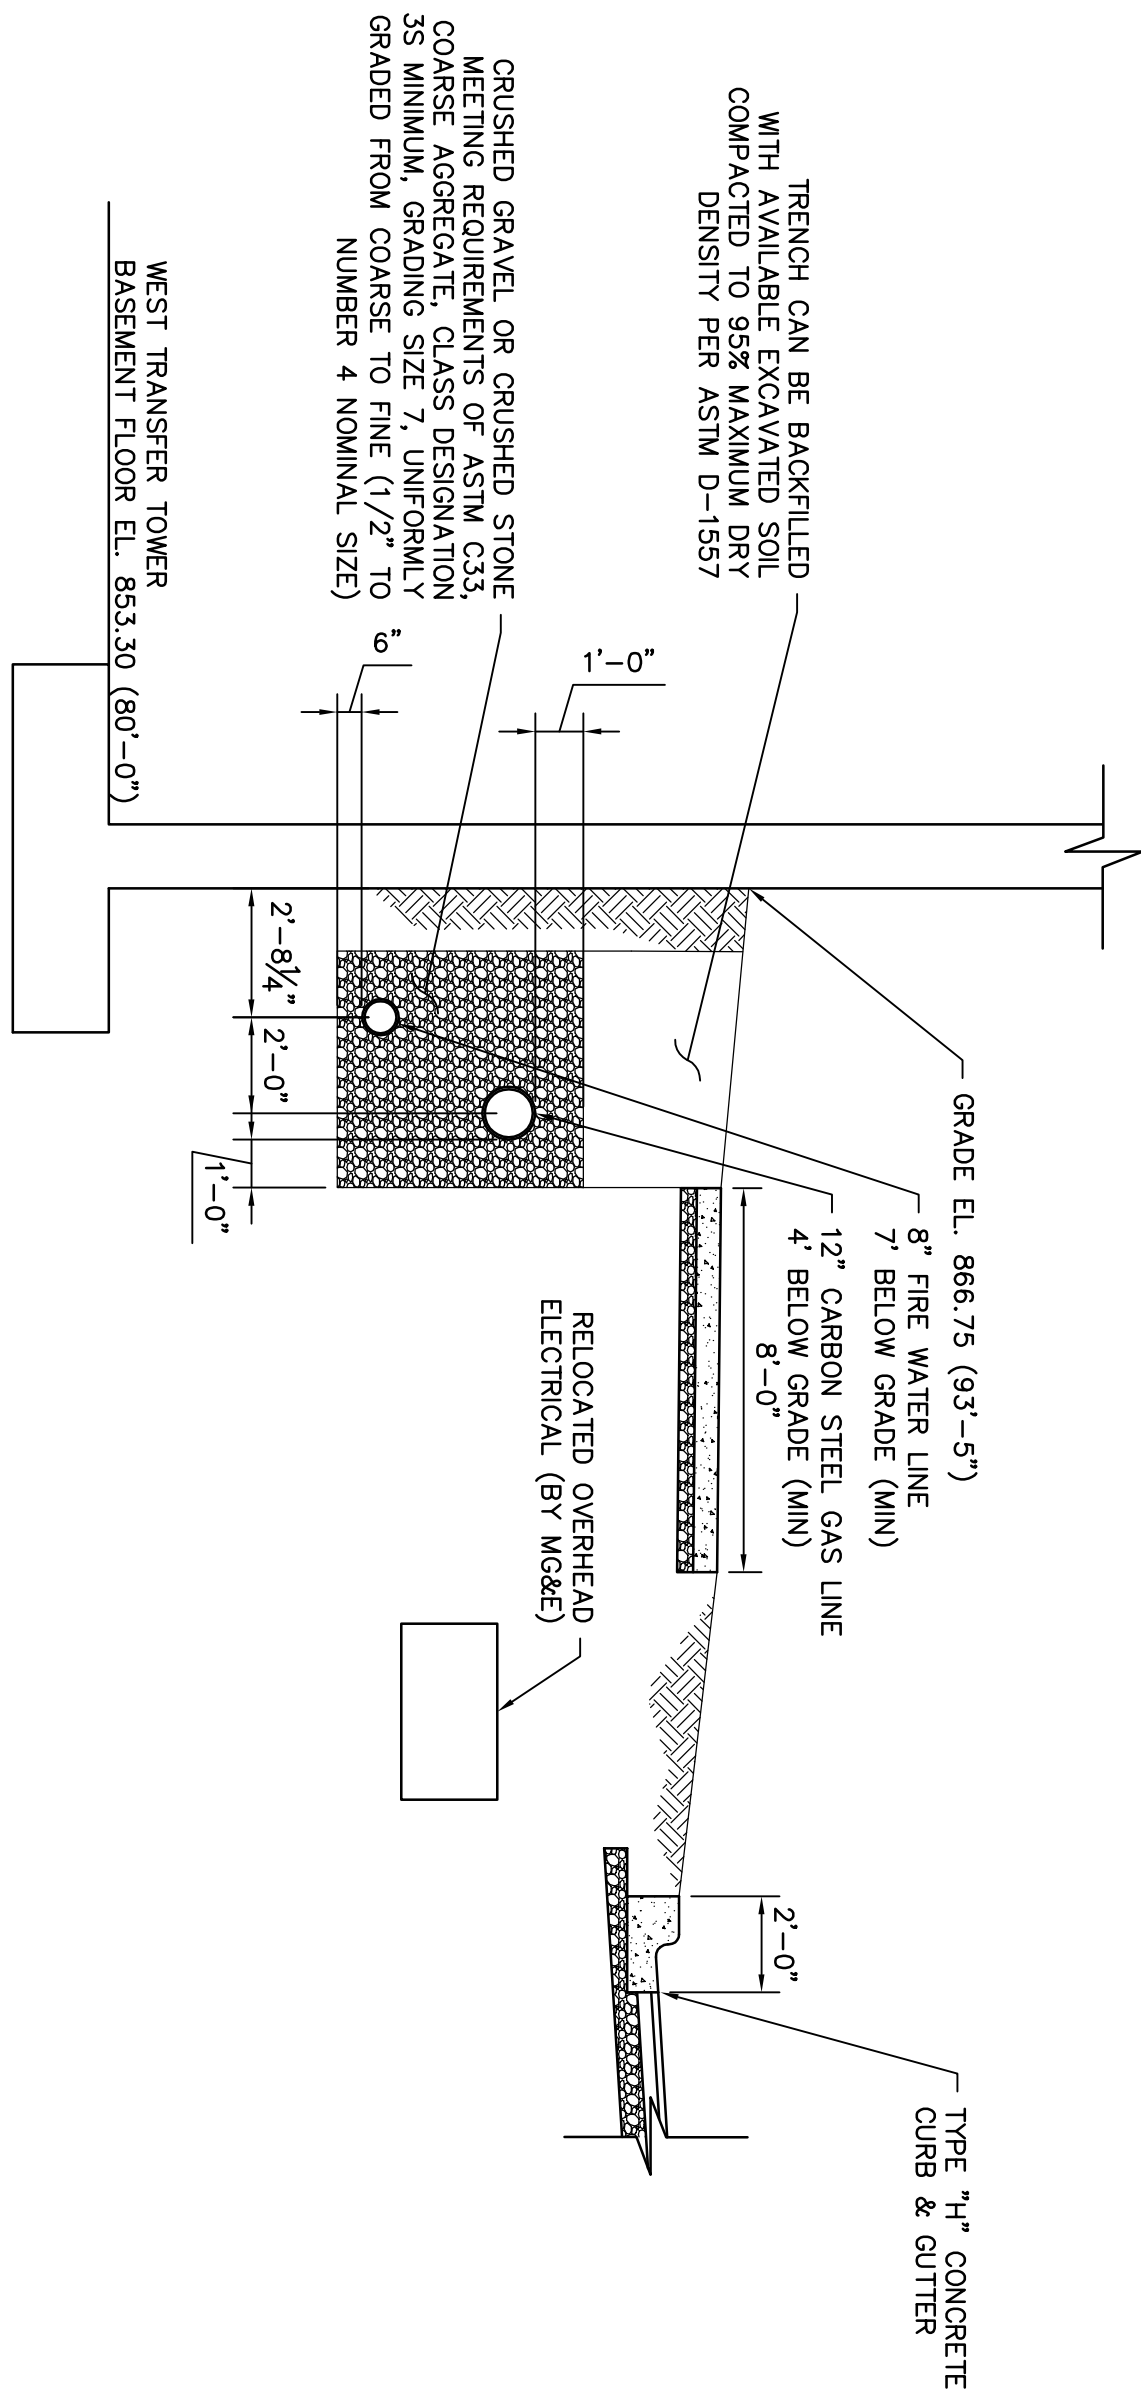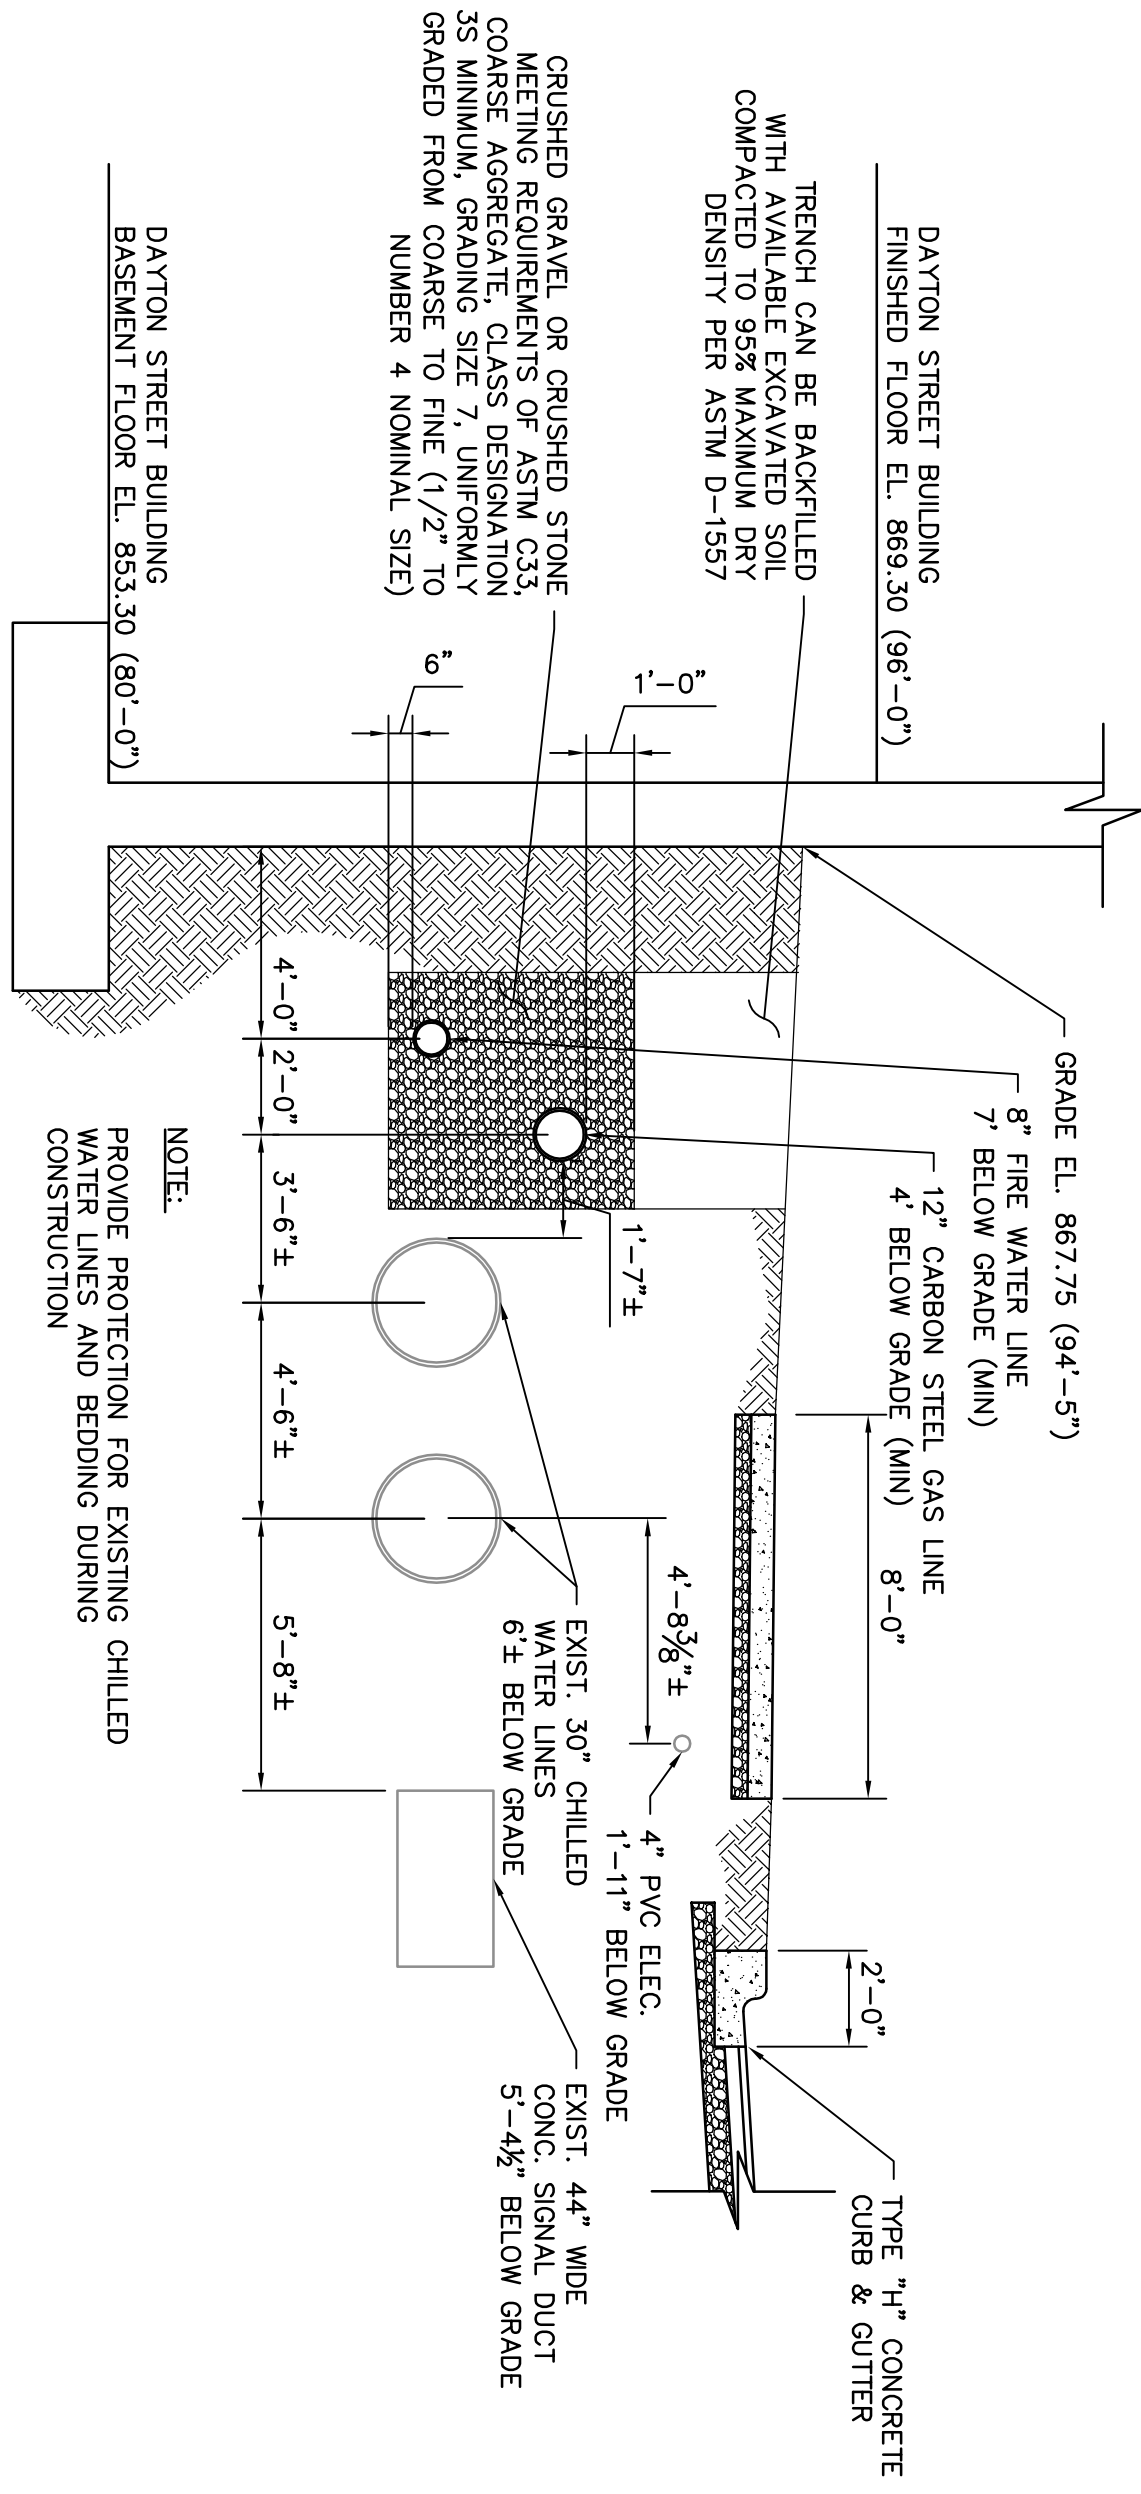


PEC										POWER ENGINEERS COLLABORATIVE LLC 150 Sunny Slope Road Sun Prairie, WI 53005 WWW.PECILLC.COM										 									
----------------	--	--	--	--	--	--	--	--	--	---	--	--	--	--	--	--	--	--	--	--	--	--	--	--	--	--	--	--	--

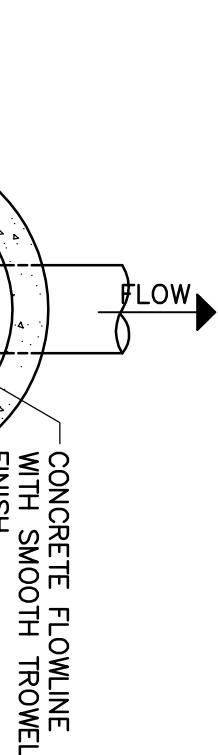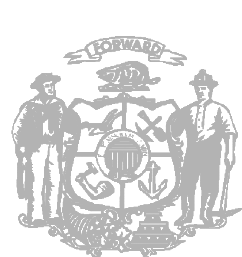



TOP VIEW

DETAIL "A"
SHOWING DROP INLET CONSTRUCTION
FOR SANITARY SEWER MAINS AND LATERALS

- NOTES:
1. PRECAST S.A.S. SECTIONS SHALL BE CONSTRUCTED IN ACCORDANCE WITH ASTM C-478.
 2. CENTERED (CONCENTRIC) CONE SHALL BE INSTALLED UNLESS OTHERWISE DIRECTED.
 3. FLEXIBLE PIPE TO S.A.S. CONNECTOR REQUIRED PER STANDARD DETAIL B.
 4. ALL BENCHES TO BE FIELD POURED CONCRETE WITH REINFORCED PRECAST RINGS. PRECAST RINGS ONLY PERMITTED WITH PRIOR APPROVAL OF ENGINEER IN WRITING.
 5. ALL JOINTS BETWEEN RINGS SHALL BE SEALED WITH $\frac{1}{2}$ " OF AIR-ENTRAINED TYPE M OR S MORTAR. THE OUTSIDE SURFACE OF THE ADJUSTING RINGS SHALL BE SEALED WITH A MECHANICAL MORTAR TYPE M OR S SEAL. THE METHOD USED FOR SEALING THE OUTSIDE SURFACE SHALL BE COMPATIBLE WITH THAT USED TO SEAL JOINTS BETWEEN THE RINGS.
 6. PRECAST SANITARY SEWER ACCESS STRUCTURES FOR STREET RECONSTRUCTION PROJECTS AND FOR STREET EXCAVATION PERMITS REQUIRE PRECAST SHOP DRAWING APPROVAL FROM CITY ENGINEERING. PRIOR TO BEING FABRICATED BY THE MANUFACTURER, NO PRECAST SHOP DRAWINGS ARE REQUIRED FOR NEW CONSTRUCTION IN SUBURBAN DEVELOPMENTS.

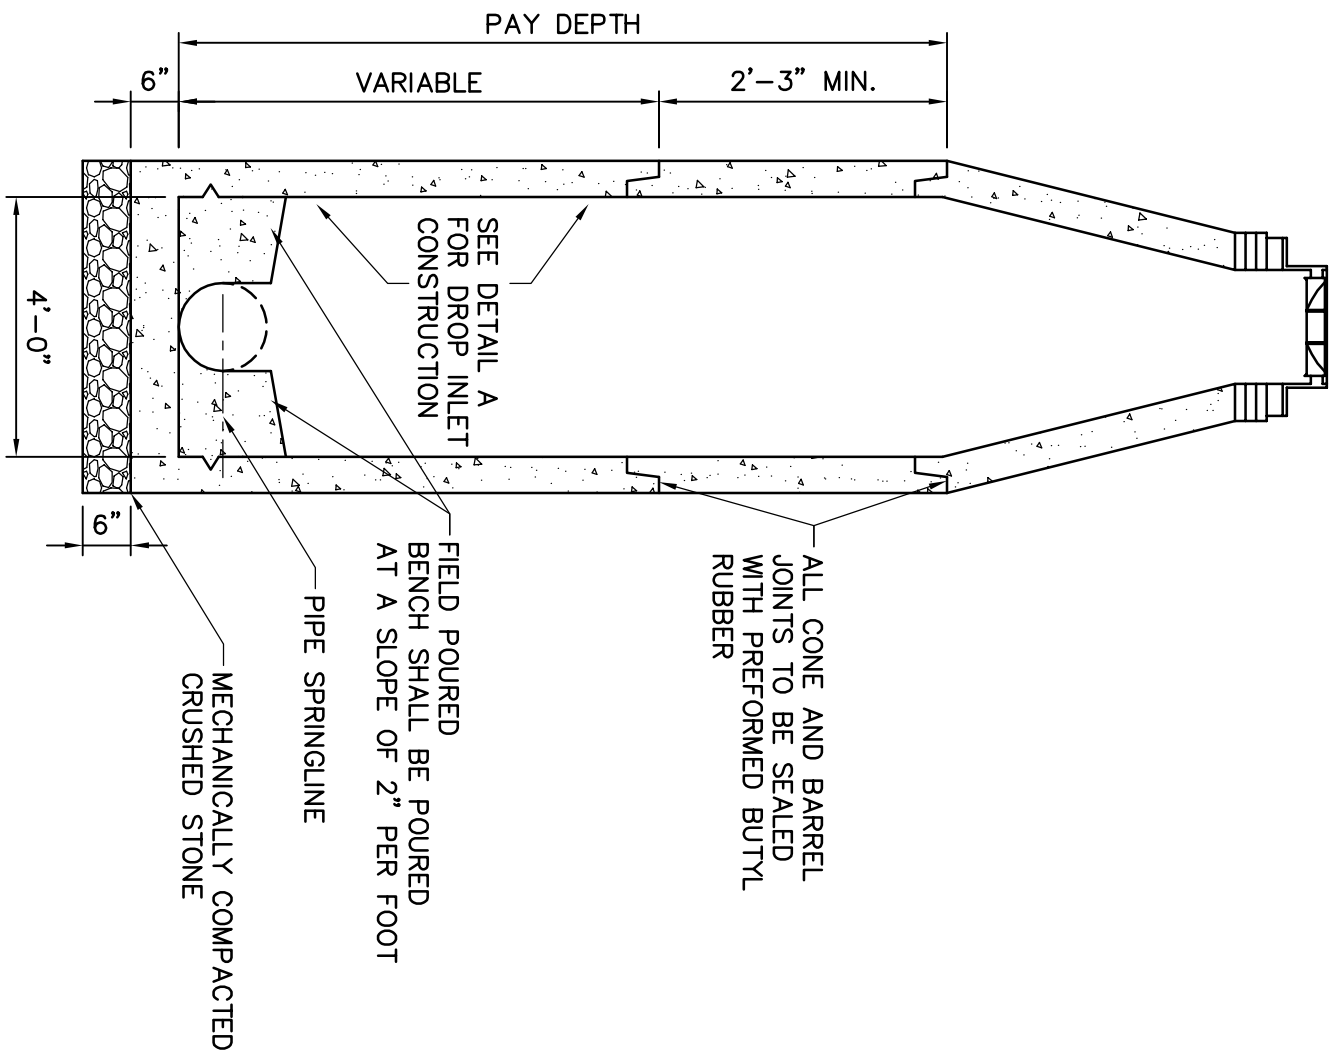


SECTION A-A

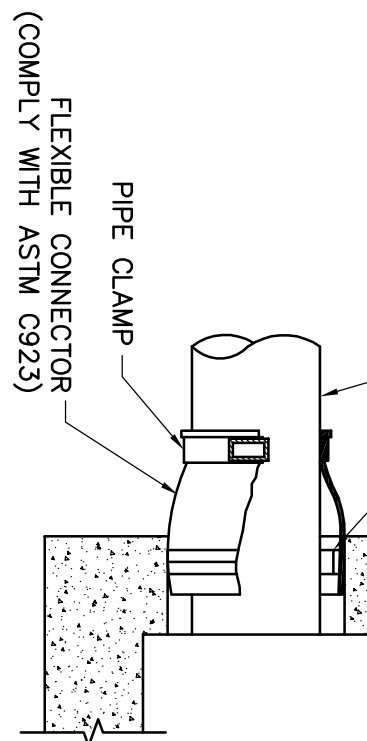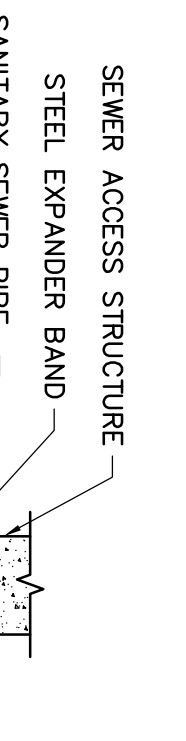SANITARY SEWER
PRECAST SEWER ACCESS
STRUCTURE (S.A.S.)


FLEXIBLE PIPE TO S.A.S. CONNECTOR

DETAIL "B"

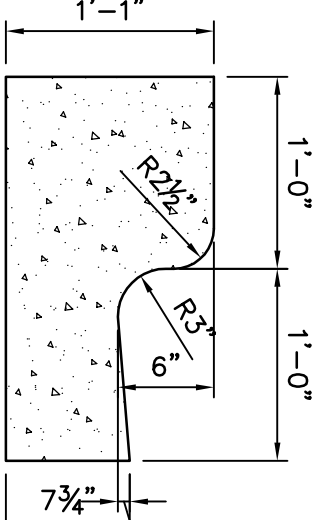



- NOTES:
1. LATERAL CONTRACTION JOINTS SHALL BE PLACED AT INTERVALS OF NOT MORE THAN 15' AND NOT LESS THAN 8' IN LENGTH. THE JOINTS SHALL BE A MINIMUM OF 3' IN DEPTH.
 2. EXPANSION JOINTS SHALL BE PLACED TRANSVERSELY AT RADIUS POINTS ON CURVES OF RADIUS 200' OR LESS AND AT ANGLE POINTS, OR AS DIRECTED BY THE ENGINEER. THE EXPANSION JOINT SHALL BE ONE PIECE ASPHALTIC MATERIAL HAVING THE SAME DIMENSIONS AS LONG ADJUTER. THE EXPANSION JOINT SHALL BE PLACED IN ALL SECTIONS OF THE SANITARY AND GUTTER SHALL BE PLACED ON THOROUGHLY COMPACTED CRUSHED STONE.

TYPE 'G' CONCRETE CURB AND GUTTER


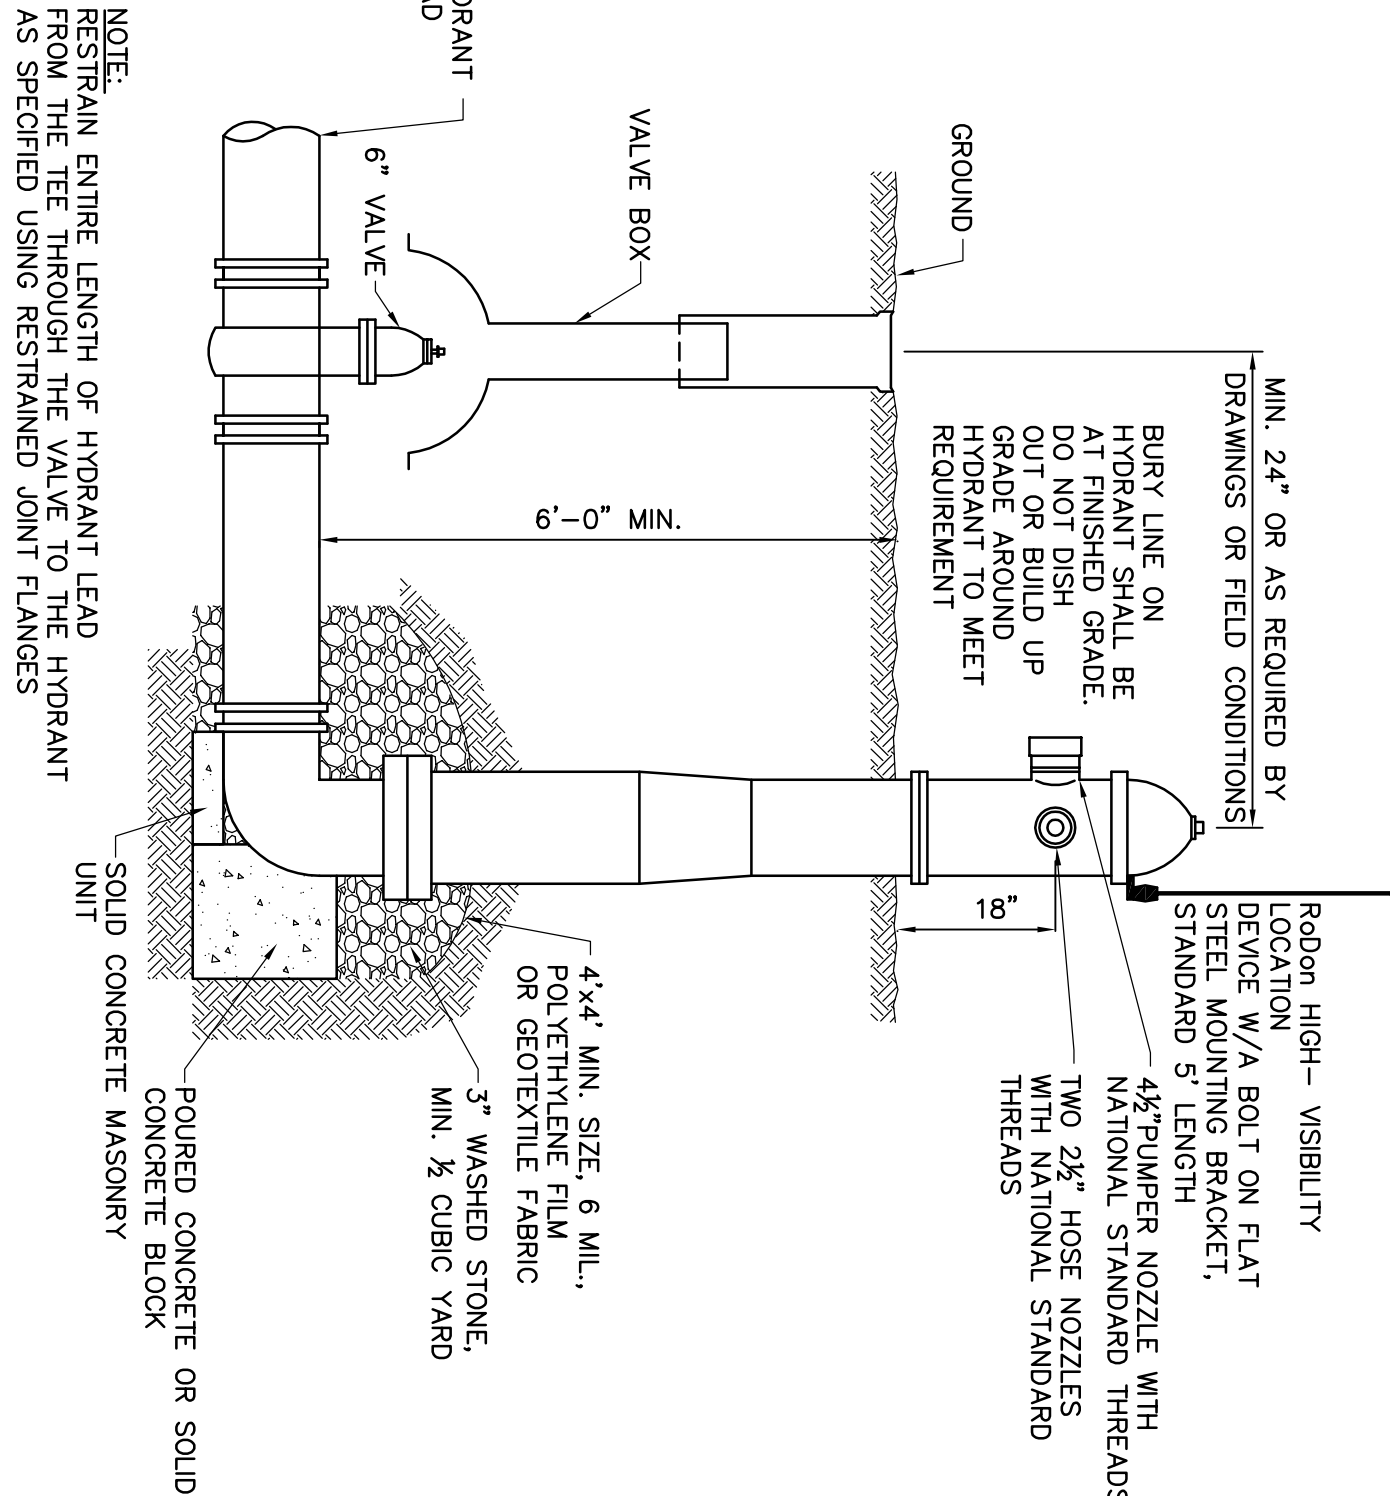


TYPICAL HYDRANT INSTALLATION

- NOTE:
RESTRAIN ENTIRE LENGTH OF HYDRANT LEAD FROM THE TEE THROUGH THE VALVE TO THE HYDRANT AS SPECIFIED USING RESTRAINED JOINT FLANGES

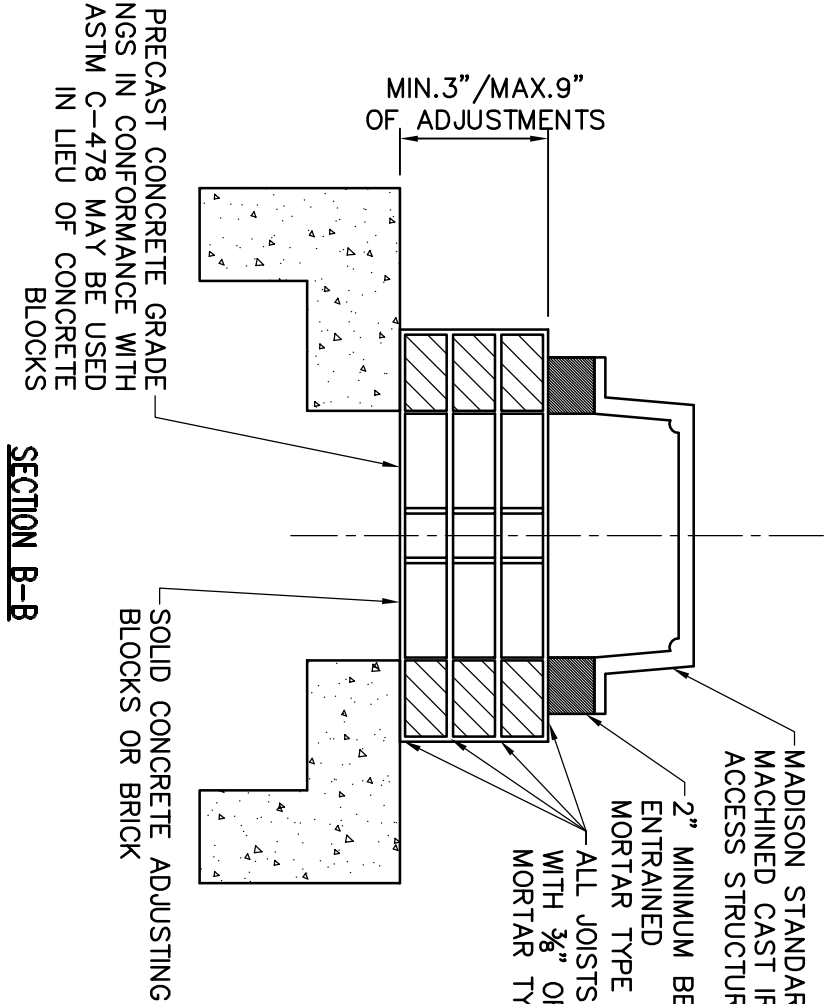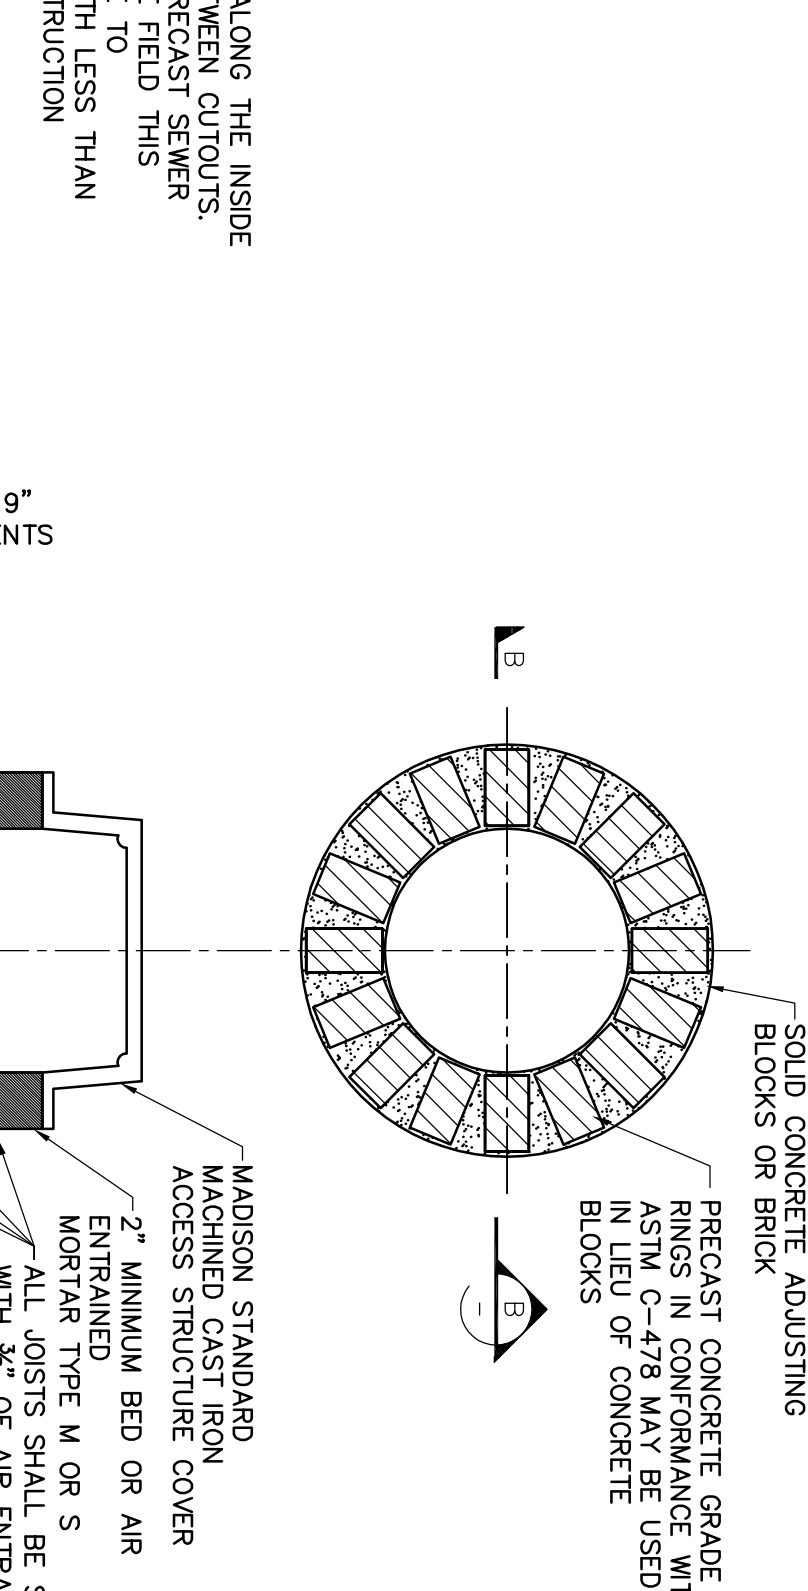
SEWER ACCESS STRUCTURE
CHIMNEY AND CASTING

SECTION B-B

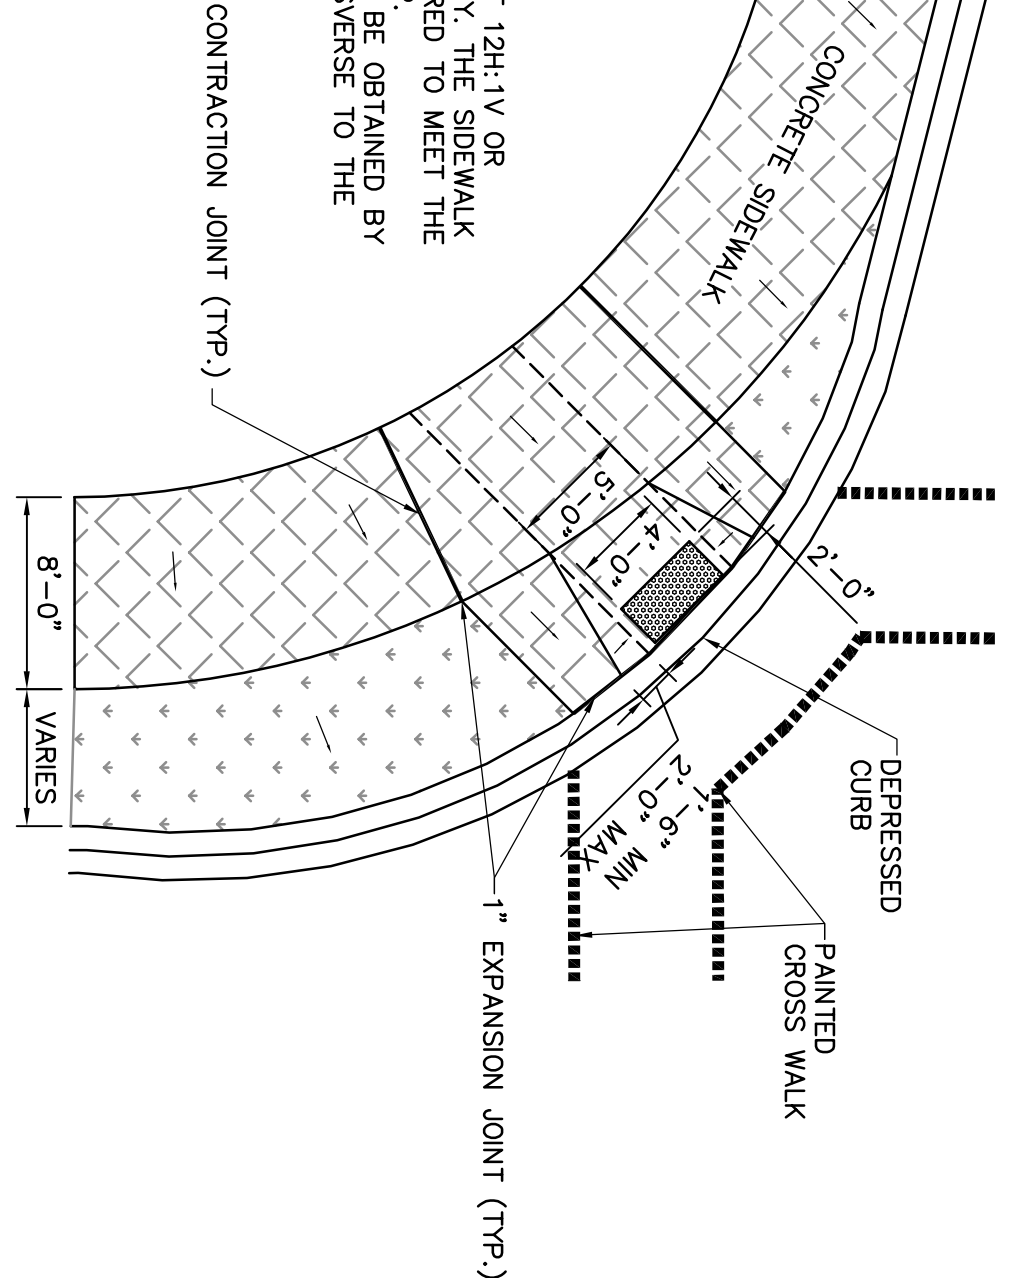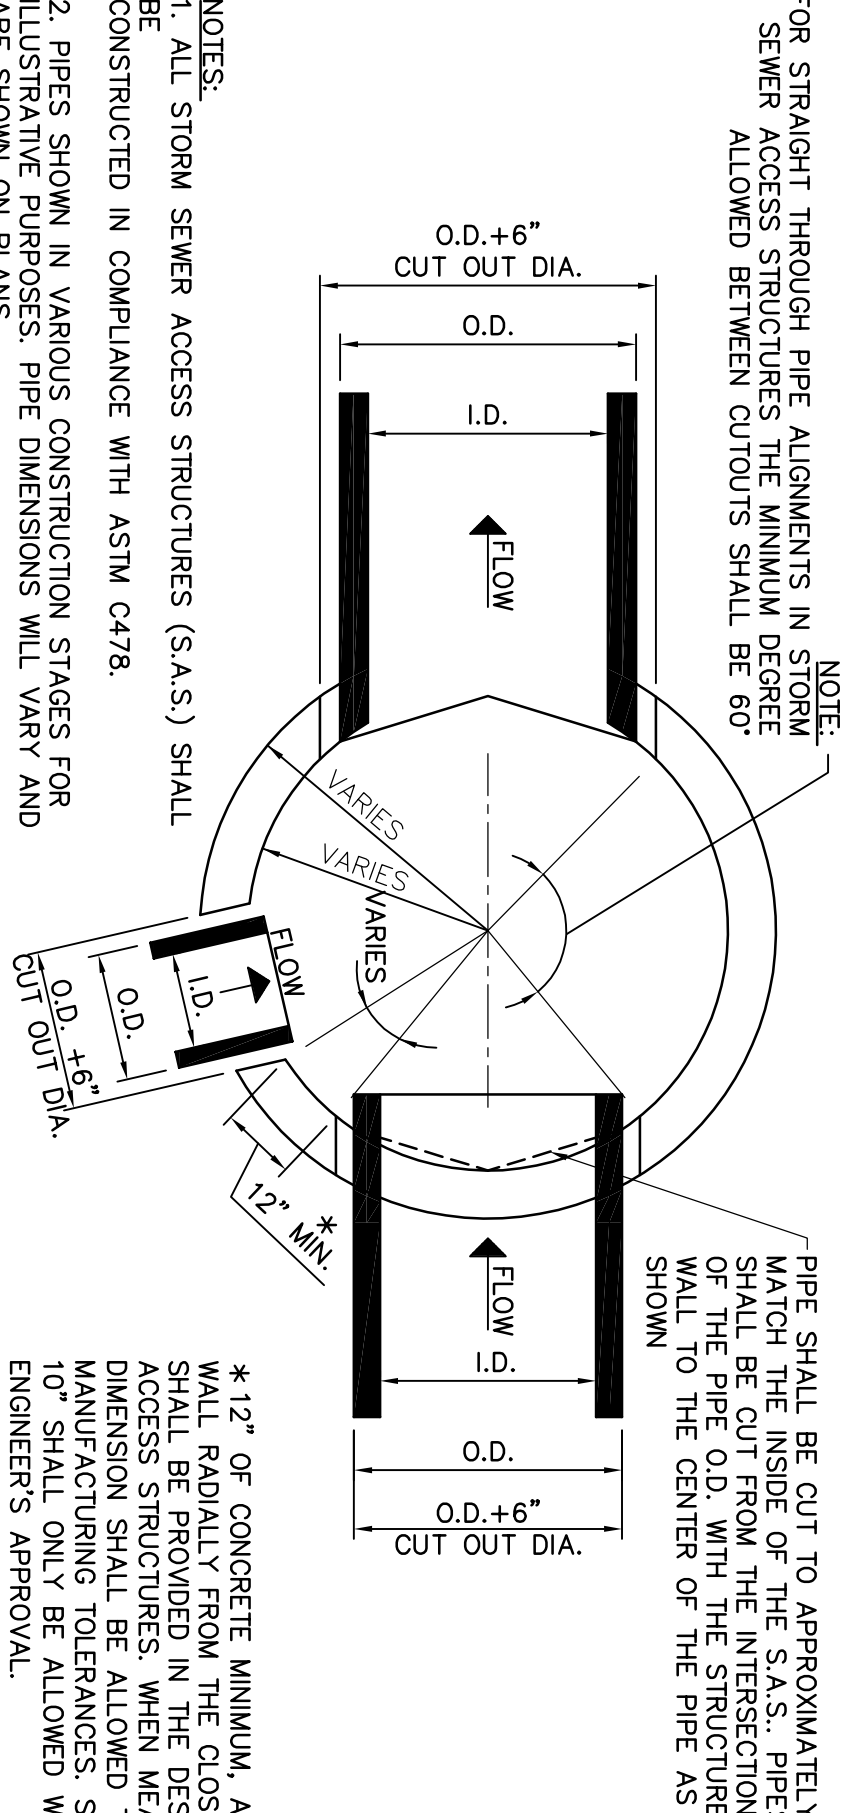STORM SEWER PRECAST S.A.S.
(TOP VIEW)

- NOTE:
FOR STRAIGHT THROUGH PIPE ALIGNMENTS IN STORM SEWER ACCESS STRUCTURES THE MINIMUM DEGREE ALLOWED BETWEEN CUTOUTS SHALL BE 60°
- PIPE SHALL BE CUT TO APPROXIMATELY HALF THE THICKNESS OF THE S.A.S. RINGS OF THE PIPE O.D. WITH THE INTERSECTION WALL TO THE CENTER OF THE PIPE AS SHOWN

- NOTES:
1. ALL STORM SEWER ACCESS STRUCTURES (S.A.S.) SHALL BE CONSTRUCTED IN COMPLIANCE WITH ASTM C478.
 2. PIPES SHOWN IN VARIOUS CONSTRUCTION STAGES FOR ILLUSTRATIVE PURPOSES. PIPE DIMENSIONS WILL VARY AND ARE SHOWN ON PLANS



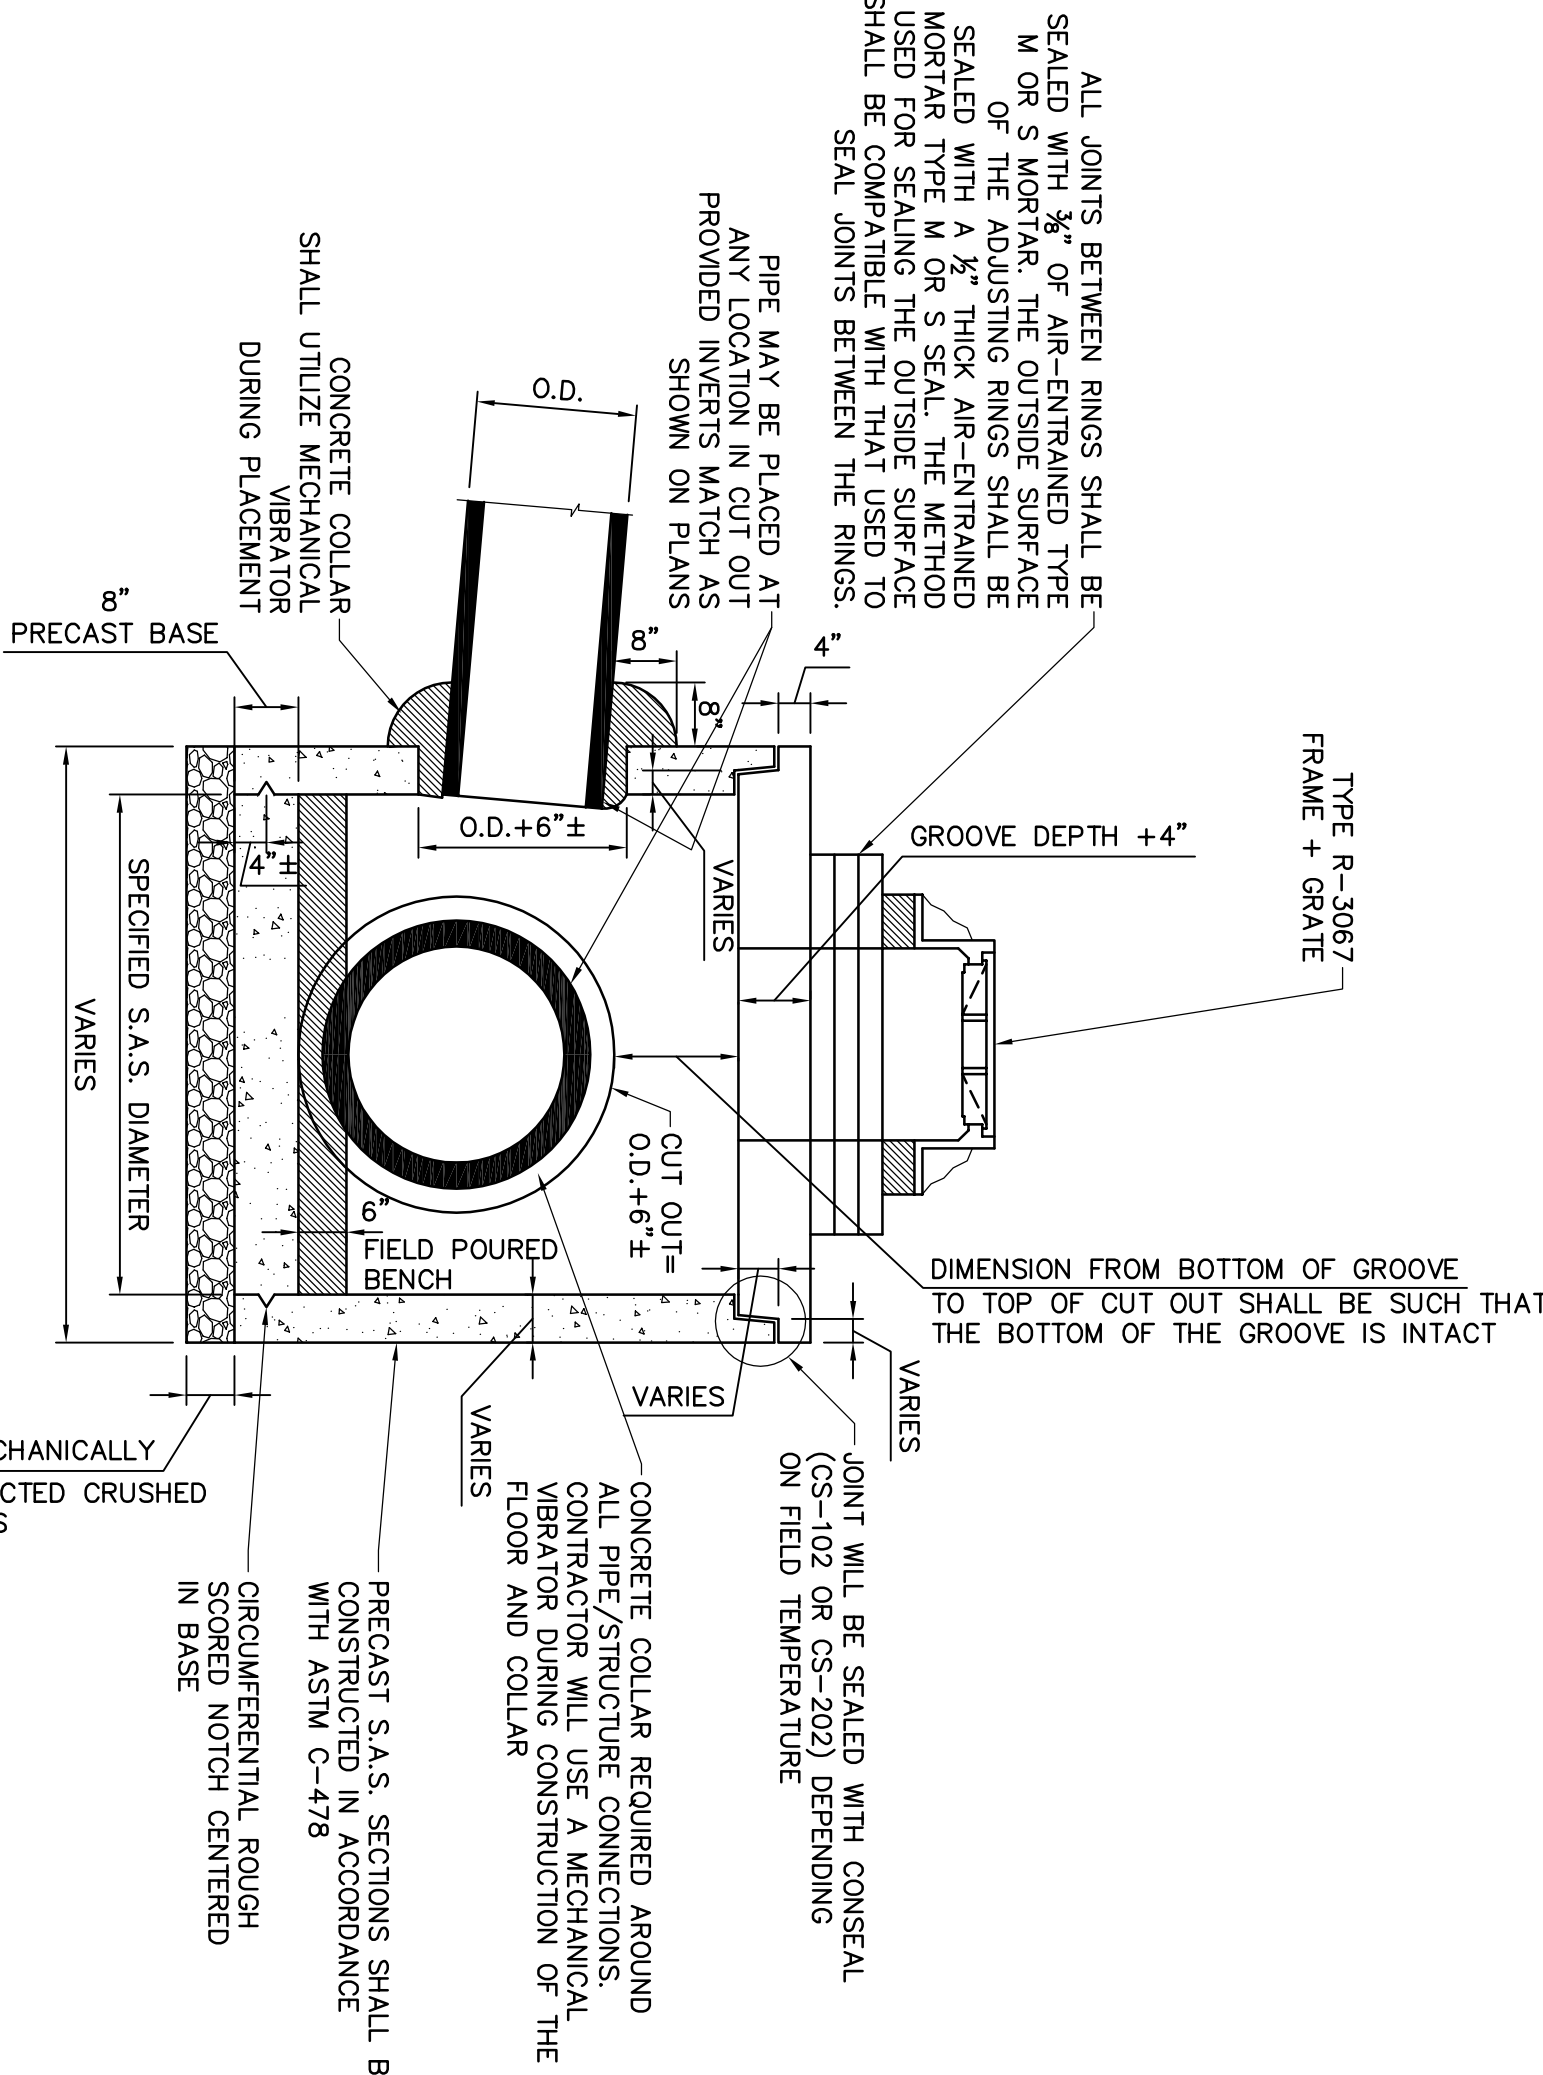
STORM SEWER PRECAST
SEWER ACCESS STRUCTURE (S.A.S.)
(THROUGH SECTION VIEW)

- NOTES:
1. RAMP SHALL BE BUILT AT 124.1V OR FATTER WHEN NECESSARY. THE SIDEWALK ELEVATION MAY BE LOWERED TO MEET THE HIGH POINT OF THE RAMP.
 2. SURFACE TEXTURE SHALL BE OBTAINED BY COARSE BROOKING TRANSVERSE TO THE SLOPE OF THE RAMP.


CONTRACTION JOINT (TTP)

MODIFIED TYPE 1 RAMP

(AT N. MILLS AND W. DAYTON CROSSING)

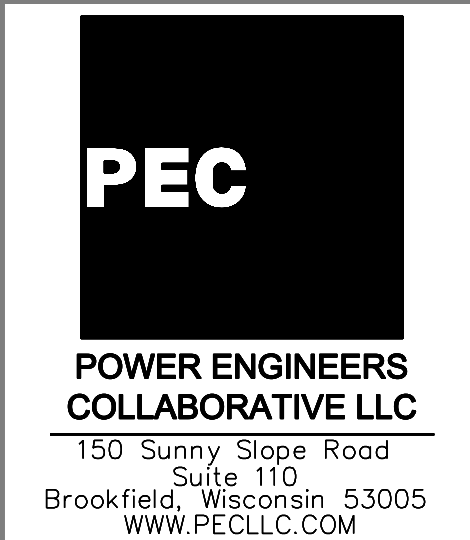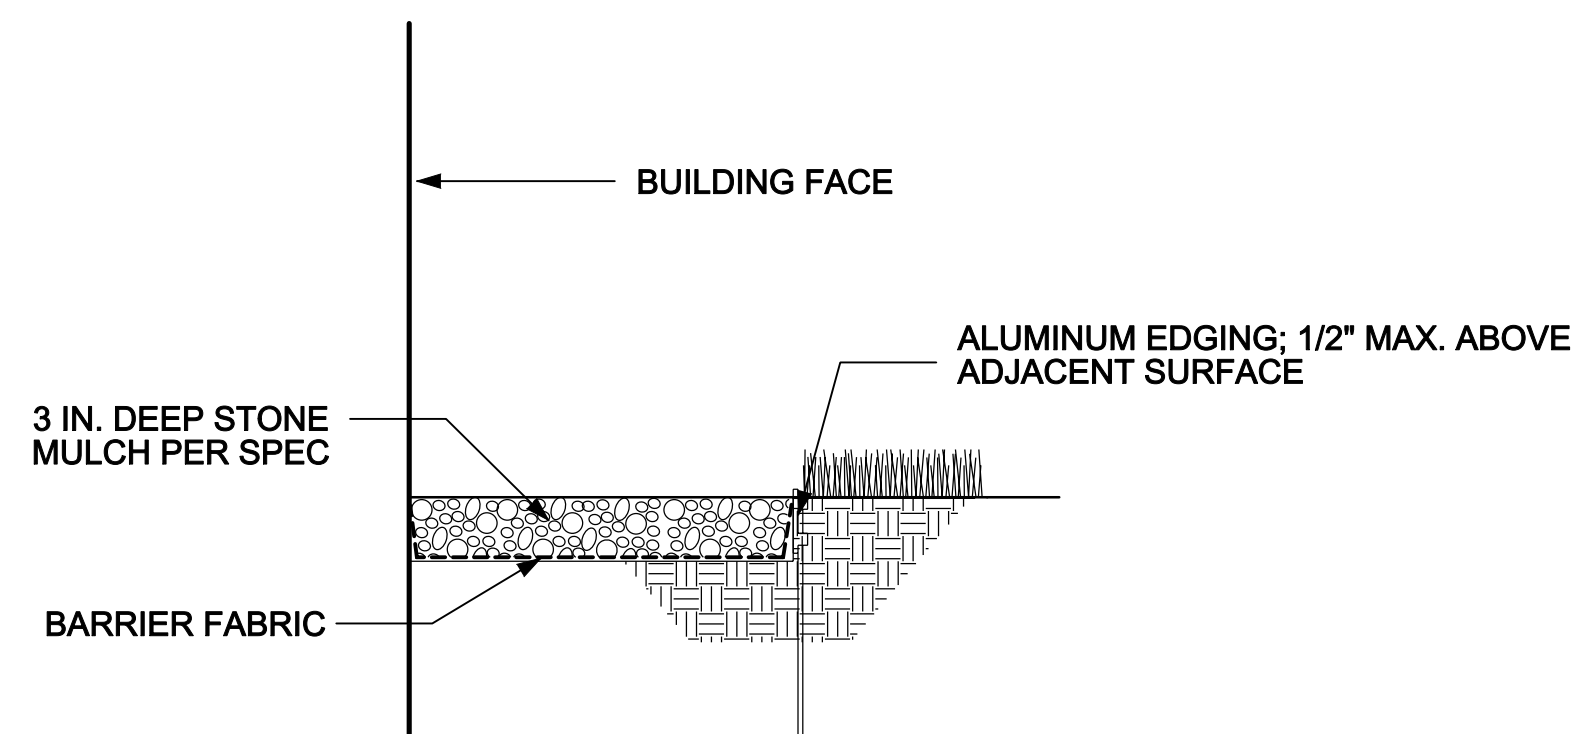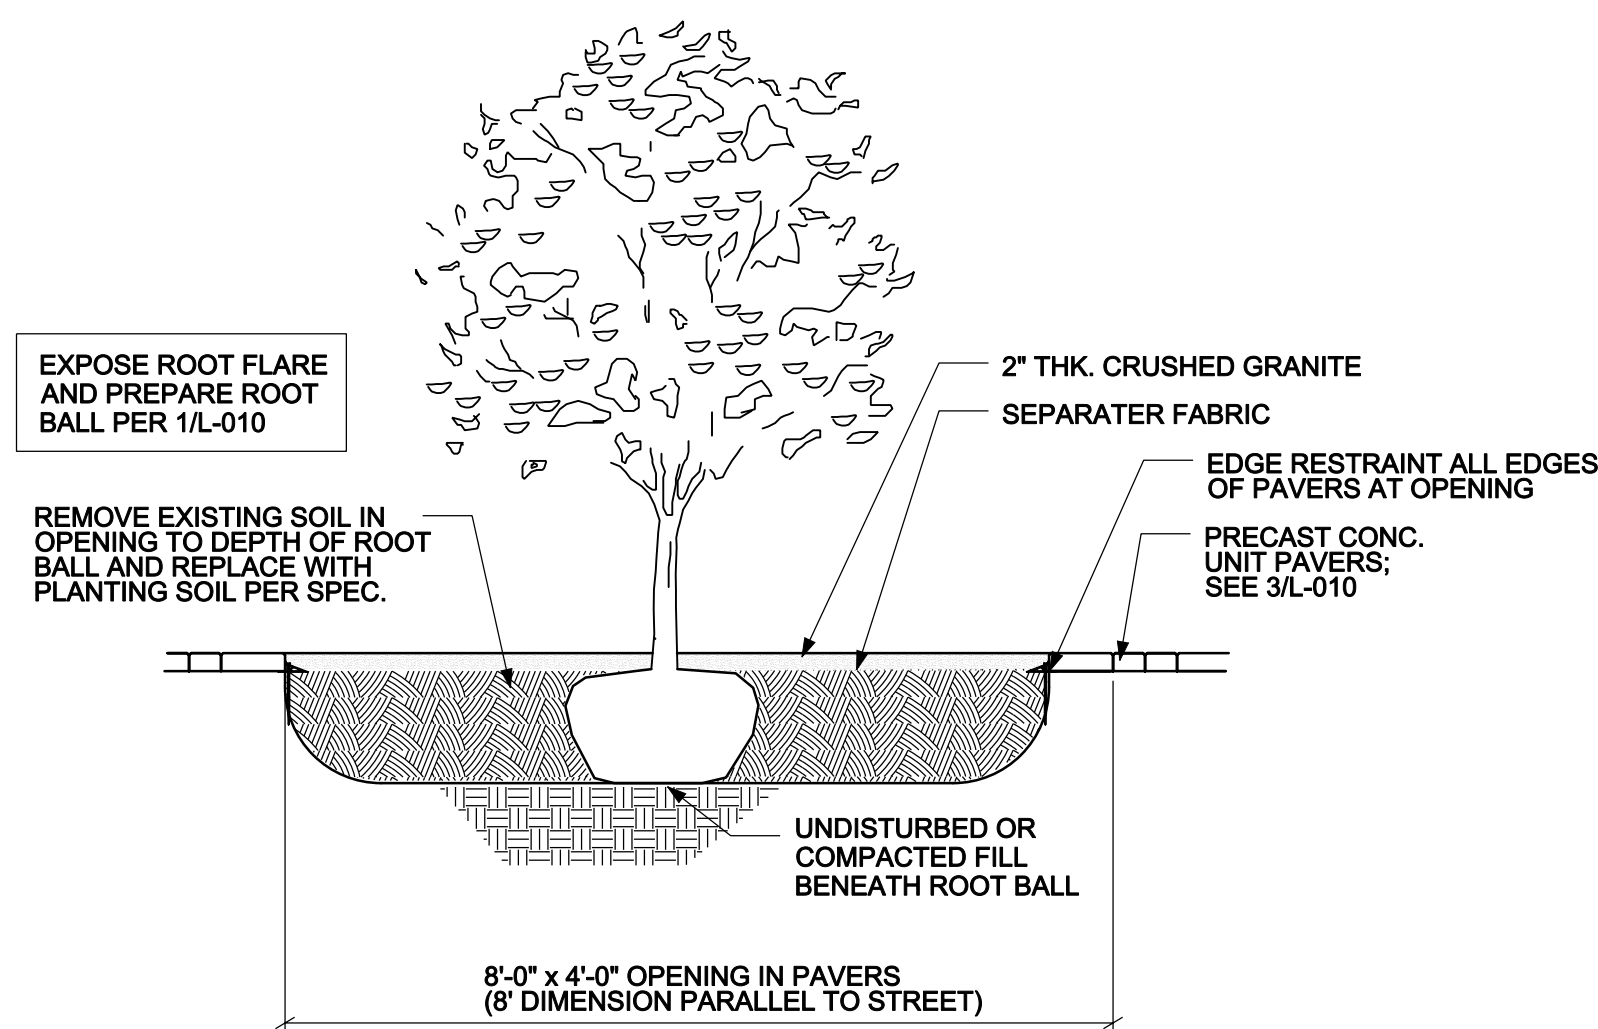

State of Wisconsin
Department of Administration
Division of State Facilities

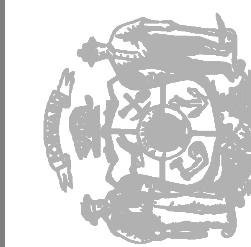Agency / Institution:
UNIVERSITY OF WISCONSIN, MADISON

Project Title: CHARTER STREET REBUILD

Project Location:
MADISON, WI.


Sheet Title:

Revisions:

[illegible]

Graphic Scale	
DSF Number	09A2L
Set Type	SIP 1
Date Issued	05-24-10
Sheet Number	L-010



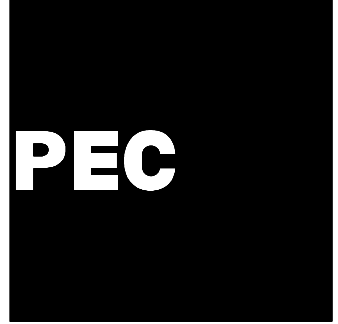


POWER ENGINEERS
COLLABORATIVE LLC
150 Sunny Slope Road
Suite 110
Brookfield, Wisconsin 53005
WWW.PECLLC.COM



PLT Project No:
2009.07.00

State of Wisconsin
Department of Administration
Division of State Facilities

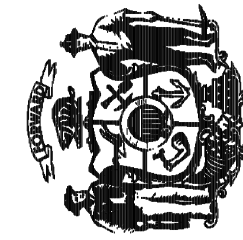

Agency / Institution:
UNIVERSITY OF WISCONSIN SYSTEM


CHARTER STREET REBUILD
MADISON, WI
SITE REFERENCE PLAN

Project Title:
Project Location:
Sheet Title:

Revisions:

No.	Date:	By:	Description:


Graphic Scale	
DSF Number	09A2L
Set Type	PR
Date Issued	05-24-10
Sheet Number	A100

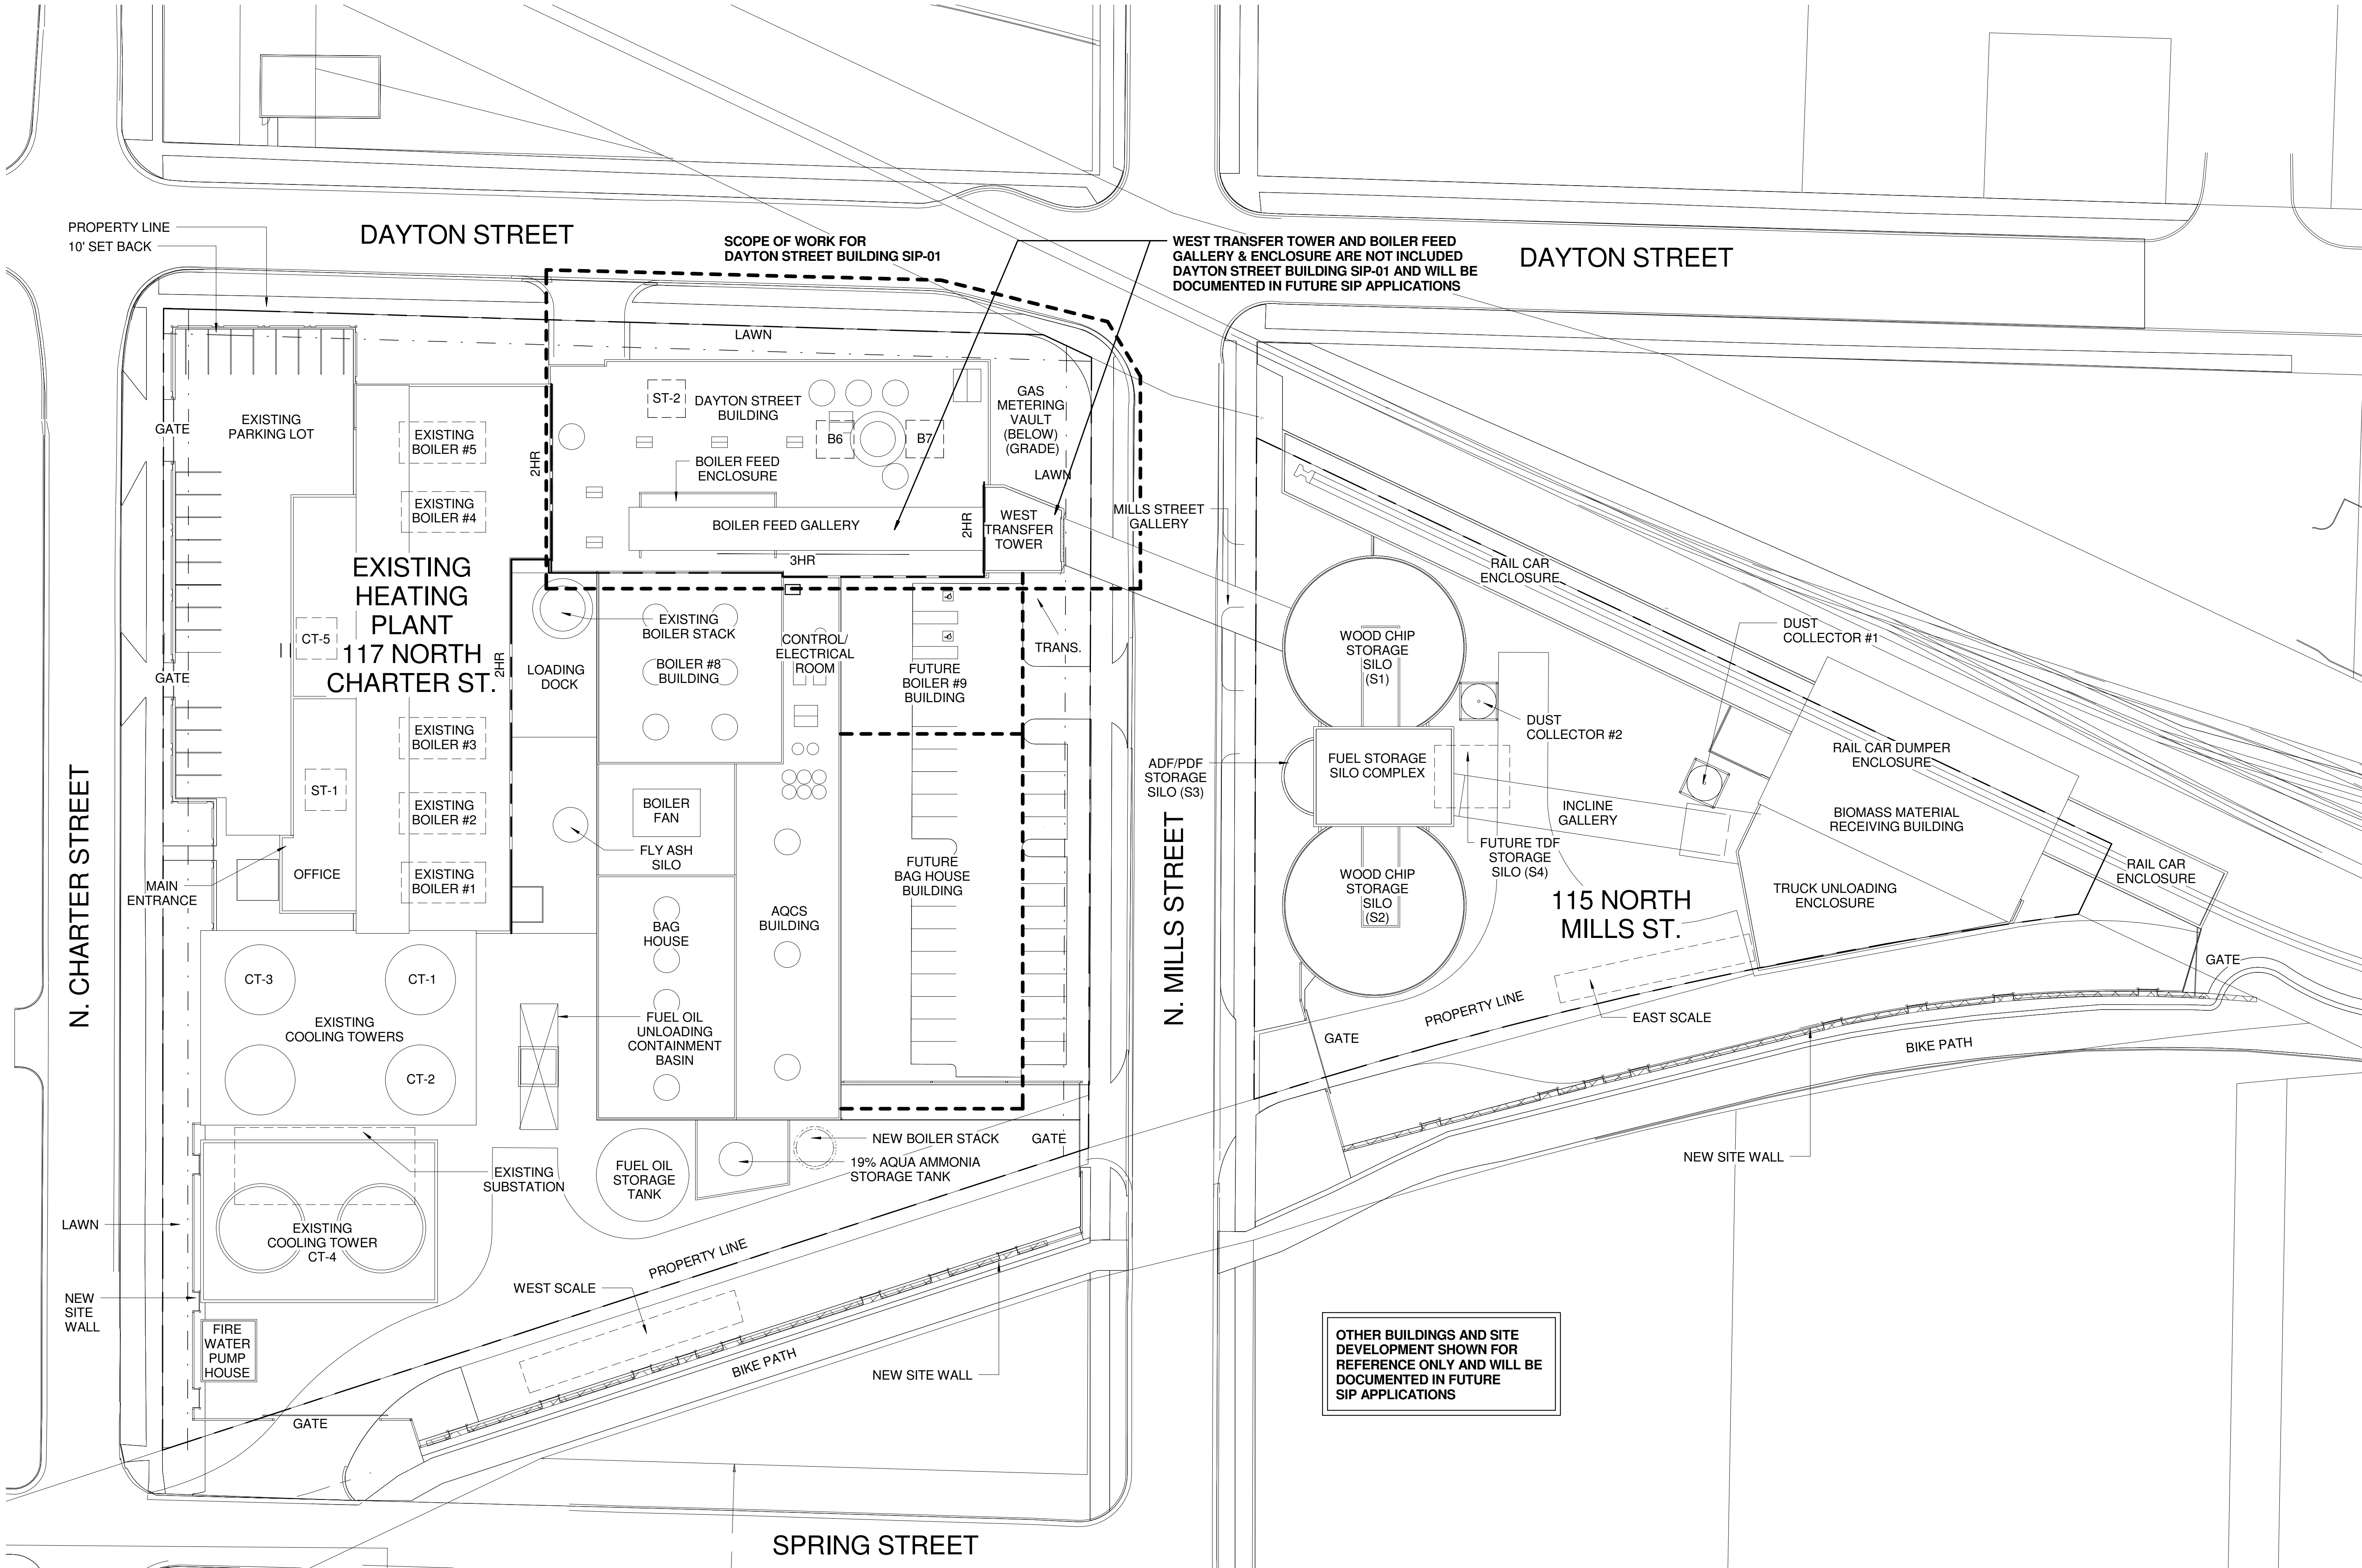


1
A100

OVERALL SITE REFERENCE PLAN
1" = 30'-0"



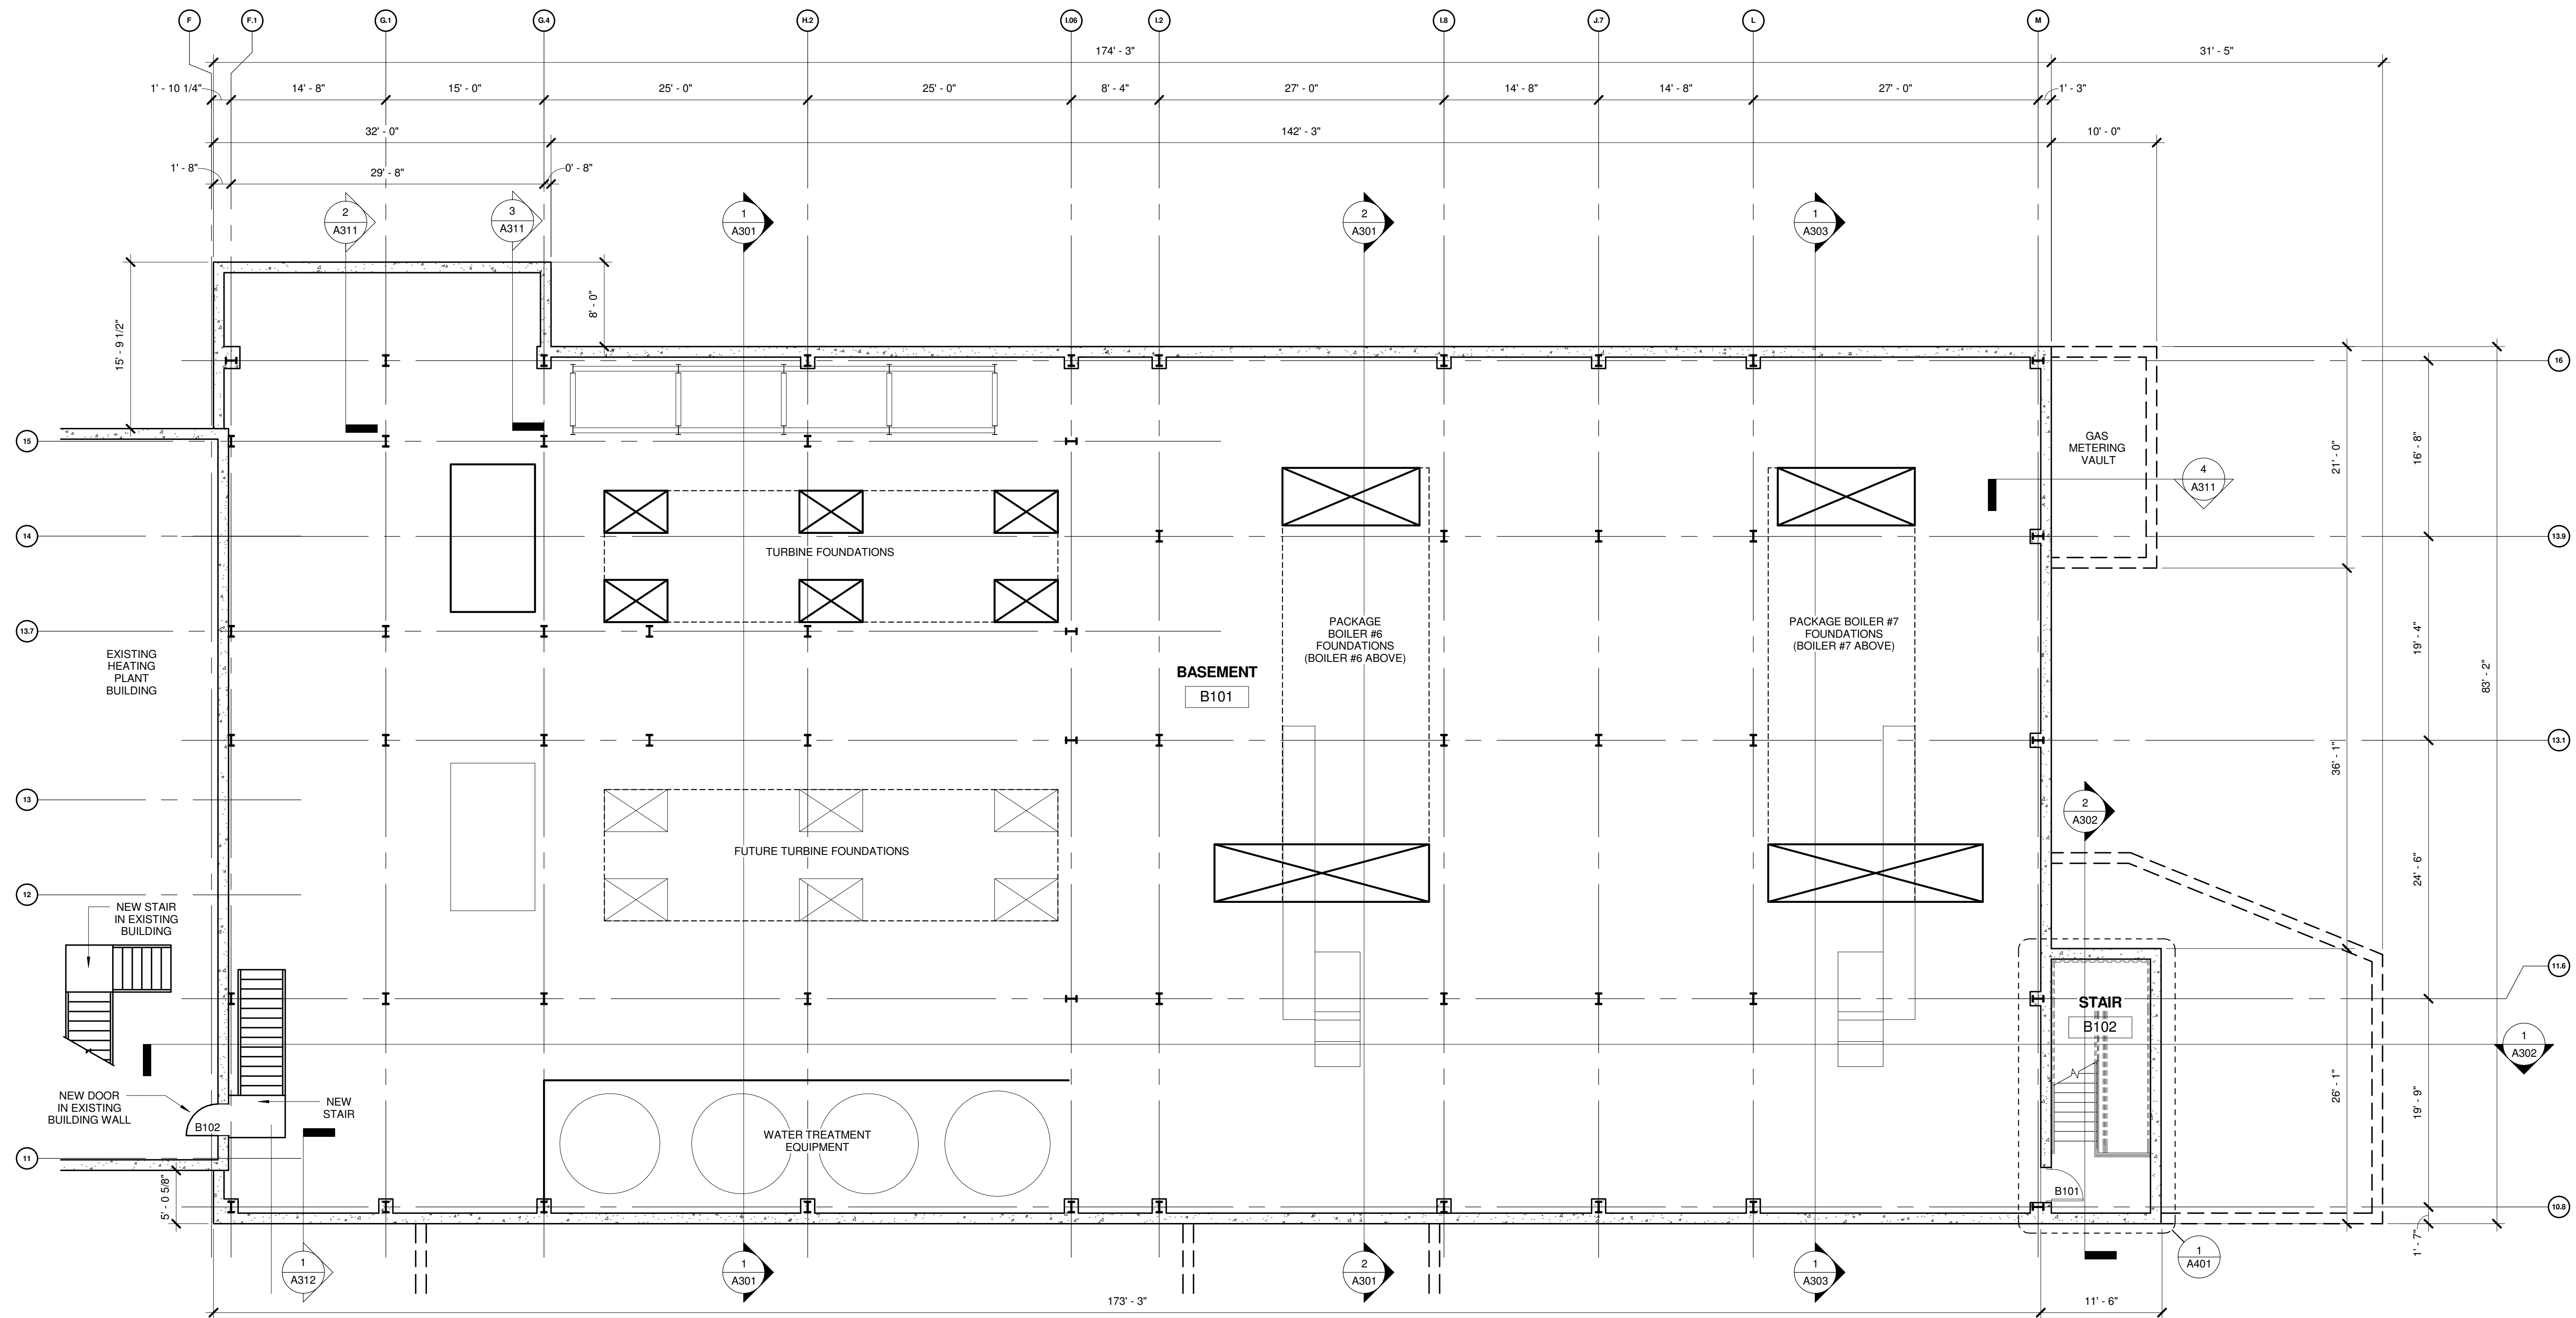

1 BASEMENT FLOOR PLAN
A101 1/8" = 1'-0" 

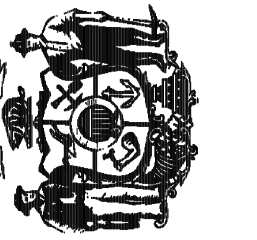

CHARIERS STREET REBUILD

MADISON, WI

THE FIRST LOOK AT LAIN

visions:

[illegible]


Graphic	
ale	

Number	09A2L
--------	-------

PR	
----	--

te ued	05-24-10
-----------	----------

Sheet Number	A102
-----------------	-------------

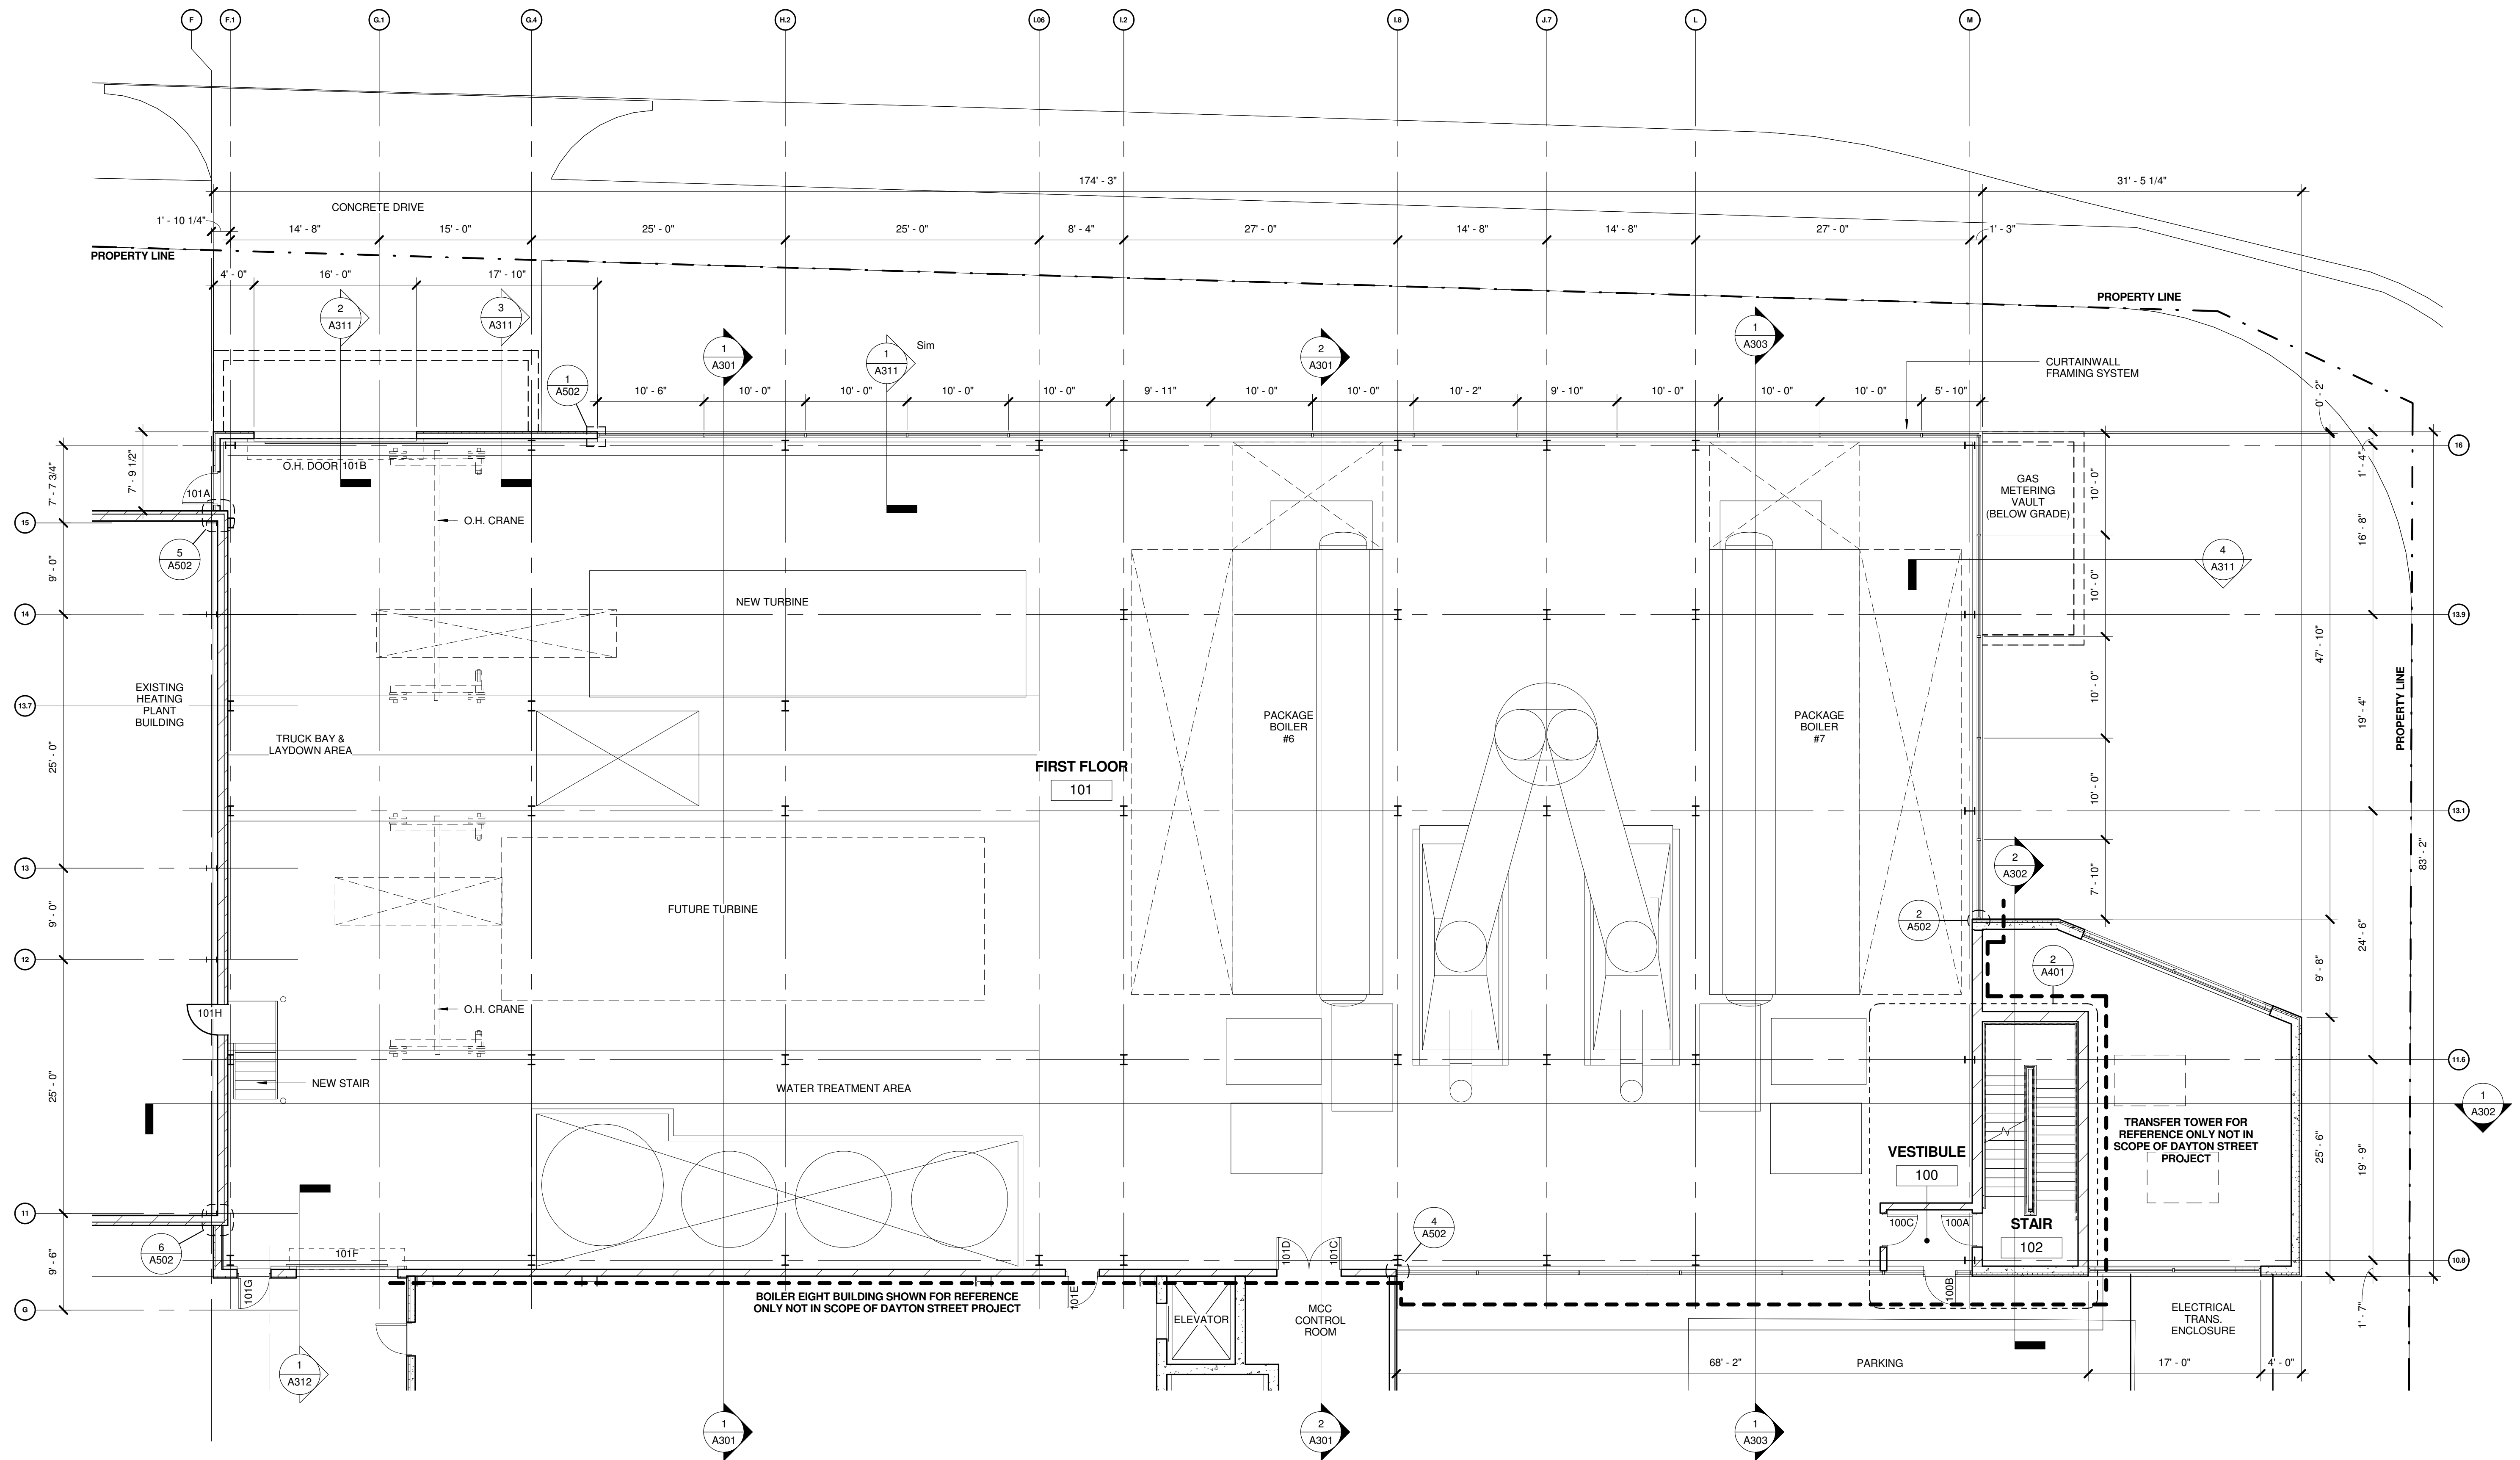

2 FIRST FLOOR PLAN
A102 1/8" = 1'-0"





niddough

Project No:
2009.07.00

UNIVERSITY OF WISCONSIN SYSTEM

MADISON, WI

SECOND FLOOR PLAN

1000

Revisions:

[illegible]

Graphic
Scale


OSF Number	09A2L
------------	-------

Get type	PR
----------	----

Date issued	05-24-10
-------------	----------


Sheet

A103

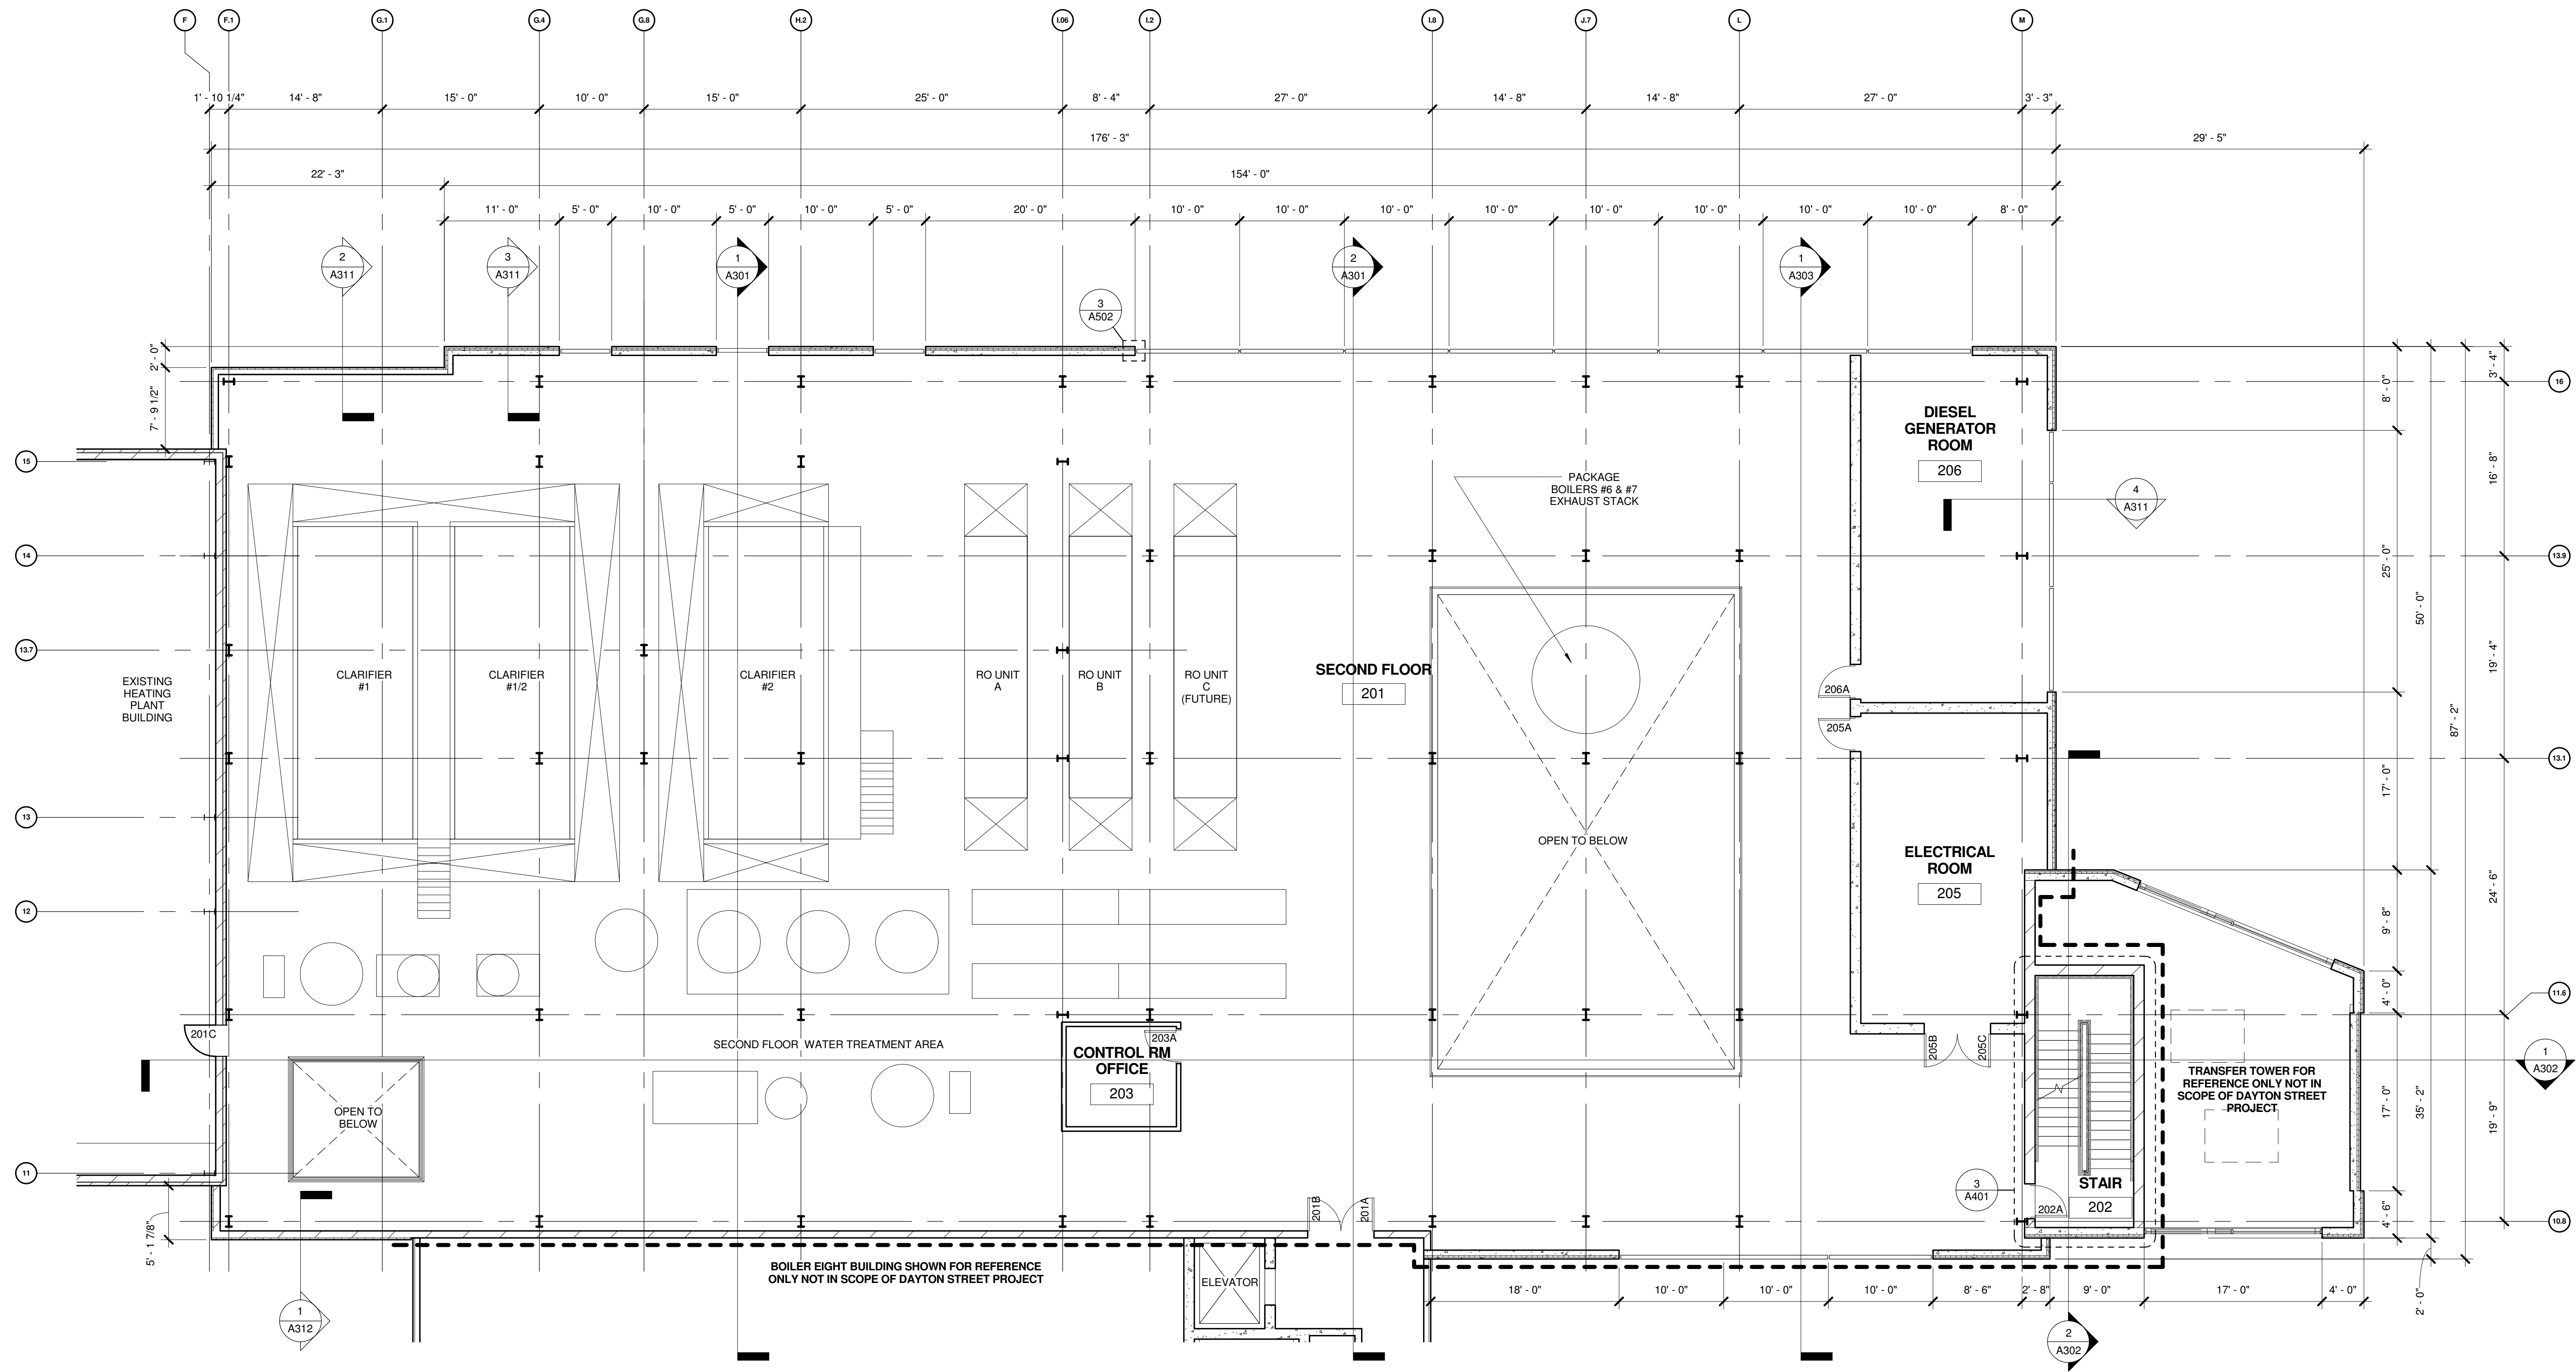

1 SECOND FLOOR PLAN
A103 1/8" = 1'-0"



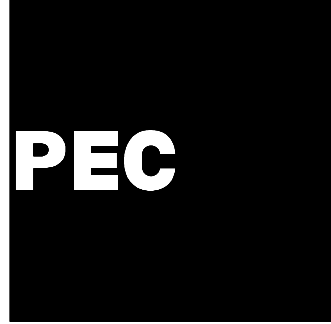


POWER ENGINEERS
COLLABORATIVE LLC
150 Sunny Slope Road
Suite 110
Brookfield, Wisconsin 53005
WWW.PECLLC.COM



PLI Project No:
2009.07.00

State of Wisconsin
Department of Administration
Division of State Facilities

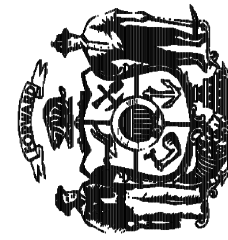

Agency/Institution:
UNIVERSITY OF WISCONSIN SYSTEM

CHARTER STREET REBUILD

MADISON, WI

ROOF PLANS

Project Title:

Project Location:

Sheet Title:

Revisions:

No.	Date:	By:	Description:

Graphic
Scale

DSF
Number

Set
Type

Date
Issued



Sheet
Number

09A2L


PR

05-24-10

A104

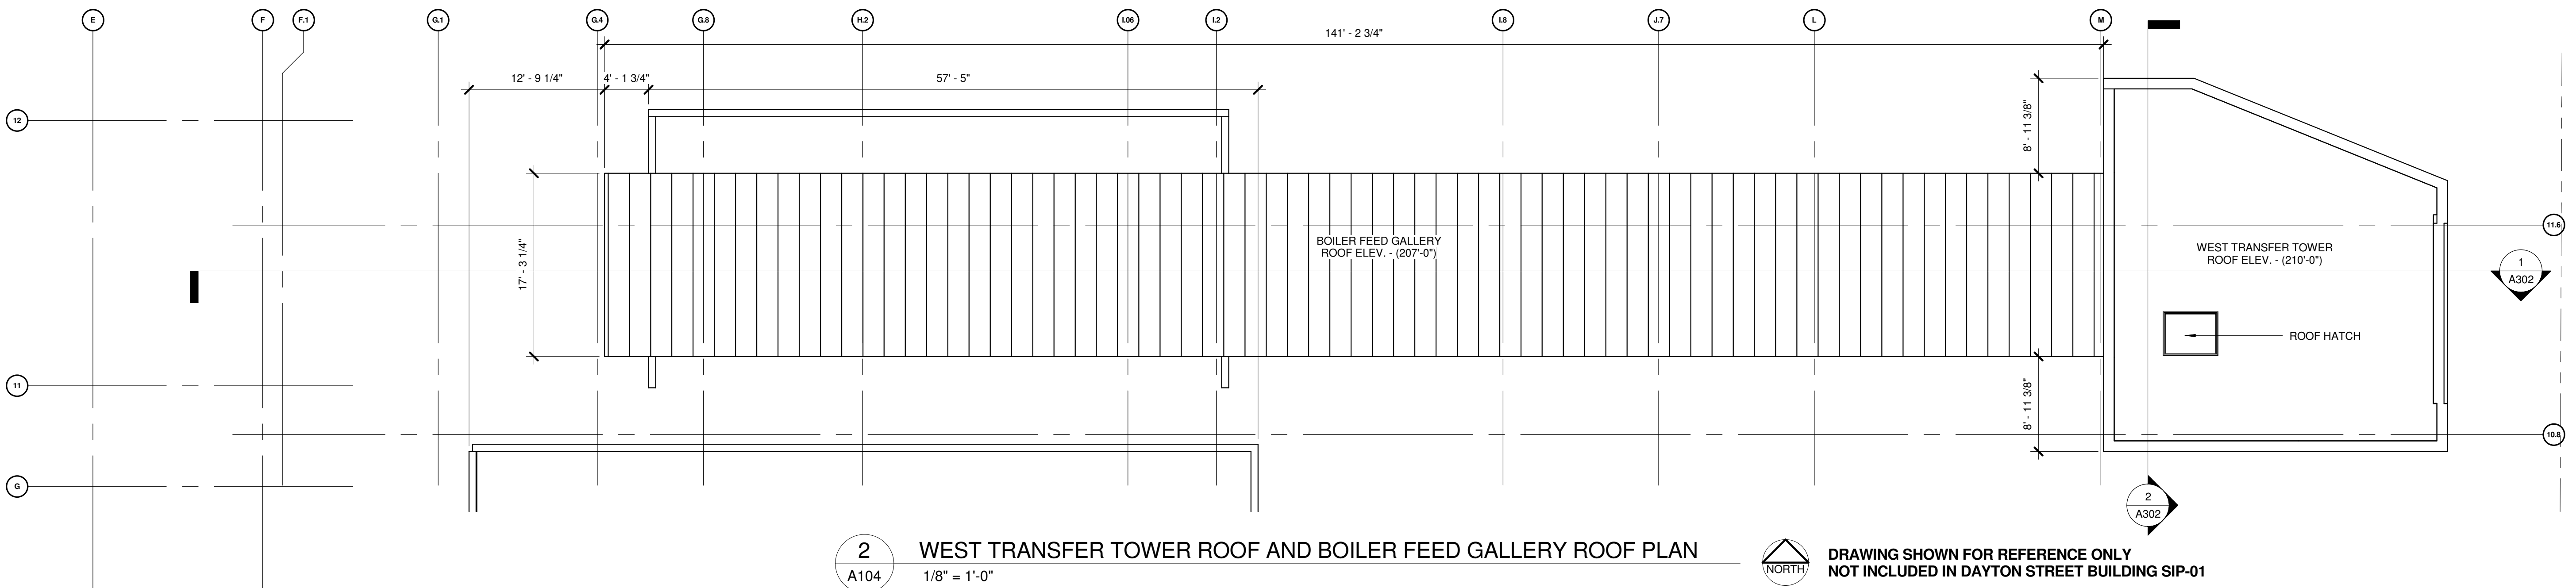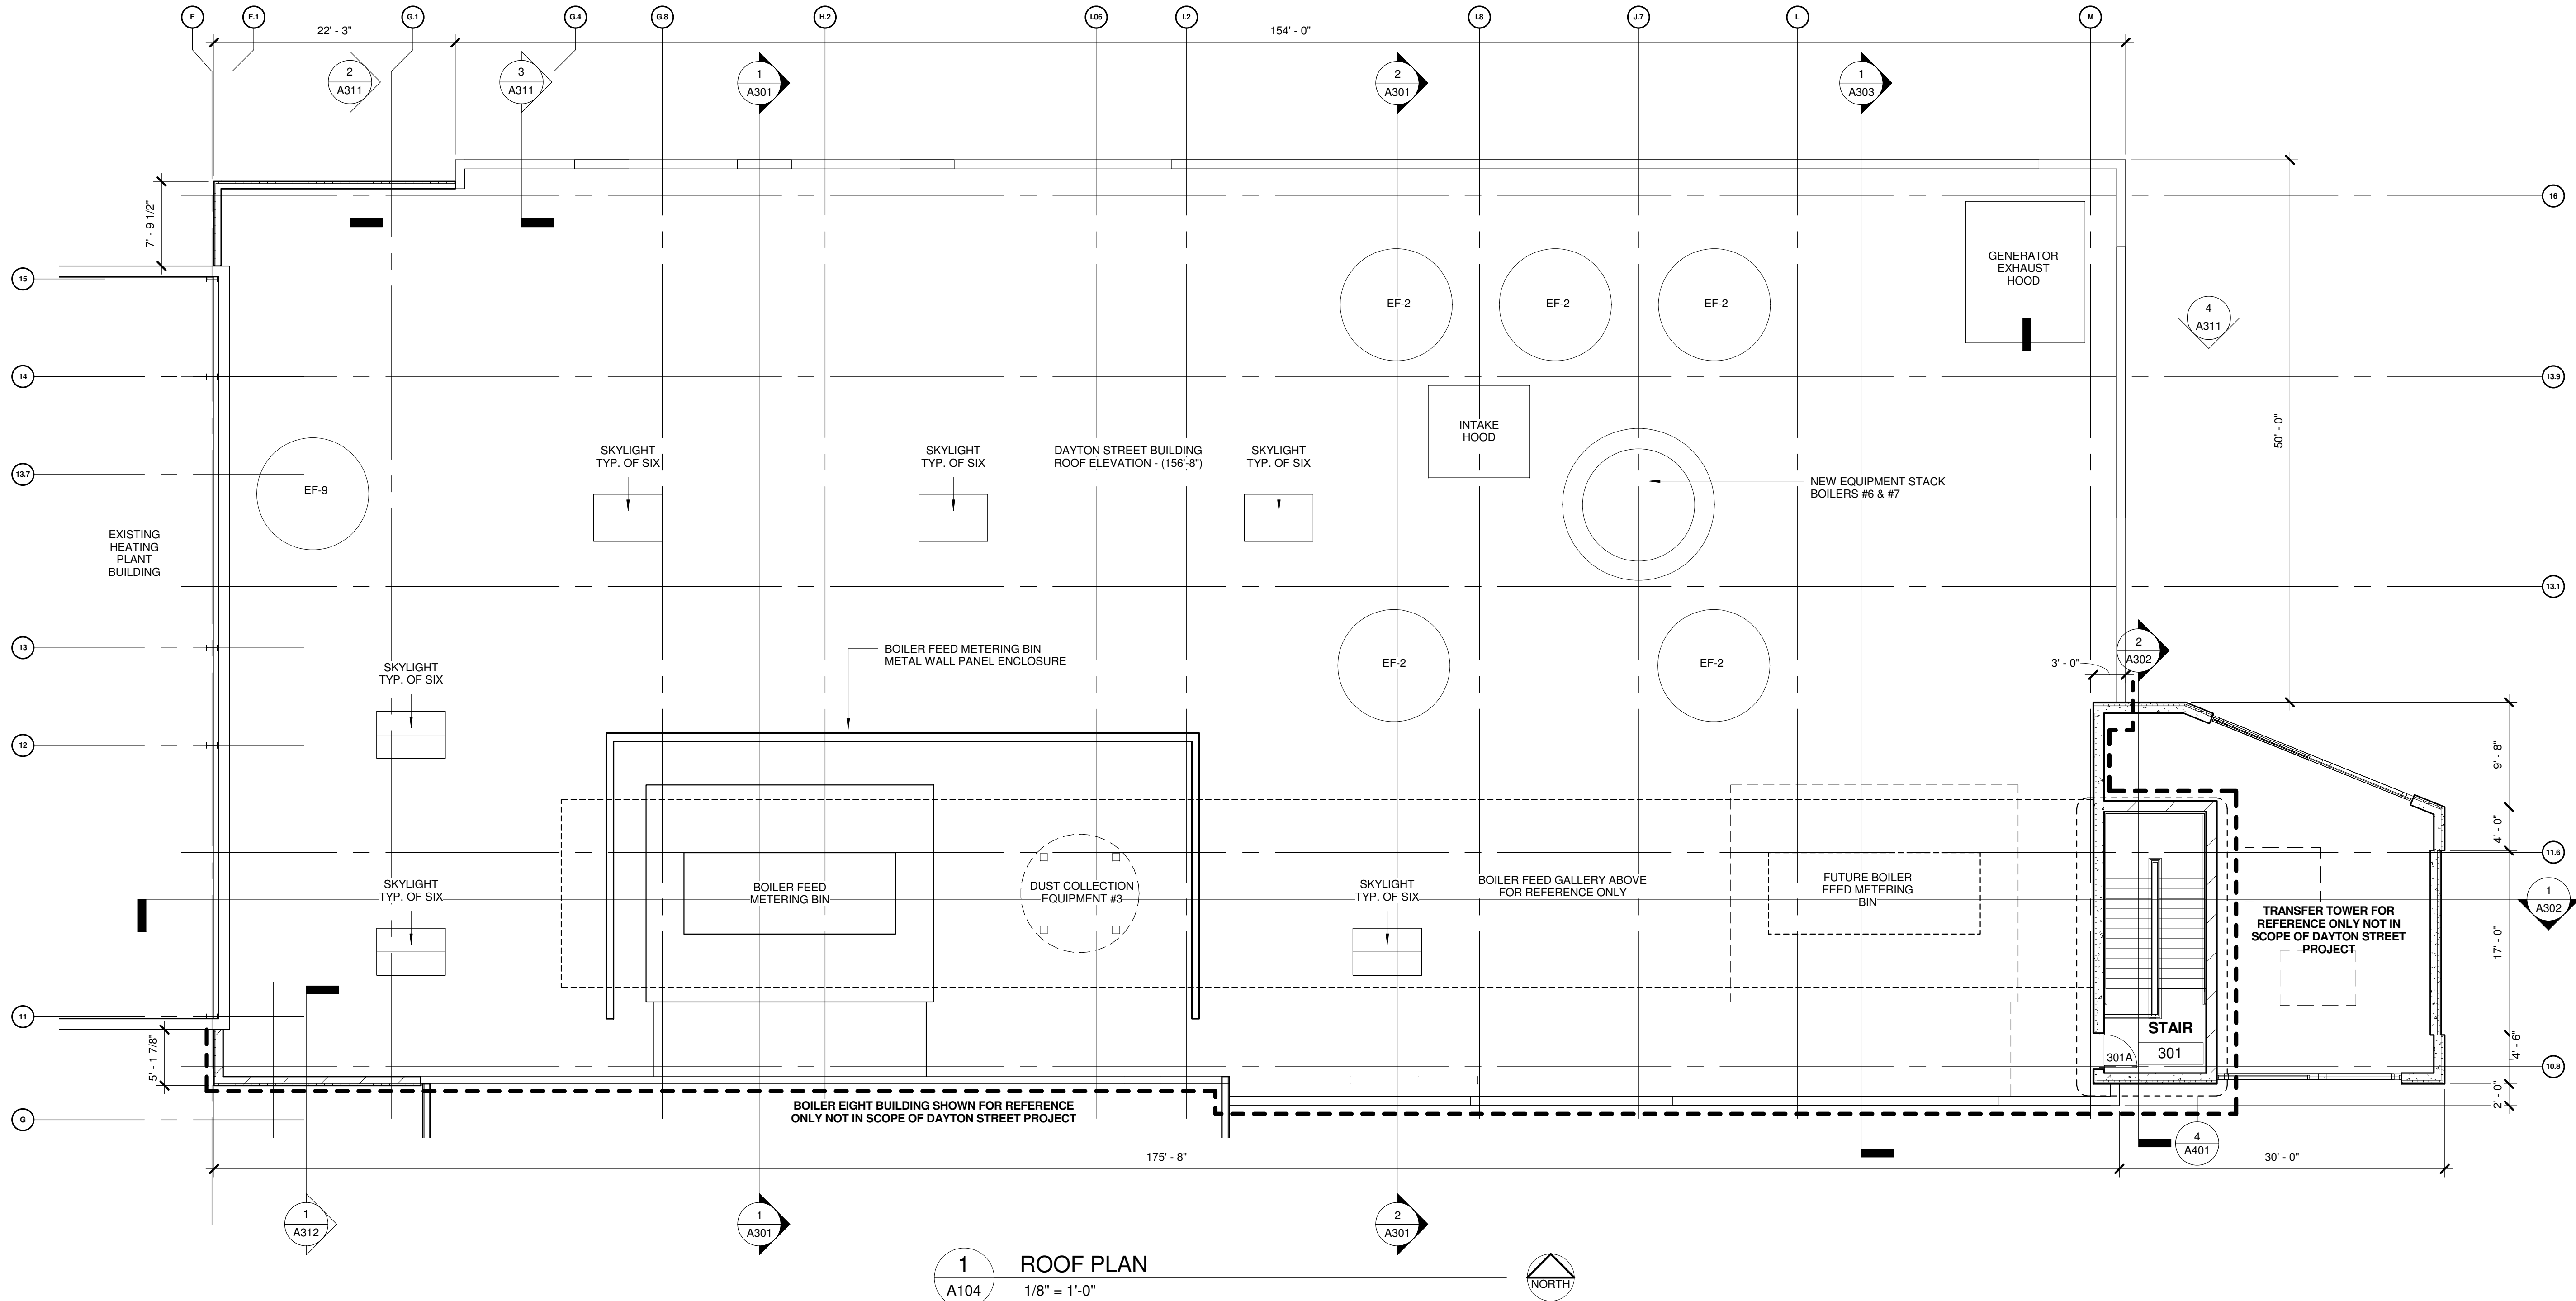

DRAWING SHOWN FOR REFERENCE ONLY
NOT INCLUDED IN DAYTON STREET BUILDING SIP-01

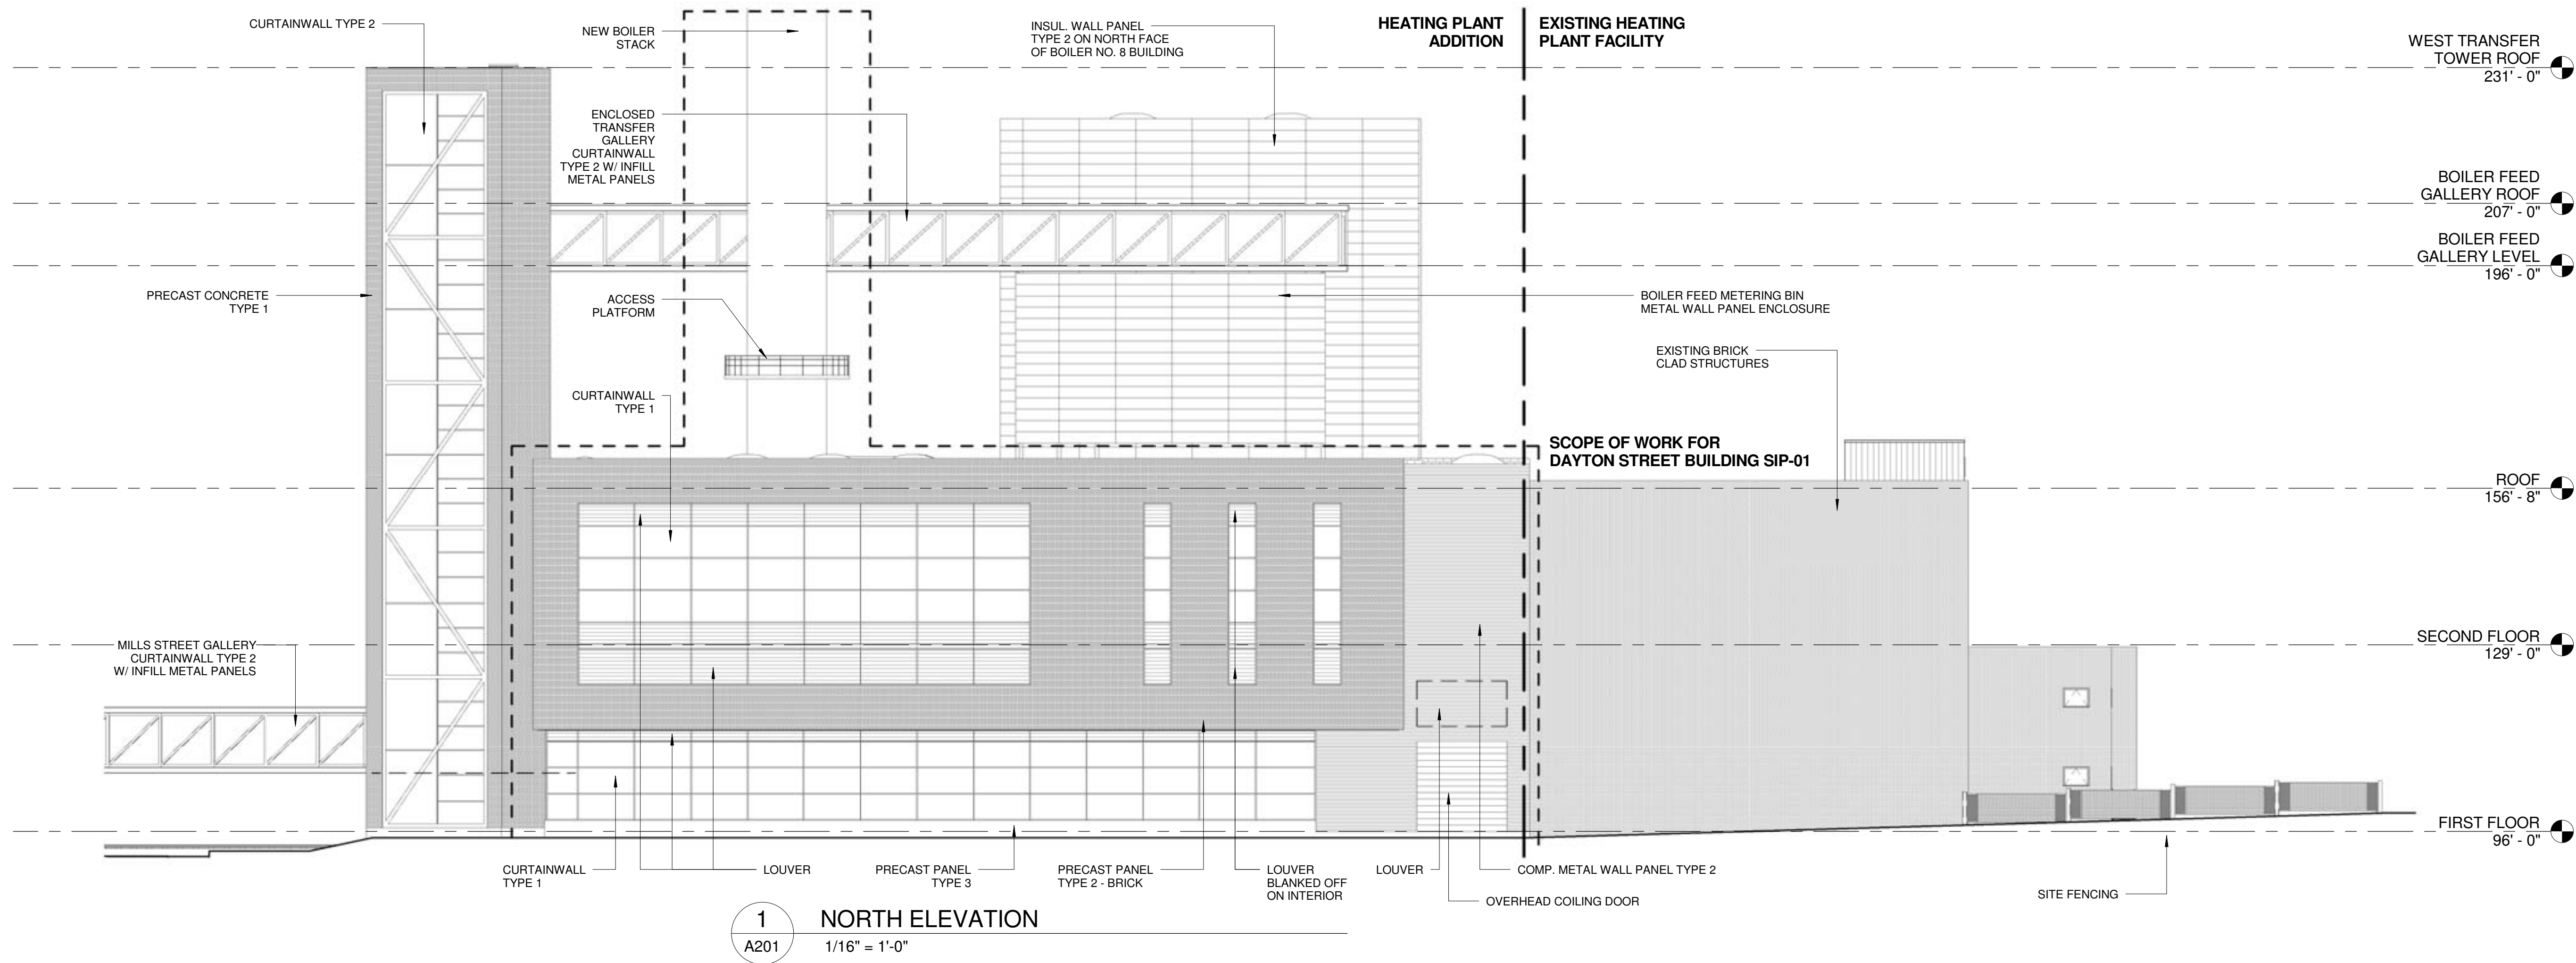

MATERIAL LEGEND

PRECAST CONCRETE TYPES

TYPE 1 - INSULATED WALL PANEL WITH 2" RIGID INSULATION AND 2" EXTERIOR ARCHITECTURAL WYTH FACED WITH BRICK TYPE 1

TYPE 2 - INSULATED WALL PANEL WITH 2" RIGID INSULATION AND 2" EXTERIOR ARCHITECTURAL WYTH FACED WITH BRICK TYPE 2

TYPE 3 - INSULATED WALL PANEL WITH 2" RIGID INSULATION AND 2" EXTERIOR ARCHITECTURAL CONCRETE WYTH 2'X10" REVEAL PATTERN

COMPOSITE METAL WALL PANEL TYPES

TYPE 1 - HORIZONTAL - B.O.D. CENTRIA EXPOSED FASTENER PROFILE SERIES SUPER RIB - "GRAY VELVET" FINISH OVER INSULATED METAL WALL PANEL TYPE 3 OR EQUAL

TYPE 2 - HORIZONTAL - B.O.D. CENTRIA EXPOSED FASTENER PROFILE SERIES BR5-36 "GRAY VELVET" FINISH OVER COMPOSITE WALL PANEL TYPE 3 OR EQUAL

INSULATED METAL WALL PANEL TYPES

TYPE 1 - 2'X10' HORIZONTAL - B.O.D. CENTRIA FORMAWALL DIMENSION SERIES 2" THICK NOMINAL FLAT - XL SILVER COLOR

TYPE 2 - 2'X10' HORIZONTAL - B.O.D. CENTRIA FORMAWALL DIMENSION SERIES 2" THICK NOMINAL FLAT - COLONEL RED COLOR

TYPE 3 - B.O.D. CENTRIA VERSAWALL 2" THICK NOMINAL FLAT PANEL OR EQUAL

STOREFRONT - ALUMINUM FRAMING TYPES

TYPE 1 - TYPICAL GLAZING CONDITION - SEE OTS 022 FOR DETAILS



TYPE 2 - SSG GLAZING OPTION AT RIBBON WINDOWS - SEE OTS-022 FOR DETAILS

CURTAINWALL - ALUMINUM FRAMING TYPES

TYPE 1 - TYPICAL CONDITION - SEE OTS 022 FOR DETAILS

TYPE 2 - GALLERY ENCLOSURES - SEE OTS 022 FOR DETAILS

TYPE 3 - RAIL HOPPER END WALLS - SEE OTS 022 FOR DETAILS

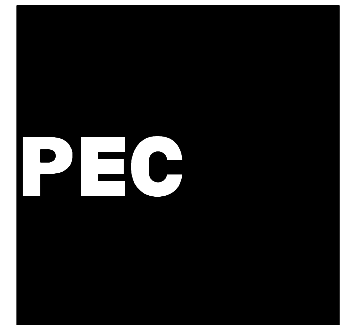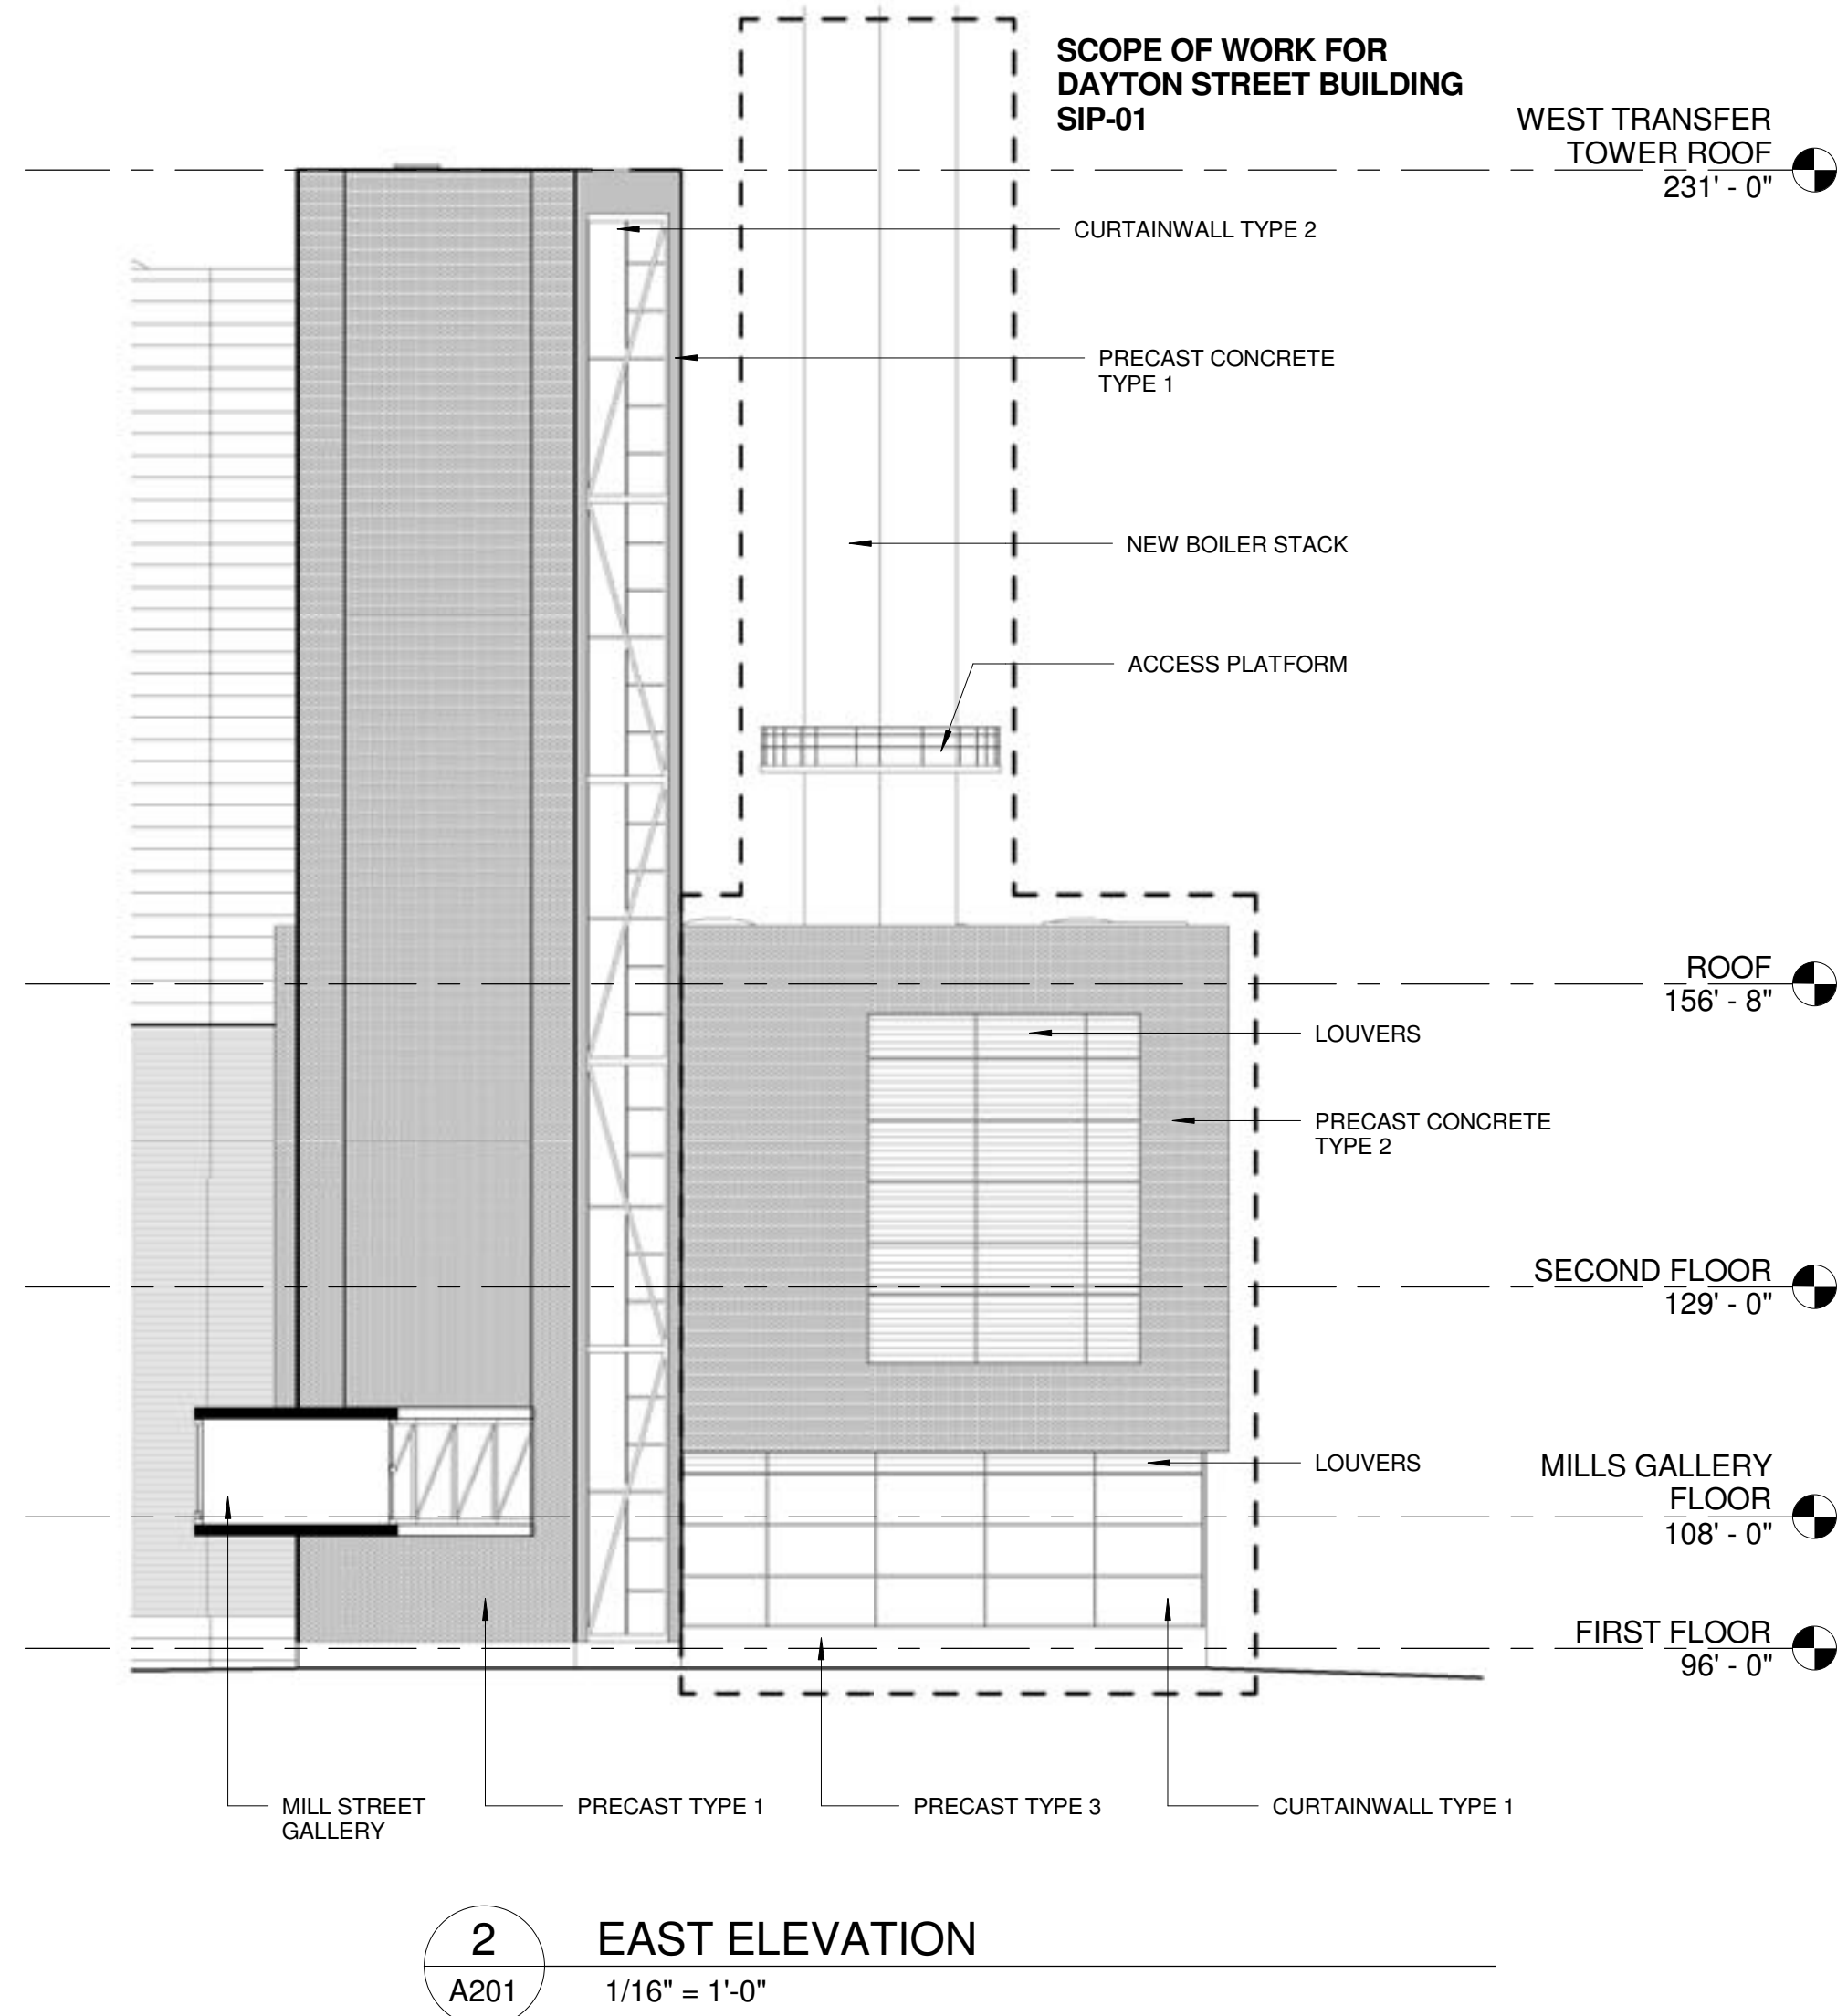


POWER ENGINEERS
COLLABORATIVE LLC
150 Sunny Slope Road
Suite 110
Brookfield, Wisconsin 53005
WWW.PECLLC.COM



PLI Project No:
2009.07.00

State of Wisconsin
Department of Administration
Division of State Facilities

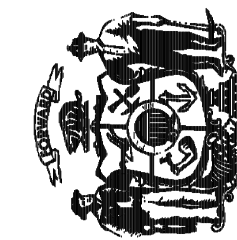

Agency / Institution:
UNIVERSITY OF WISCONSIN SYSTEM

CHARTER STREET REBUILD

MADISON, WI

BUILDING ELEVATIONS

Project Title:

Project Location:

Sheet Title:

Revisions:

No.	Date:	By:	Description:

Graphic Scale

DSF Number

09A2L

Set Type

PR

Date Issued

05-24-10

Sheet Number

A201



Potter Lawson


Project No:
2009.07.00

State of Wisconsin

Department of Administration

Division of State Facilities

SCONSIN SYSTEM

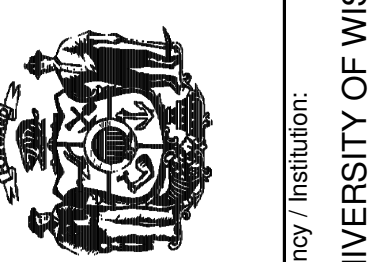

UNIVERSITY OF

CHARTER STREET REBUILD

MADISON, WI

BUILDING ELEVATIONS

Project Location: _____

Sheet Title: _____

visions:

[illegible]


phic	
le	

Number	09A2L
--------	-------


e	PR
---	----

05-24-10	
----------	--

A202

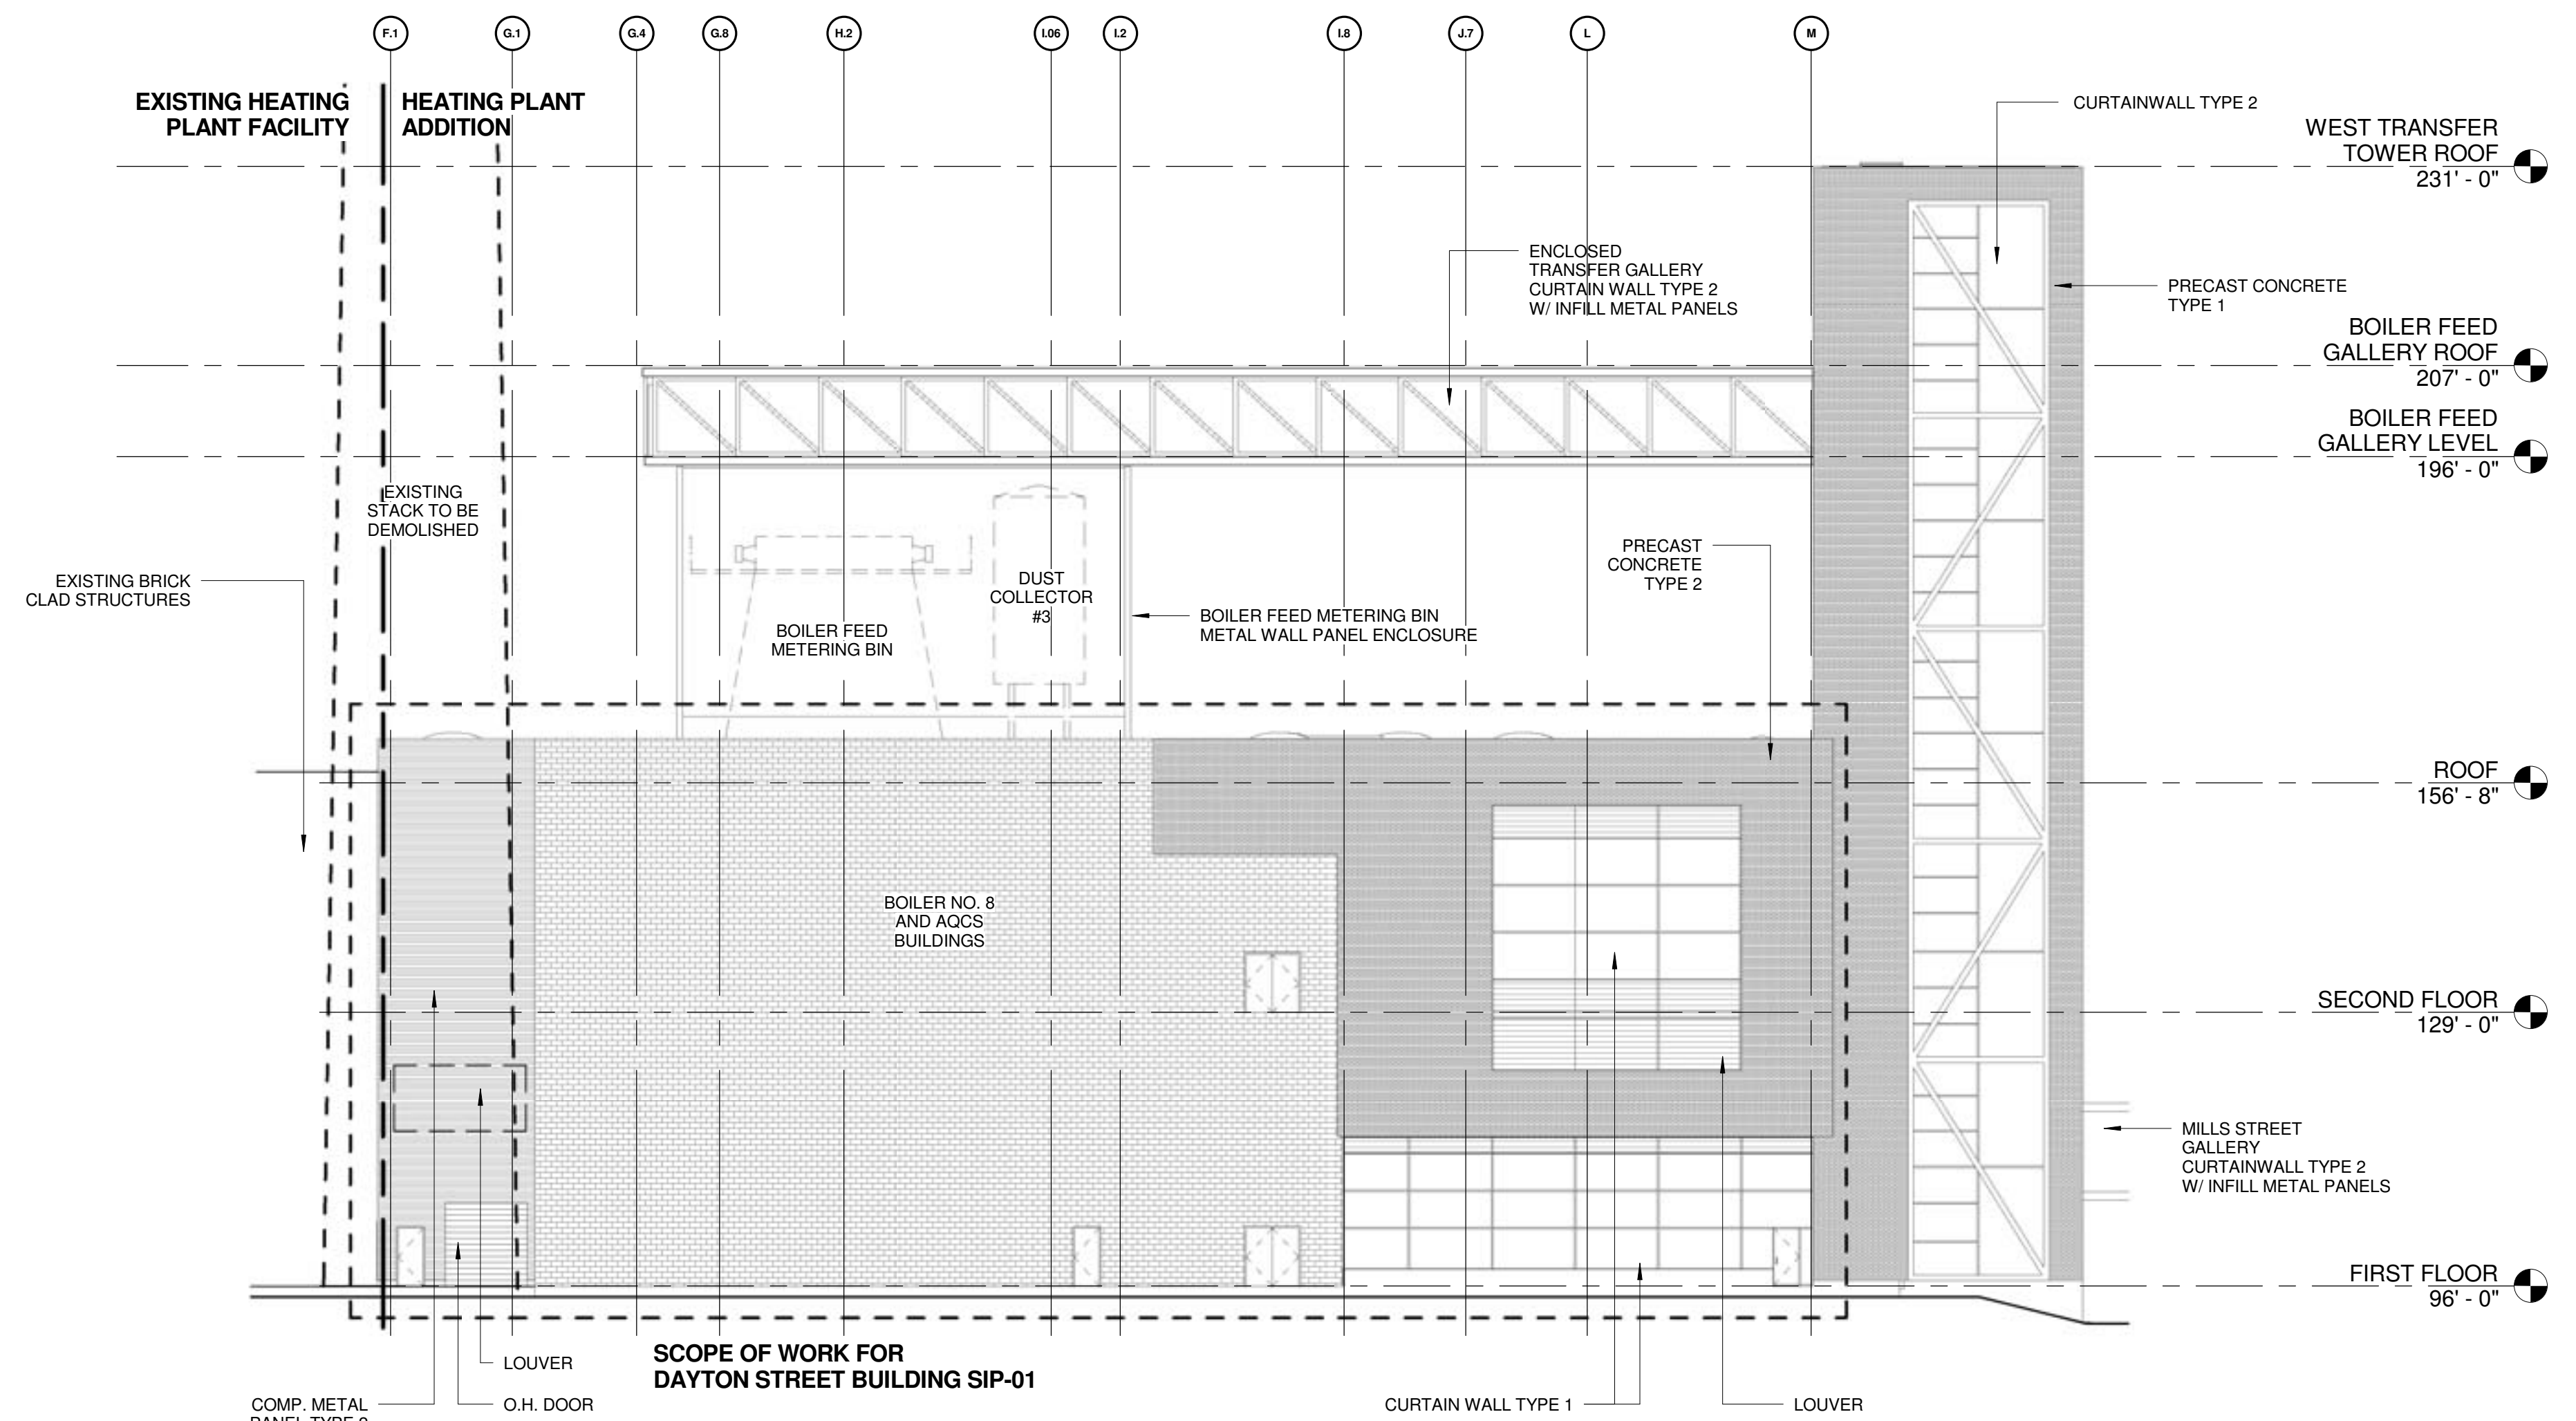

1 SOUTH ELEVATION
A202 1/16" = 1'-0"

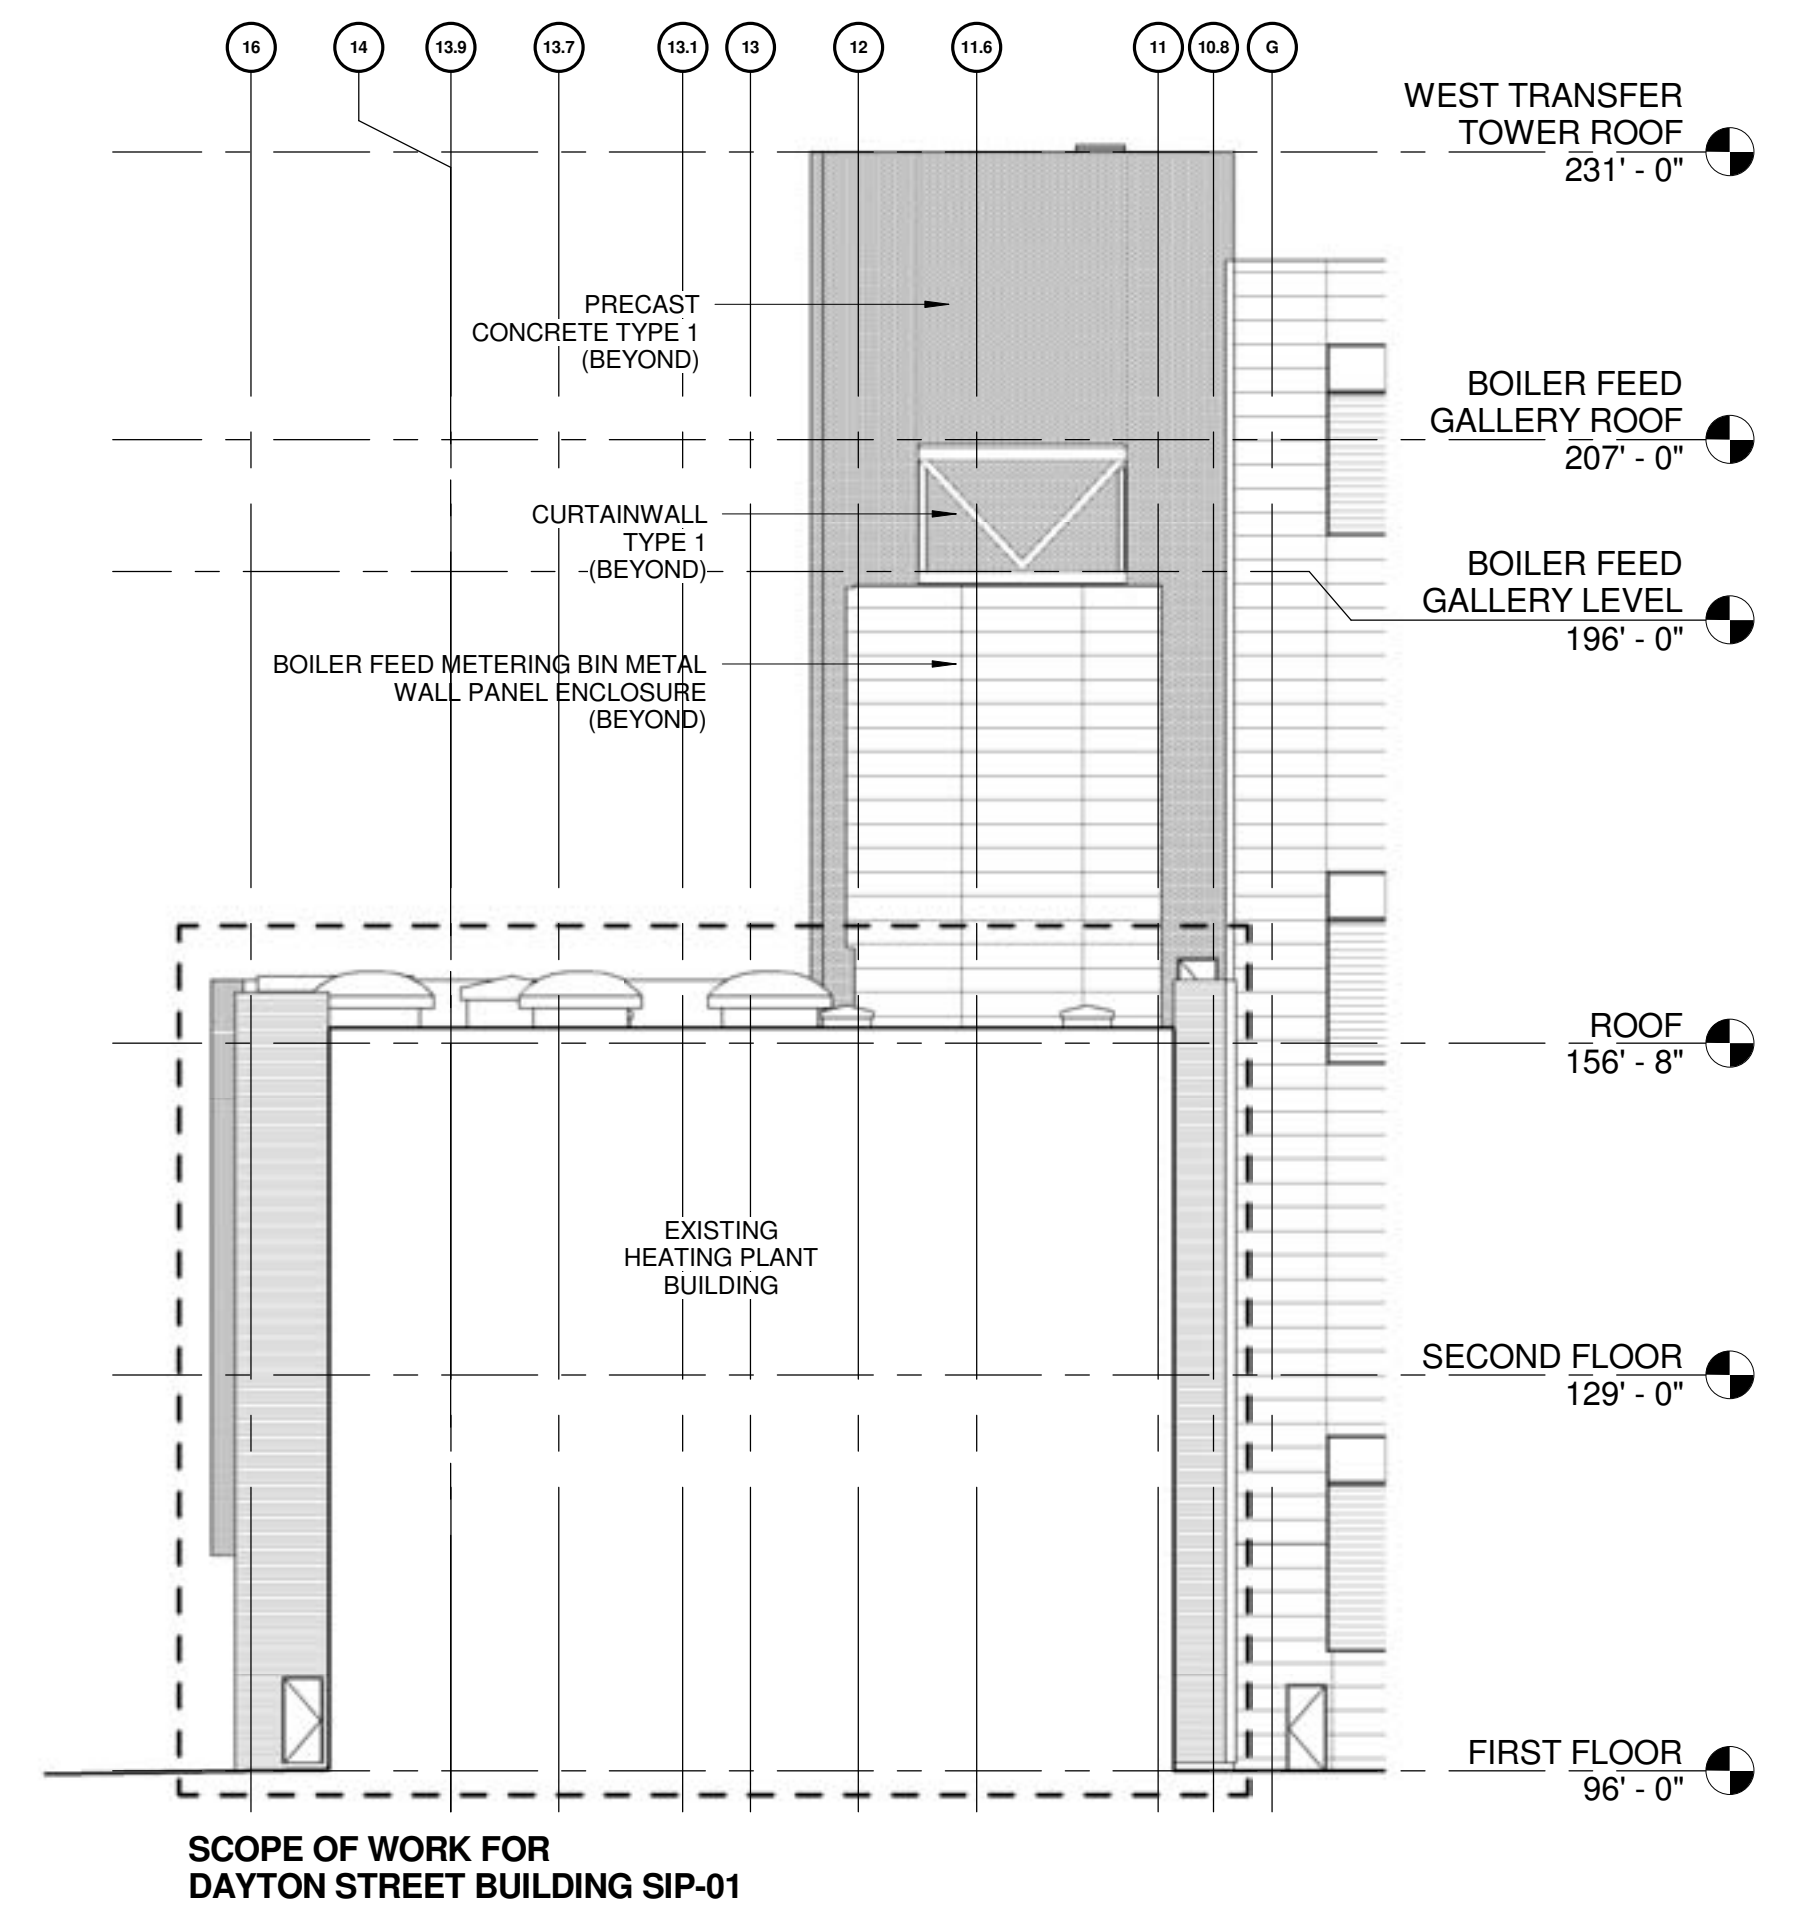

2 WEST ELEVATION
A202 1/16" = 1'-0"



EXTERIOR IMAGES INCLUDED IN THE UDC - GDP SUBMISSION 5.12.10

POWER ENGINEERS
COLLABORATIVE LLC

150 Sunny Slope Road
Suite 110
Brookfield, Wisconsin 53005
WWW.PECLLC.COM


**middough**

Potter Lawson

Project No:
2009.07.00

State of Wisconsin
Department of Administration
Division of State Facilities

SGCONSIN SYSTEM

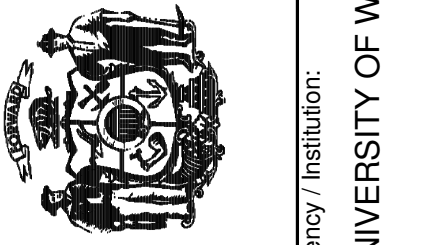

CHARTER STREET REBUILD

MADISON, WI

EXTERIOR RENDERINGS

[illegible]

Graphic scale	
SF number	09A2L
Set type	PR
Date issued	05-24-10
Sheet number	A213



Mills Street looking Northwest



Mills Street looking North



Bike Path looking West



Bike Path from Spring Street

EXTERIOR IMAGES INCLUDED IN THE UDC - GDP SUBMISSION 5.12.10

PEC

POWER ENGINEERS
COLLABORATIVE LLC

150 Sunny Slope Road
Suite 110
Brookfield, Wisconsin 53005
WWW.PECLLC.COM

POÿRY


POWER ARCHITECTS INC. OFFICE: WISCONSIN

middough

Potter Lawson

PLI Project No:
2009.07.00

State of Wisconsin
Department of Administration
Division of State Facilities

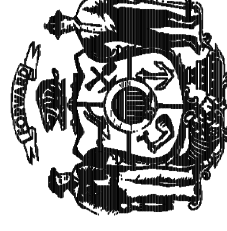
Agency / Institution:
UNIVERSITY OF WISCONSIN SYSTEM

Project Title:
CHARTER STREET REBUILD


Project Location:
MADISON, WI

Sheet Title:
EXTERIOR RENDERINGS

Revisions:

No.	Date:	By:	Description:

Graphic Scale	
DSF Number	09A2L
Set Type	PR
Date Issued	05-24-10
Sheet Number	A214

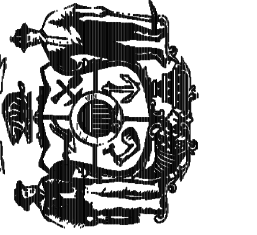

CHARIERS STREET REBUILD

MADISON, WI

CONCLUSION

visions:

[illegible]

Graphic	
ale	

Number	09A2L
--------	-------

	PR
--	----

te ued	05-24-10
-----------	----------

Sheet
Number

A301



2
A301

BUILDING SECTION


1/8" = 1'-0"



1
A301

BUILDING SECTION

$$\frac{1}{8}'' = 1'-0''$$

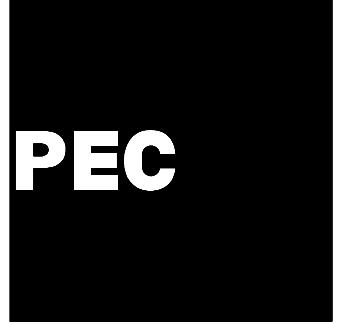


POWER ENGINEERS
COLLABORATIVE LLC
150 Sunny Slope Road
Suite 110
Brookfield, Wisconsin 53005
WWW.PECLLC.COM



PLT Project No:
2009.07.00

State of Wisconsin
Department of Administration
Division of State Facilities

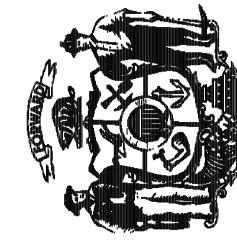

Agency / Institution:
UNIVERSITY OF WISCONSIN SYSTEM

CHARTER STREET REBUILD

MADISON, WI

BUILDING SECTIONS

Project Title:


Project Location:

Sheet Title:

Revisions:


No.	Date:	By:	Description:

Graphic Scale	
DSF Number	09A2L
Set Type	PR
Date Issued	05-24-10
Sheet Number	A302

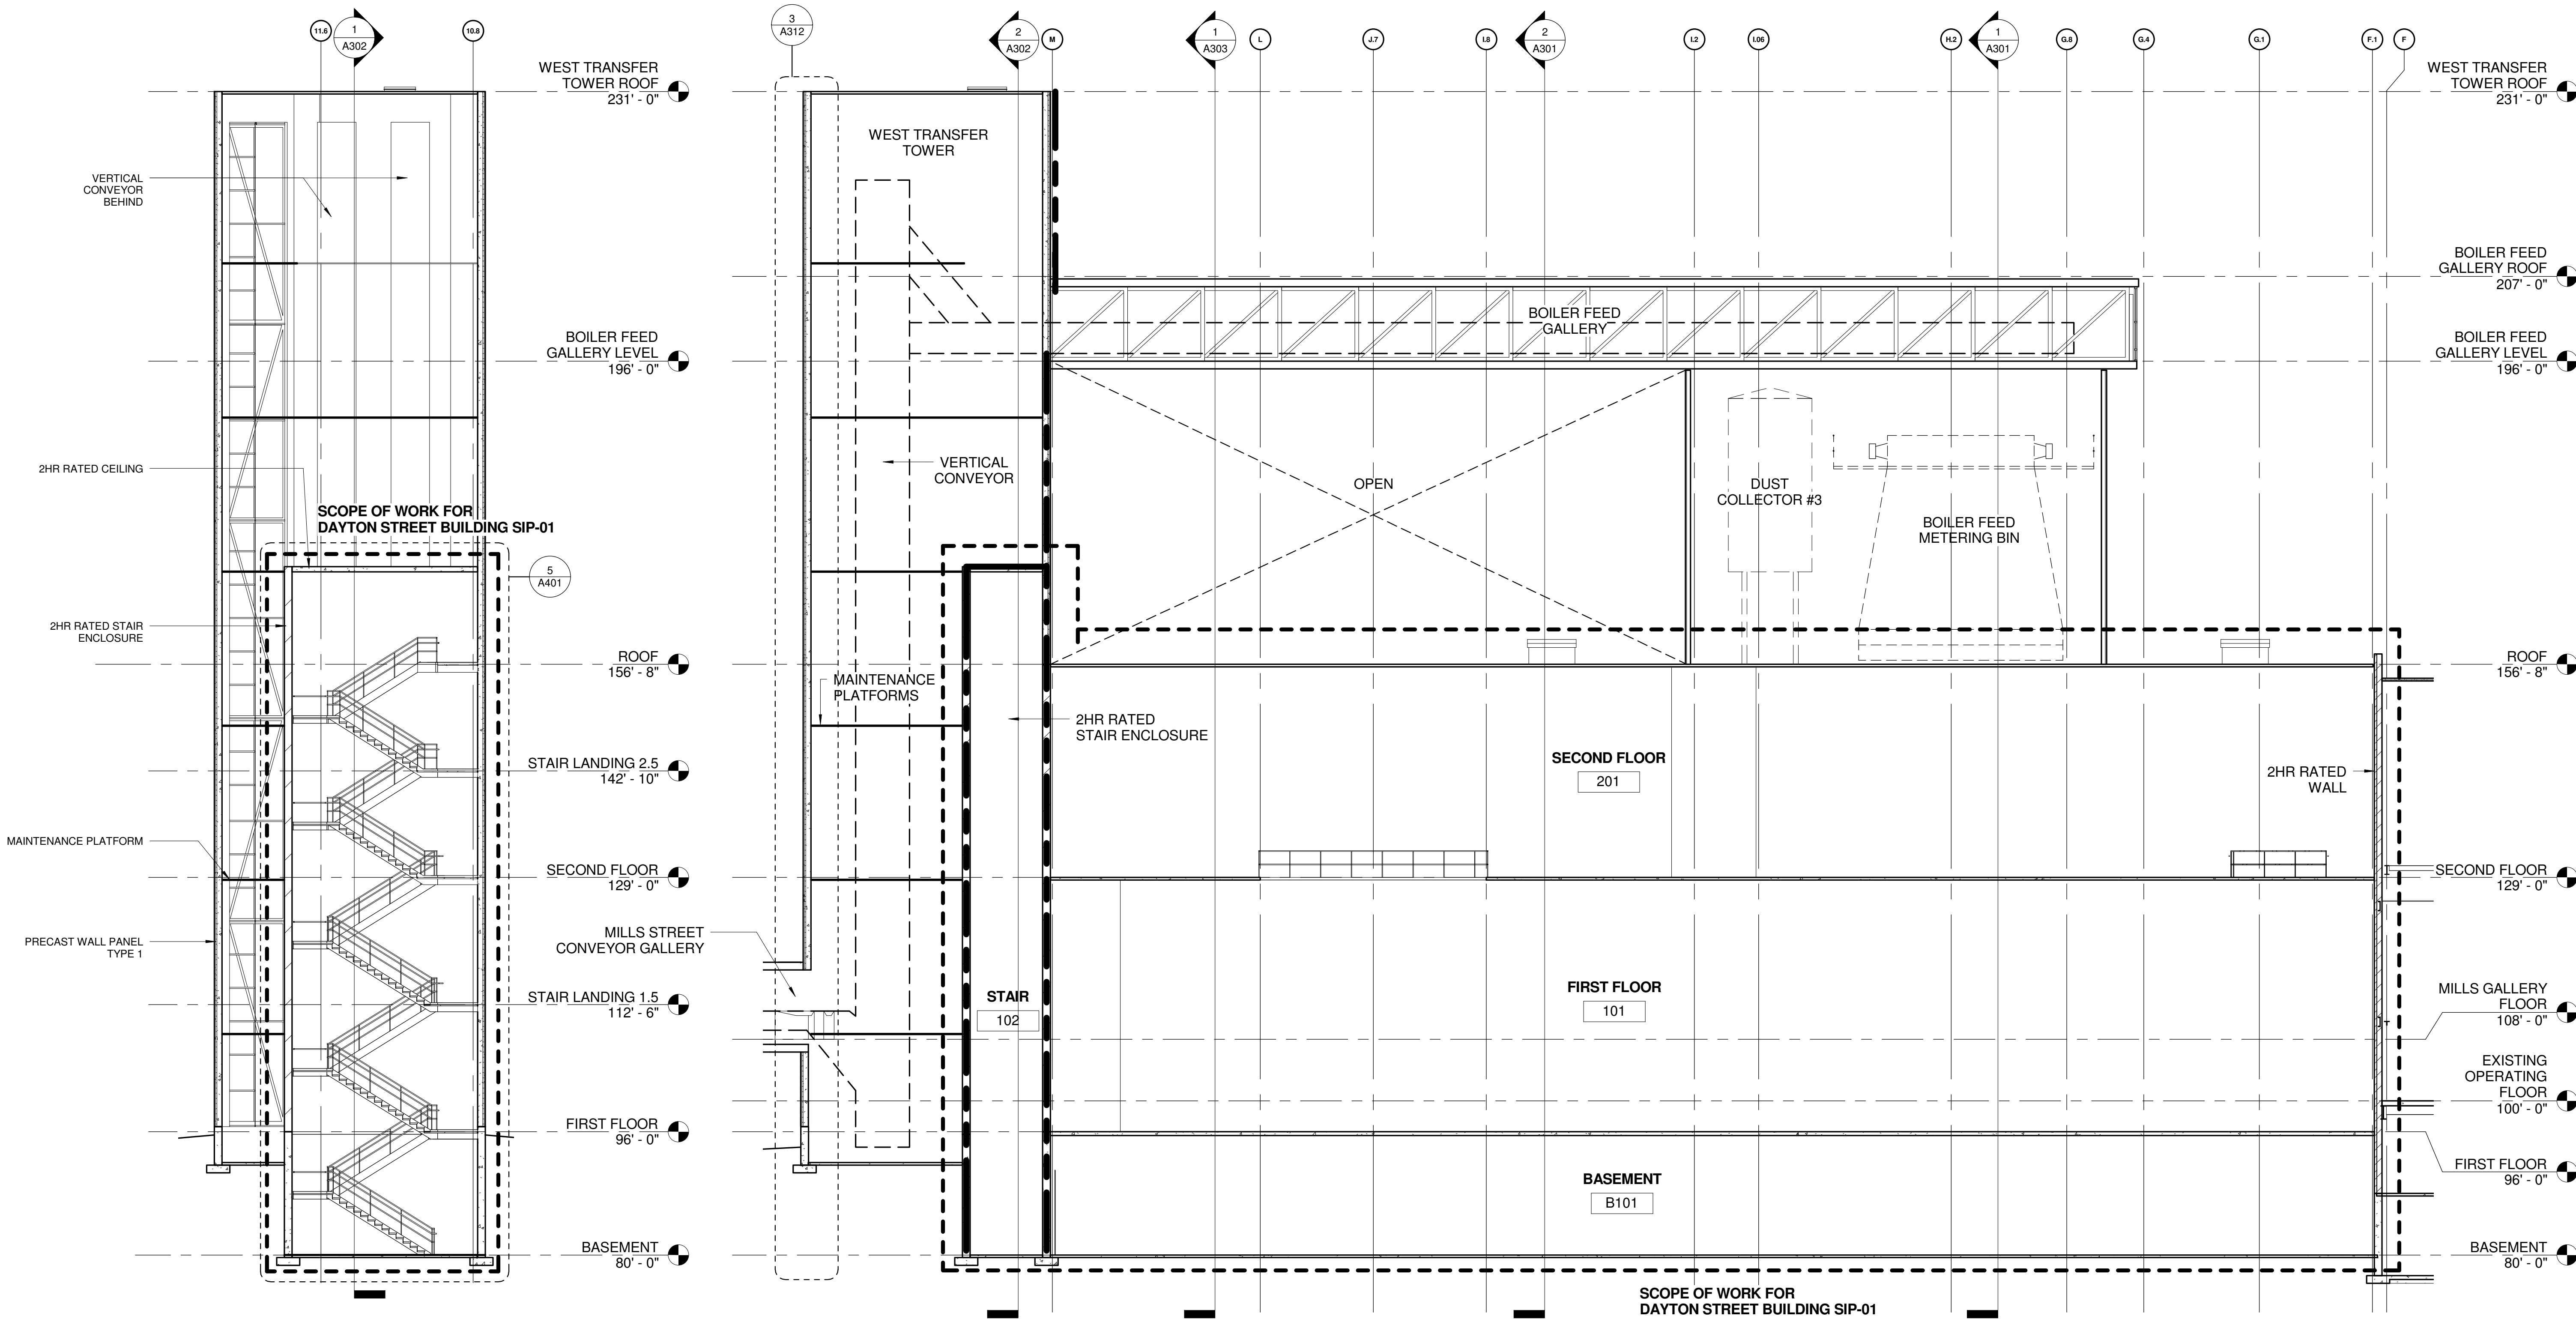

2 WEST TRANSFER TOWER SECTION
A302 3/32" = 1'-0"

1 BUILDING SECTION
A302 3/32" = 1'-0"

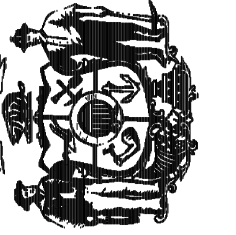

CHARIERS STREET REBUILD

MADISON, WI

CONCLUSION

visions:

[illegible]

Graphic	
ale	
F	

Number	09A2L
--------	-------

PR	
----	--


te ued	05-24-10
-----------	----------

Sheet
Number


A303




1 DAYTON STREET BUILDING SECTION
A303 1/8" = 1'-0"

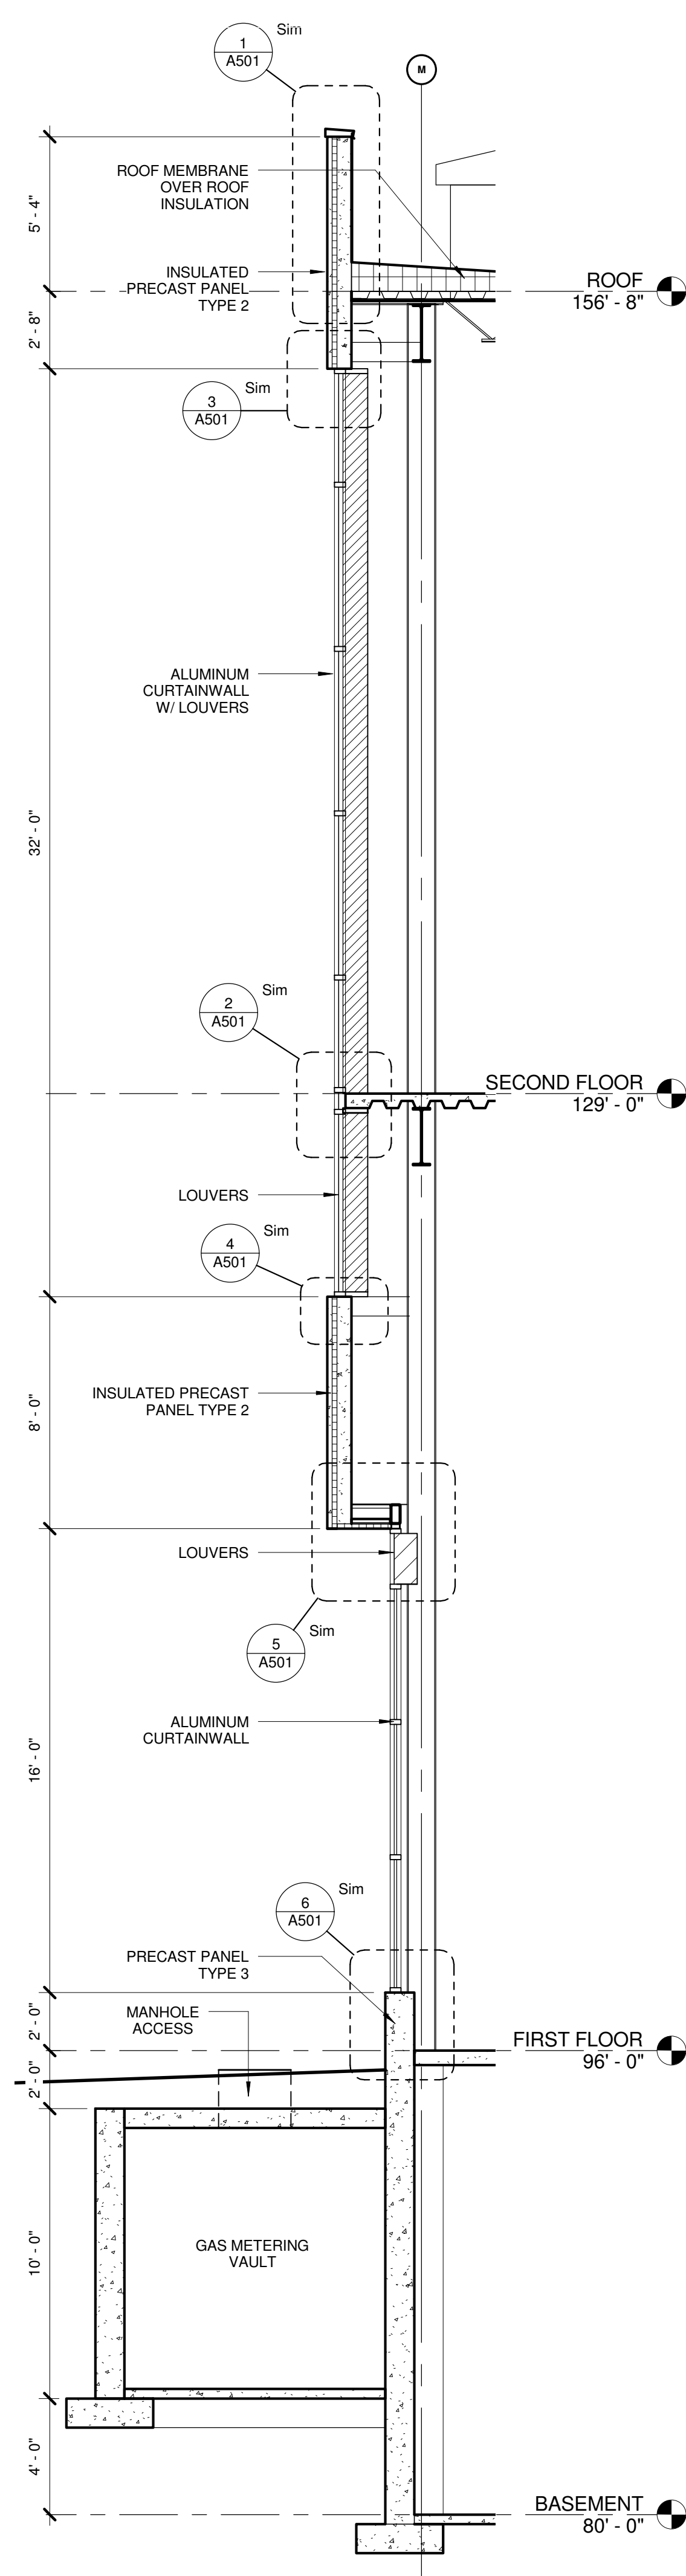


4 WALL SECTION
A311 1/4" = 1'-0"

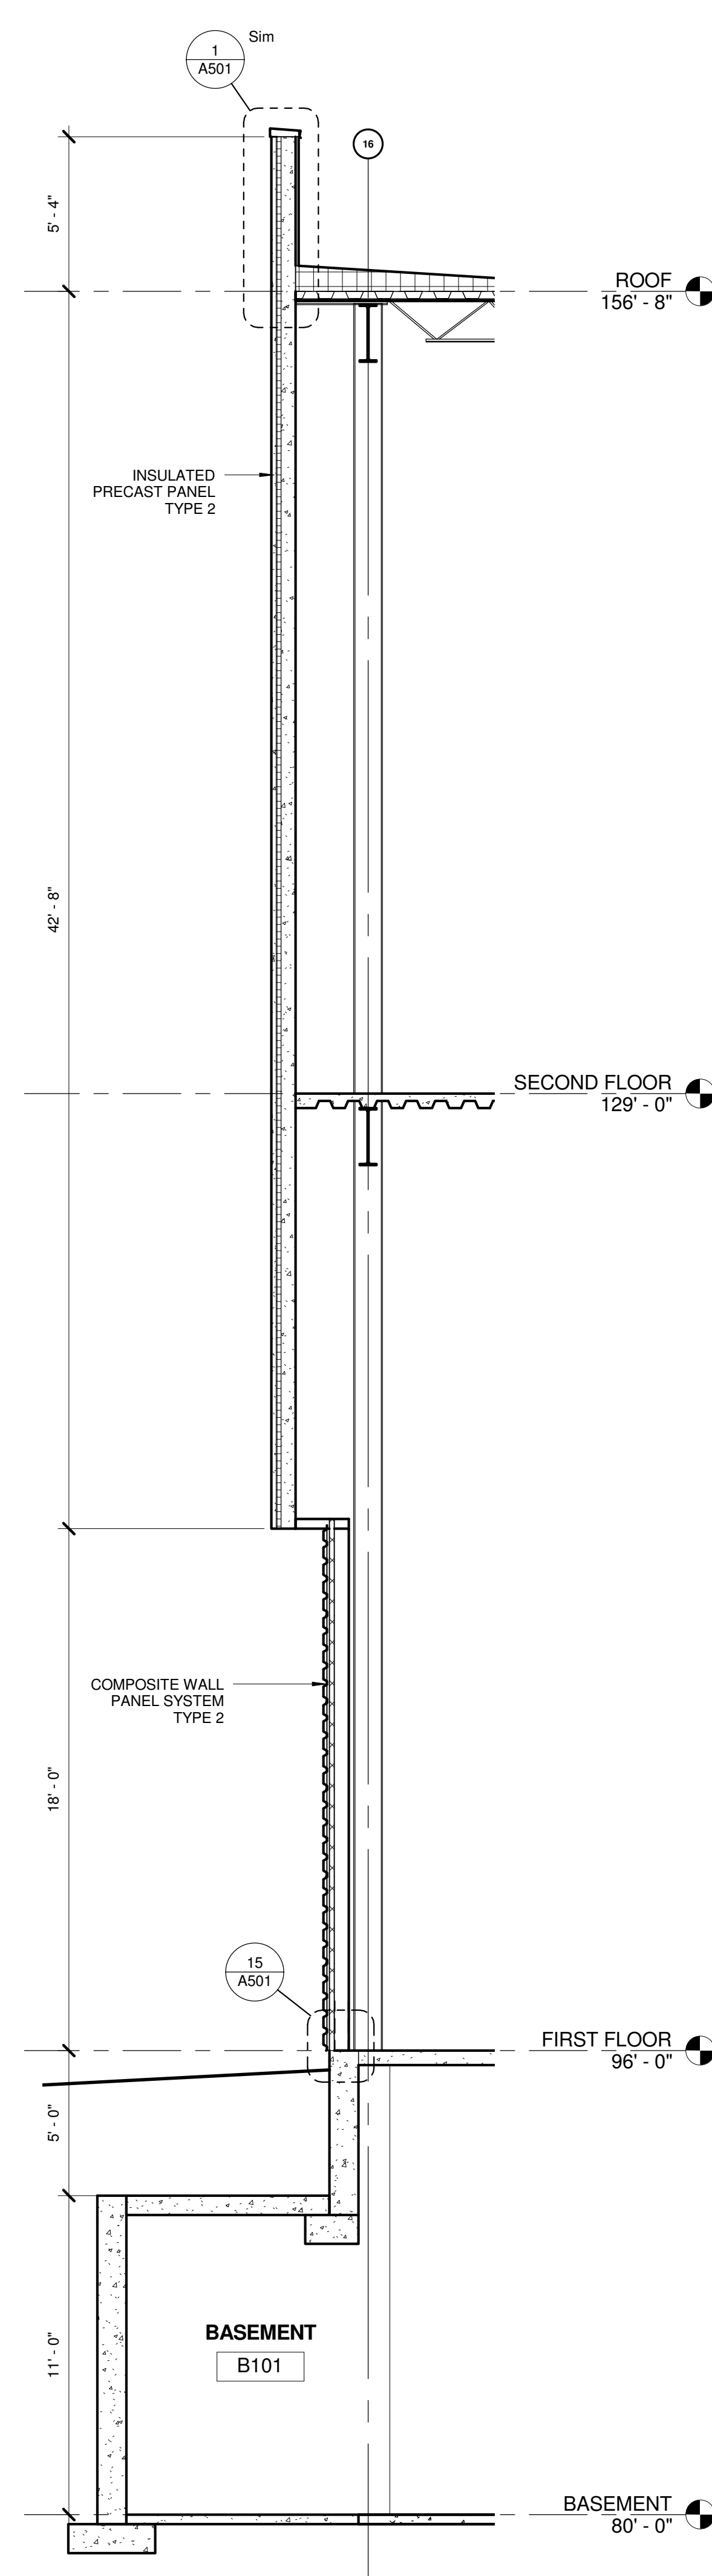

3 WALL SECTION
A311 1/4" = 1'-0"

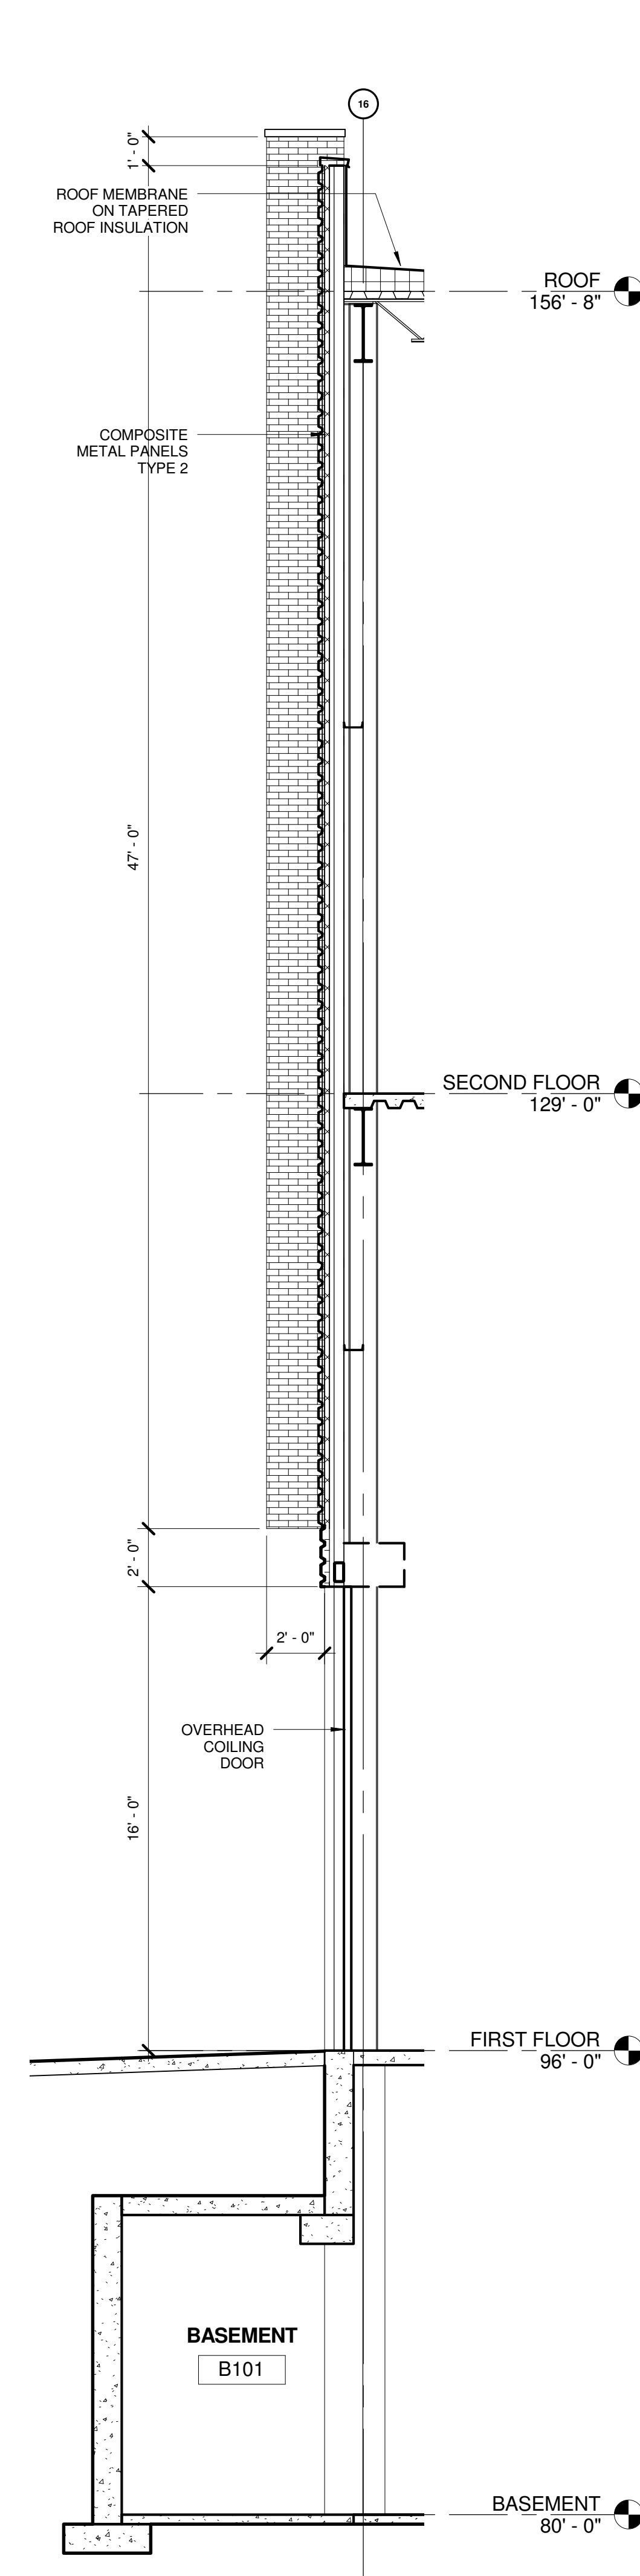

2 WALL SECTION
A311 1/4" = 1'-0"

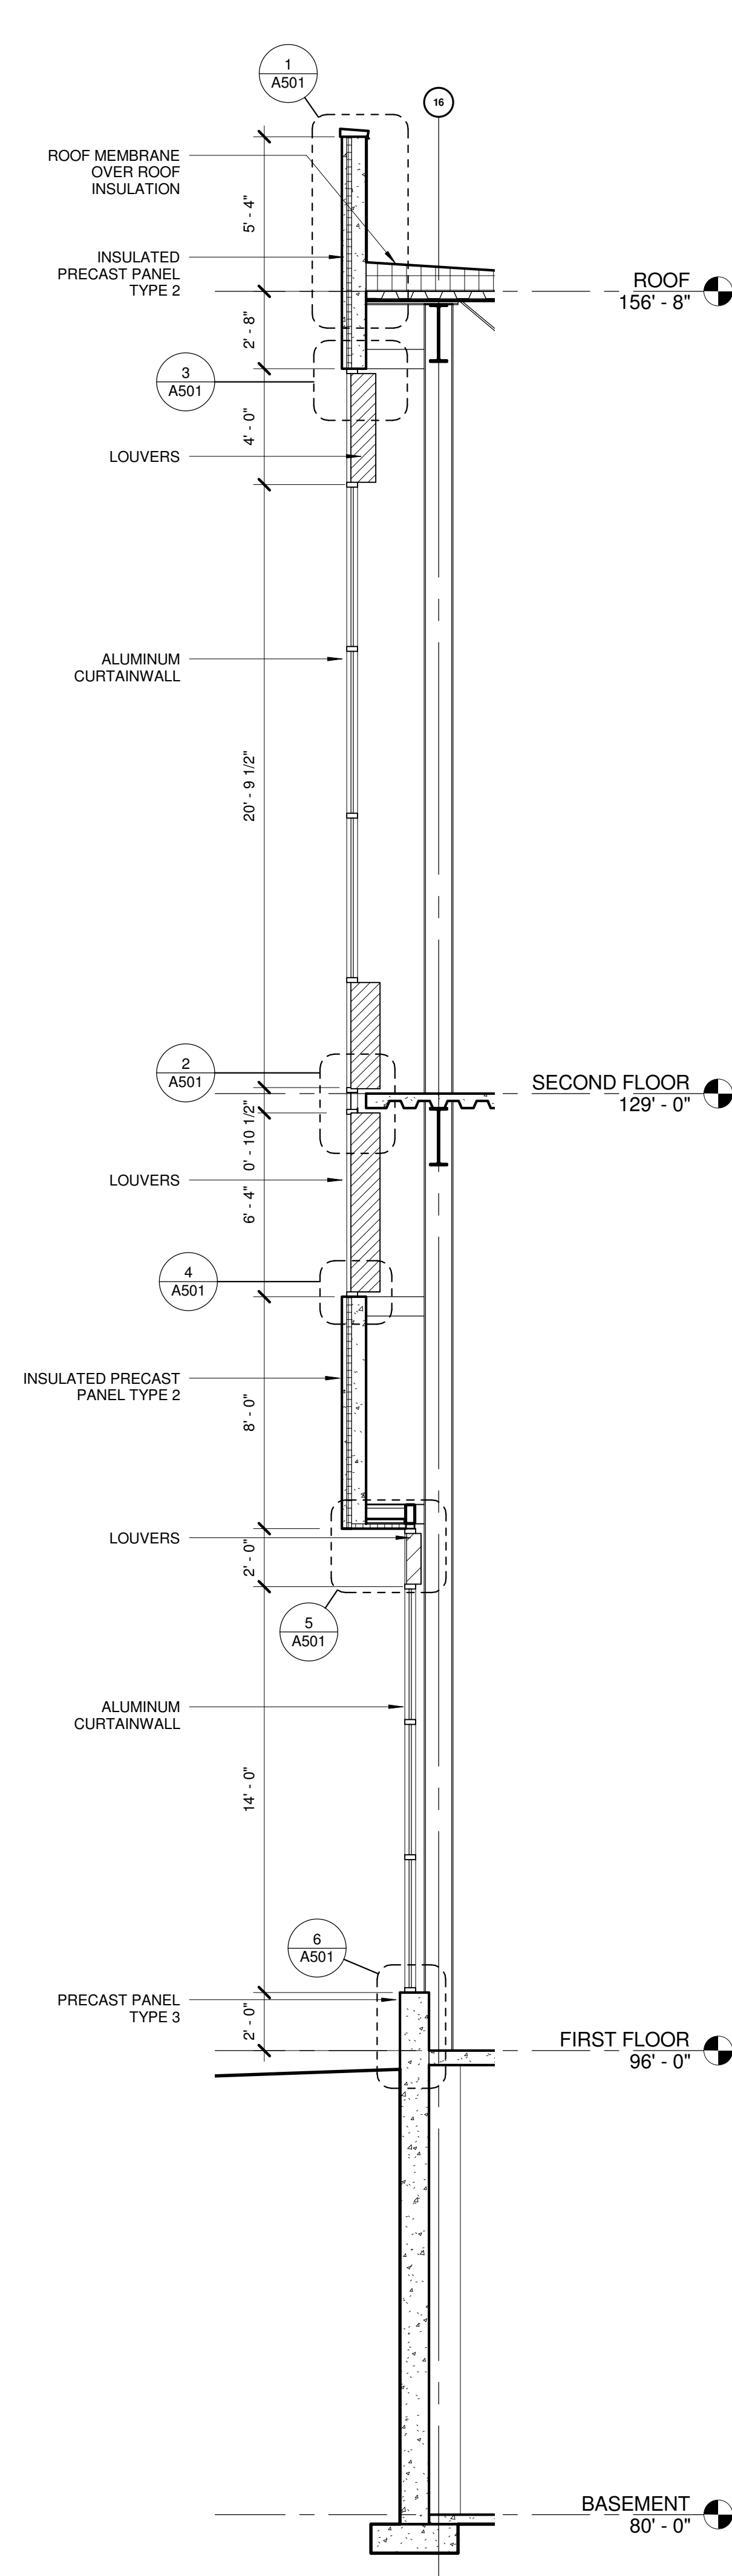

1 WALL SECTION
A311 1/4" = 1'-0"

POWER ENGINEERS
COLLABORATIVE LLC

150 Sunny Slope Road
Suite 110
Brookfield, Wisconsin 53005
WWW.PECLLC.COM




middough

Potter Lawson

LI Project No: 2009.07.00

State of Wisconsin
Department of Administration
Division of State Facilities

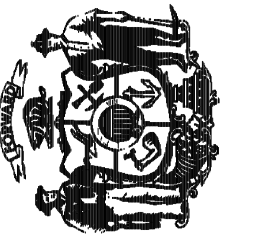

UNIVERSITY OF

CHARTER STREET REBUILD

MADISON, WI

WALL SECTIONS

Project Location:

Sheet 111e.

Revisions:

[illegible]

Graphic	
scale	

SF
umber

et	
ype	


ate	
sued	

Sheet	
-------	--

A311



Notter Lawsc

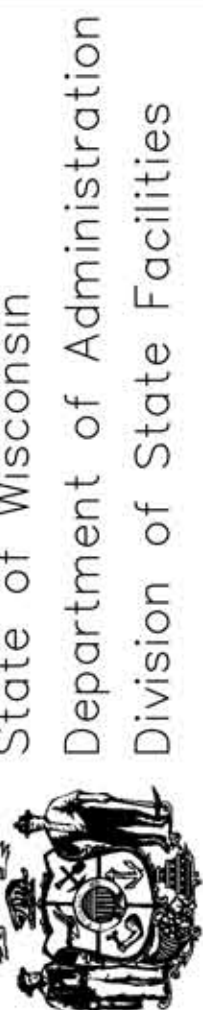

State of Wisconsin
Department of Administration
Division of State Facilities



CHARLES STREET | REBUILD

Project Location:
MADISON, WI.

Sheet Title: **Project Location: MADISON**

[illegible]


09A2L

PR

e	05/24/10
---	----------

	100
--	-----


F100

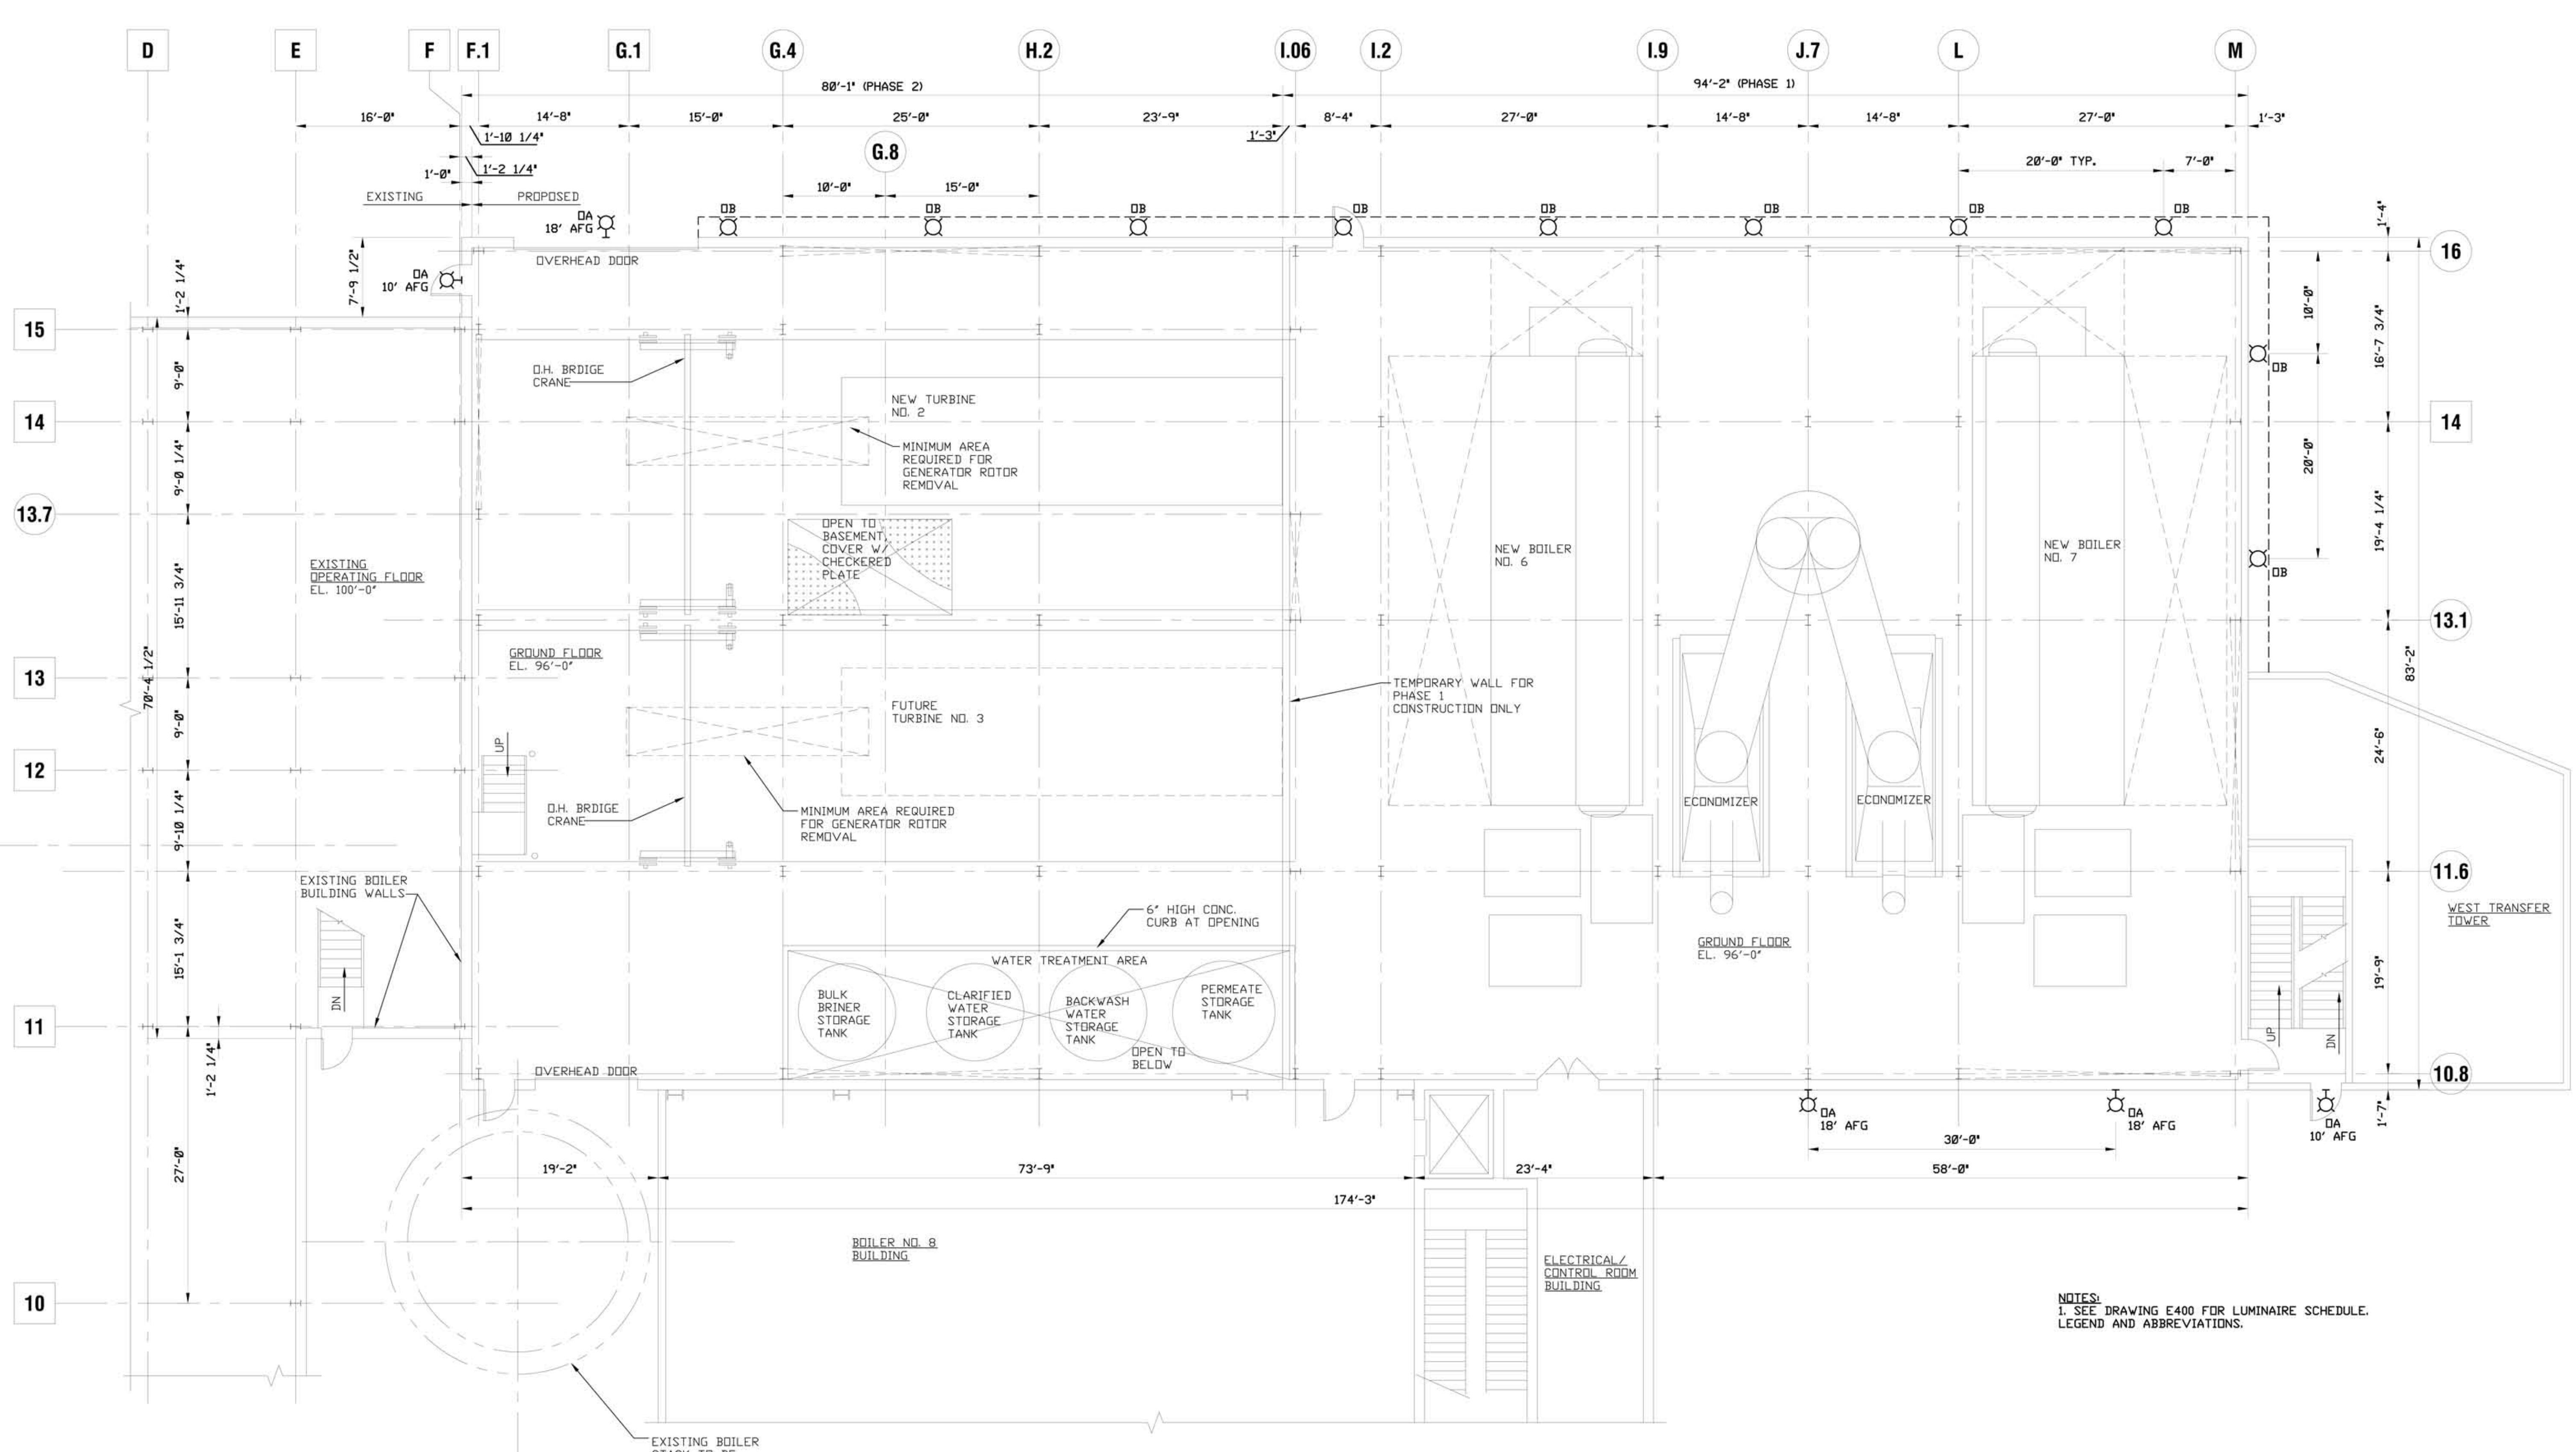



EXTERIOR LIGHTING PLAN
1/8"=1'-0"



PRELIMINARY
NOT FOR DESIGN OR CONSTRUCTION

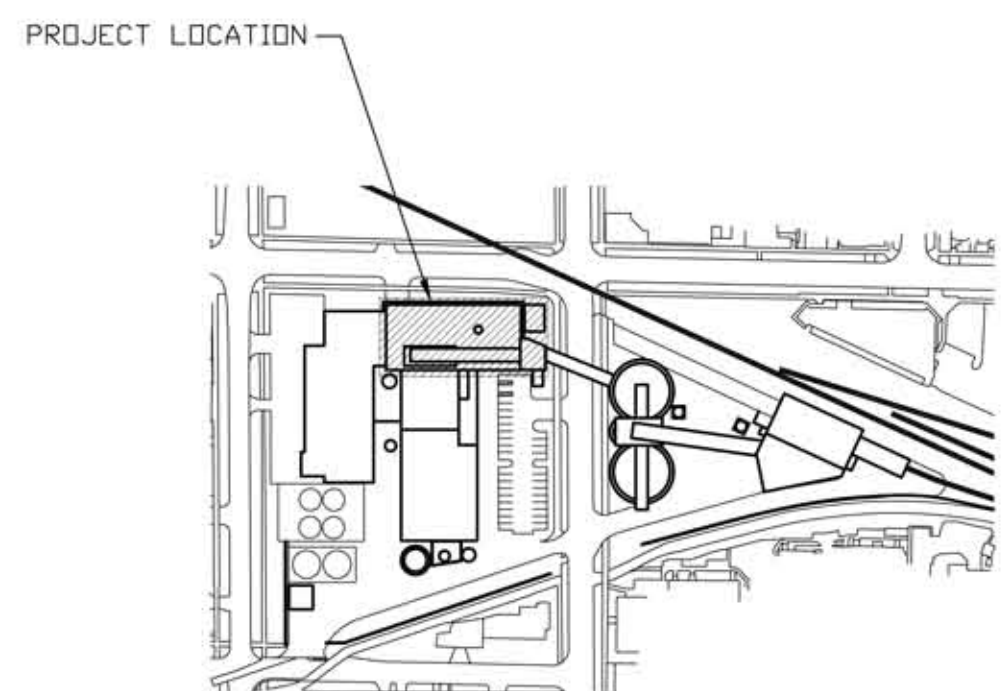


KEY PLAN

  LEGEND:			
	SUSPENDED OR RECESSED MOUNTED LIGHTING FIXTURE		480V THREE PHASE WELDING RECEPTACLE
	WALL OR COLUMN MOUNTED LIGHTING FIXTURE		VOICE/DATA OUTLET, LG JUNCTION BOX WITH 3/4" CONDUIT STUBBED TO ACCESSIBLE AREA.
	STANCHION MOUNTED LIGHTING FIXTURE		SINGLE POLE LIGHT SWITCH, 4'-0" AFF UNLESS NOTED (M IF SUBSCRIPT APPLIES SEE BELOW) 3 = 3-WAY SWITCH WP = WEATHERPROOF COVER NOTE: SEE SPEC. 262726 FOR SPECIAL REQUIREMENTS
	OUTDOOR POLE MOUNTED LIGHTING FIXTURE, SINGLE HEAD		FUSED DISCONNECT SWITCH
	OUTDOOR POLE MOUNTED LIGHTING FIXTURE, TWO HEADS		MANUAL MOTOR STARTER
	8 FOOT FLUORESCENT LIGHT FIXTURE		COMBINATION STARTER
	4 FOOT FLUORESCENT LIGHT FIXTURE		MOTOR
	4 FOOT FLUORESCENT WRAPAROUND		EQUIPMENT CONNECTION
	DUPLEX RECEPTACLE, 4'-0" AFF UNO (M IF SUBSCRIPT APPLIES SEE BELOW) WP = WEATHERPROOF COVER CR = CORROSION RESISTANT GFI = GROUND FAULT CIRCUIT INTERRUPTER NOTE: SEE SPEC. 262726 FOR SPECIAL REQUIREMENTS		SMOKE/HEAT DETECTOR COMBINATION
	DUPLEX RECEPTACLE, 18" AFF UNO (M IF SUBSCRIPT APPLIES SEE BELOW) WP = WEATHERPROOF COVER CR = CORROSION RESISTANT GFI = GROUND FAULT CIRCUIT INTERRUPTER NOTE: SEE SPEC. 262726 FOR SPECIAL REQUIREMENTS		LINE VOLTAGE THERMOSTAT
	EMERGENCY BATTERY PACK C/W TWIN EMERGENCY LAMPS		FAN SPEED CONTROLLER
	WALL MOUNTED EXIT LIGHT		

PRELIMINARY
NOT FOR DESIGN OR CONSTRUCTION



[illegible]

THIS DRAWING IS A PRELIMINARY LAYOUT ONLY.
ALL DIMENSIONS ARE TO BE FINALIZED AFTER
FORMAL PURCHASE ORDER AND COMPLETE
ENGINEERING APPROVAL.
CB NB PROPOSAL NO. 24587 - DAVID O.

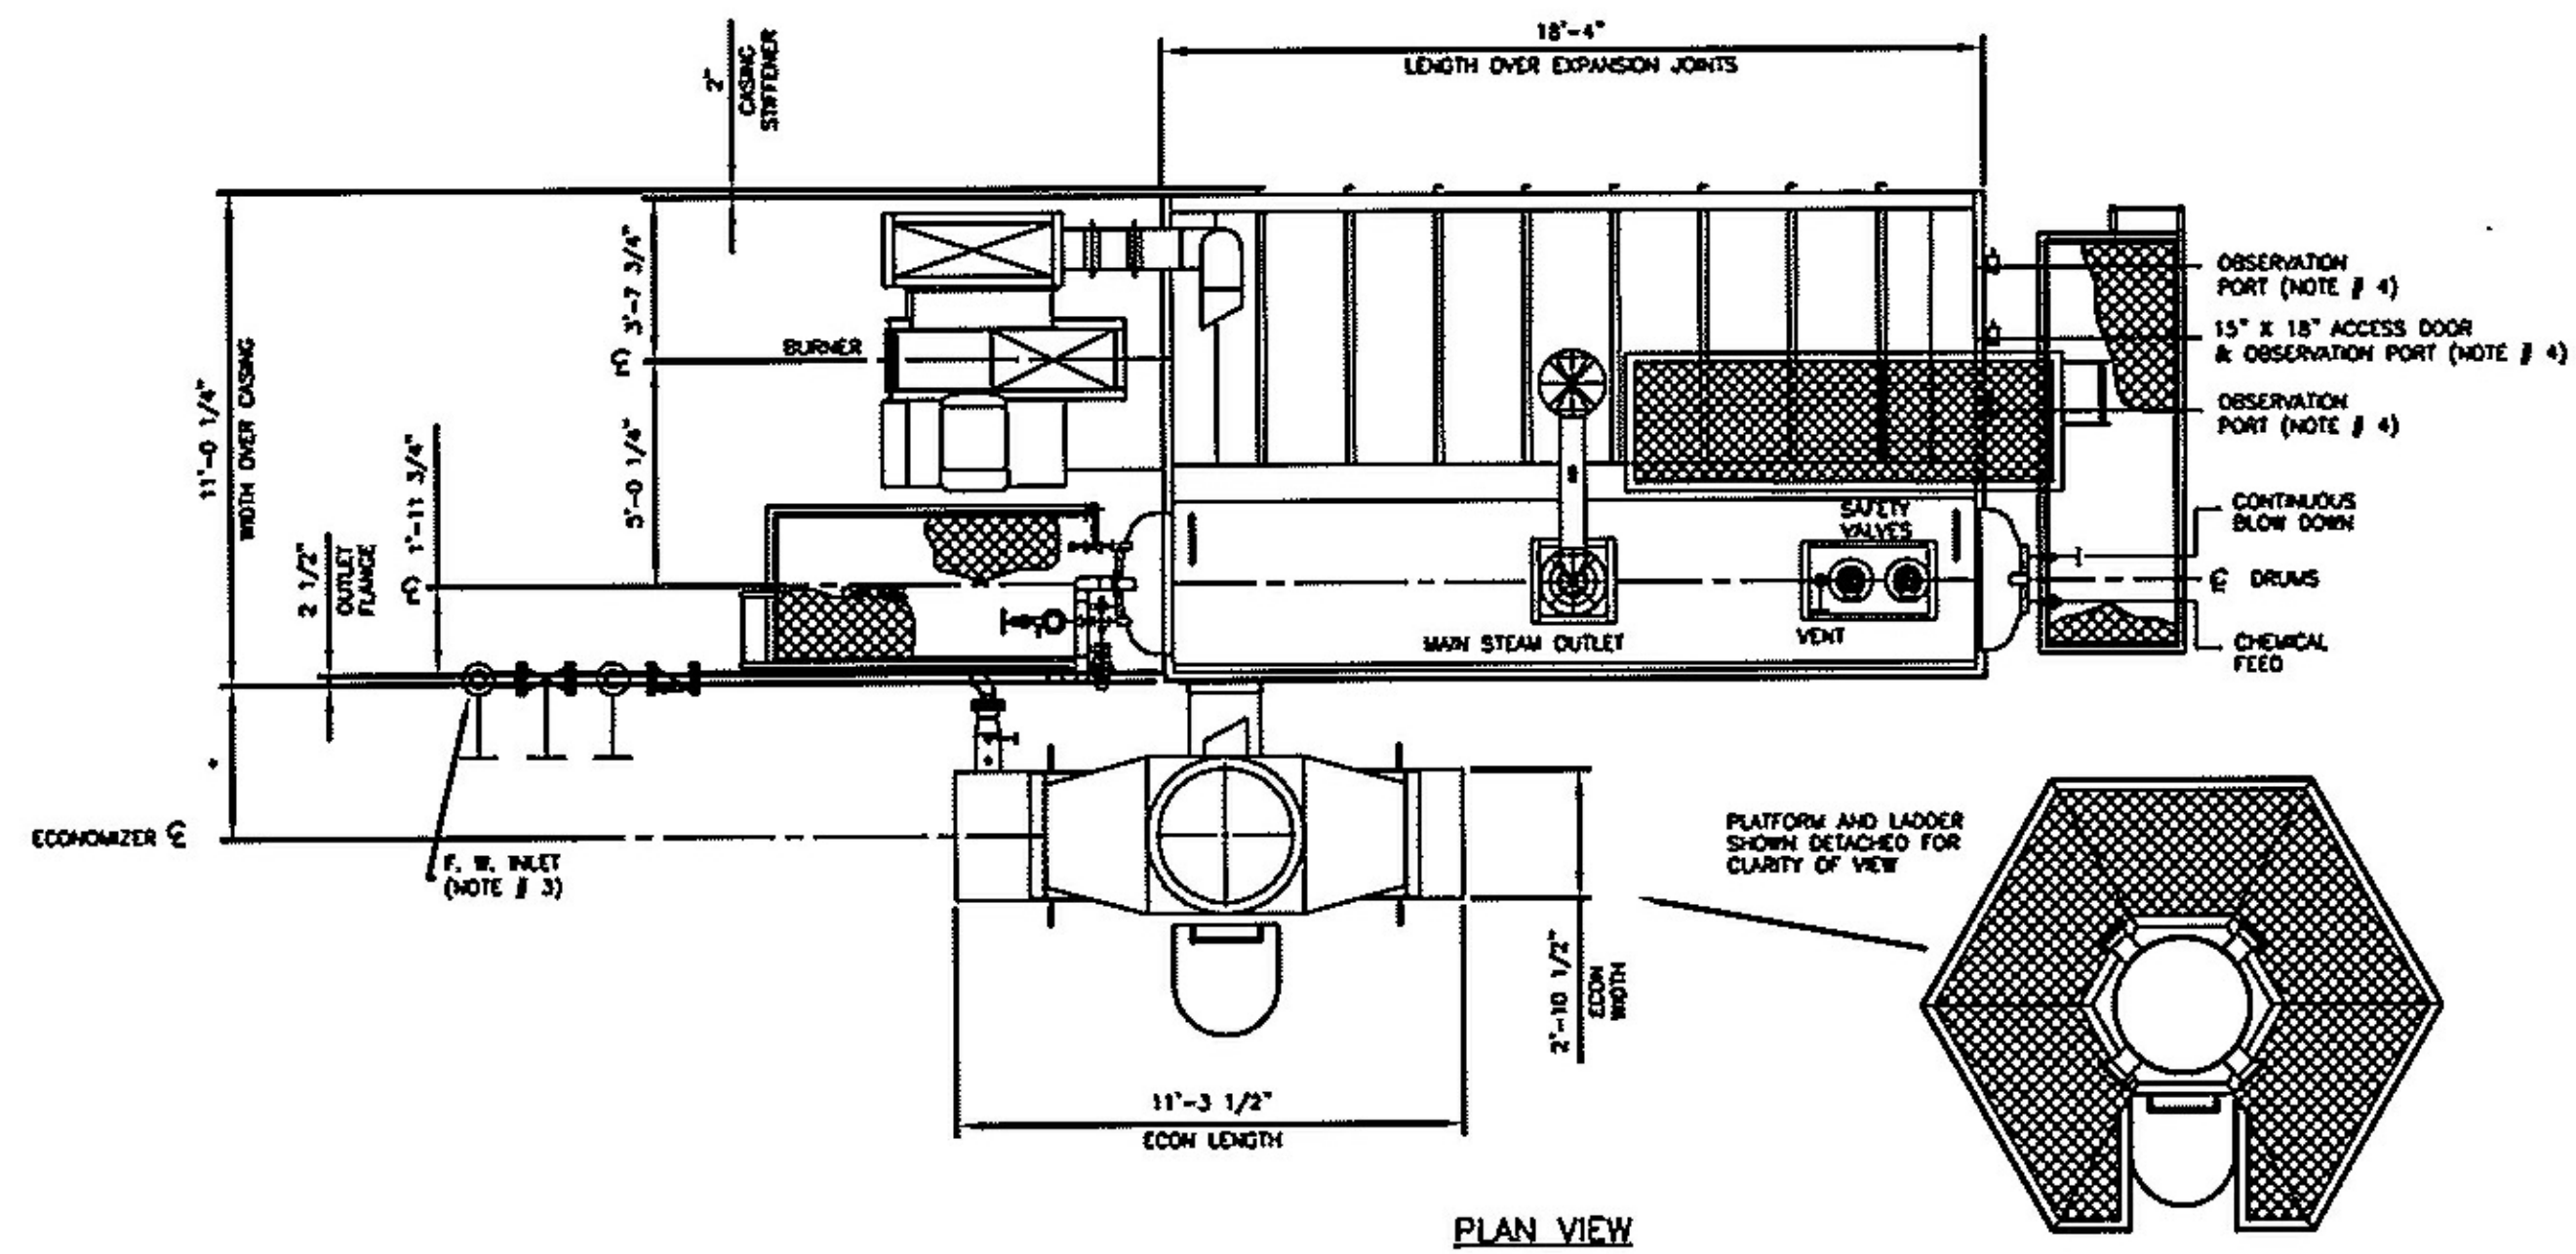

DO NOT SCALE - USE DIMENSIONS ONLY		N/A/D.O. INDICATES NOT FURNISHED BY CB NE			
DO NOT USE FOR CONSTRUCTION UNLESS APPROVED BELOW					
THIS DRAWING IS THE PROPERTY OF CB NEBRASKA BOILER AND IS LOANED ON CONDITION THAT IT SHALL NOT BE COPIED OR REPRODUCED IN WHOLE OR IN PART OR DISCLOSED TO ANY THIRD PARTY OR USED IN ANY WAY WITHOUT THE WRITTEN CONSENT OF CB NEBRASKA BOILER. ANY EQUIPMENT OR MATERIALS, BUT NOT FURNISHED BY CB NEBRASKA BOILER, IS FOR ILLUSTRATING THE APPLICATION, AND CB NEBRASKA BOILER ACCEPTS NO RESPONSIBILITY AS TO INSTALLATION OR OPERATION OF SUCH EQUIPMENT OR MATERIALS.					
REV.	DATE	DESCRIPTION	DRAWN	CHECKED	APPROVED

- NOTES:**
1. DRAWING IS FOR OVERALL SIZE AND ARRANGEMENT ONLY. REFER TO PROPOSAL FOR ACTUAL TRIM LISTING.
 2. DRAWING IS NOT TO BE USED FOR CONSTRUCTION PURPOSES.
 3. SIZES AND LOCATIONS OF FEEDWATER PIPING AND VALVE IS A REPRESENTATION ONLY, AND IS USED TO SHOW AN EASILY VISIBLE PICTORIAL VIEW.
 4. * - DENOTES TO BE DETERMINED. NUMBER AND LOCATION OF OBSERVATION PORTS IS TO BE DETERMINED.
 5. BOILER SUPPORT STRUCTURE AND LIFTING LUGS WILL BE SIZED AND LOCATED UPON FINAL ENGINEERING.

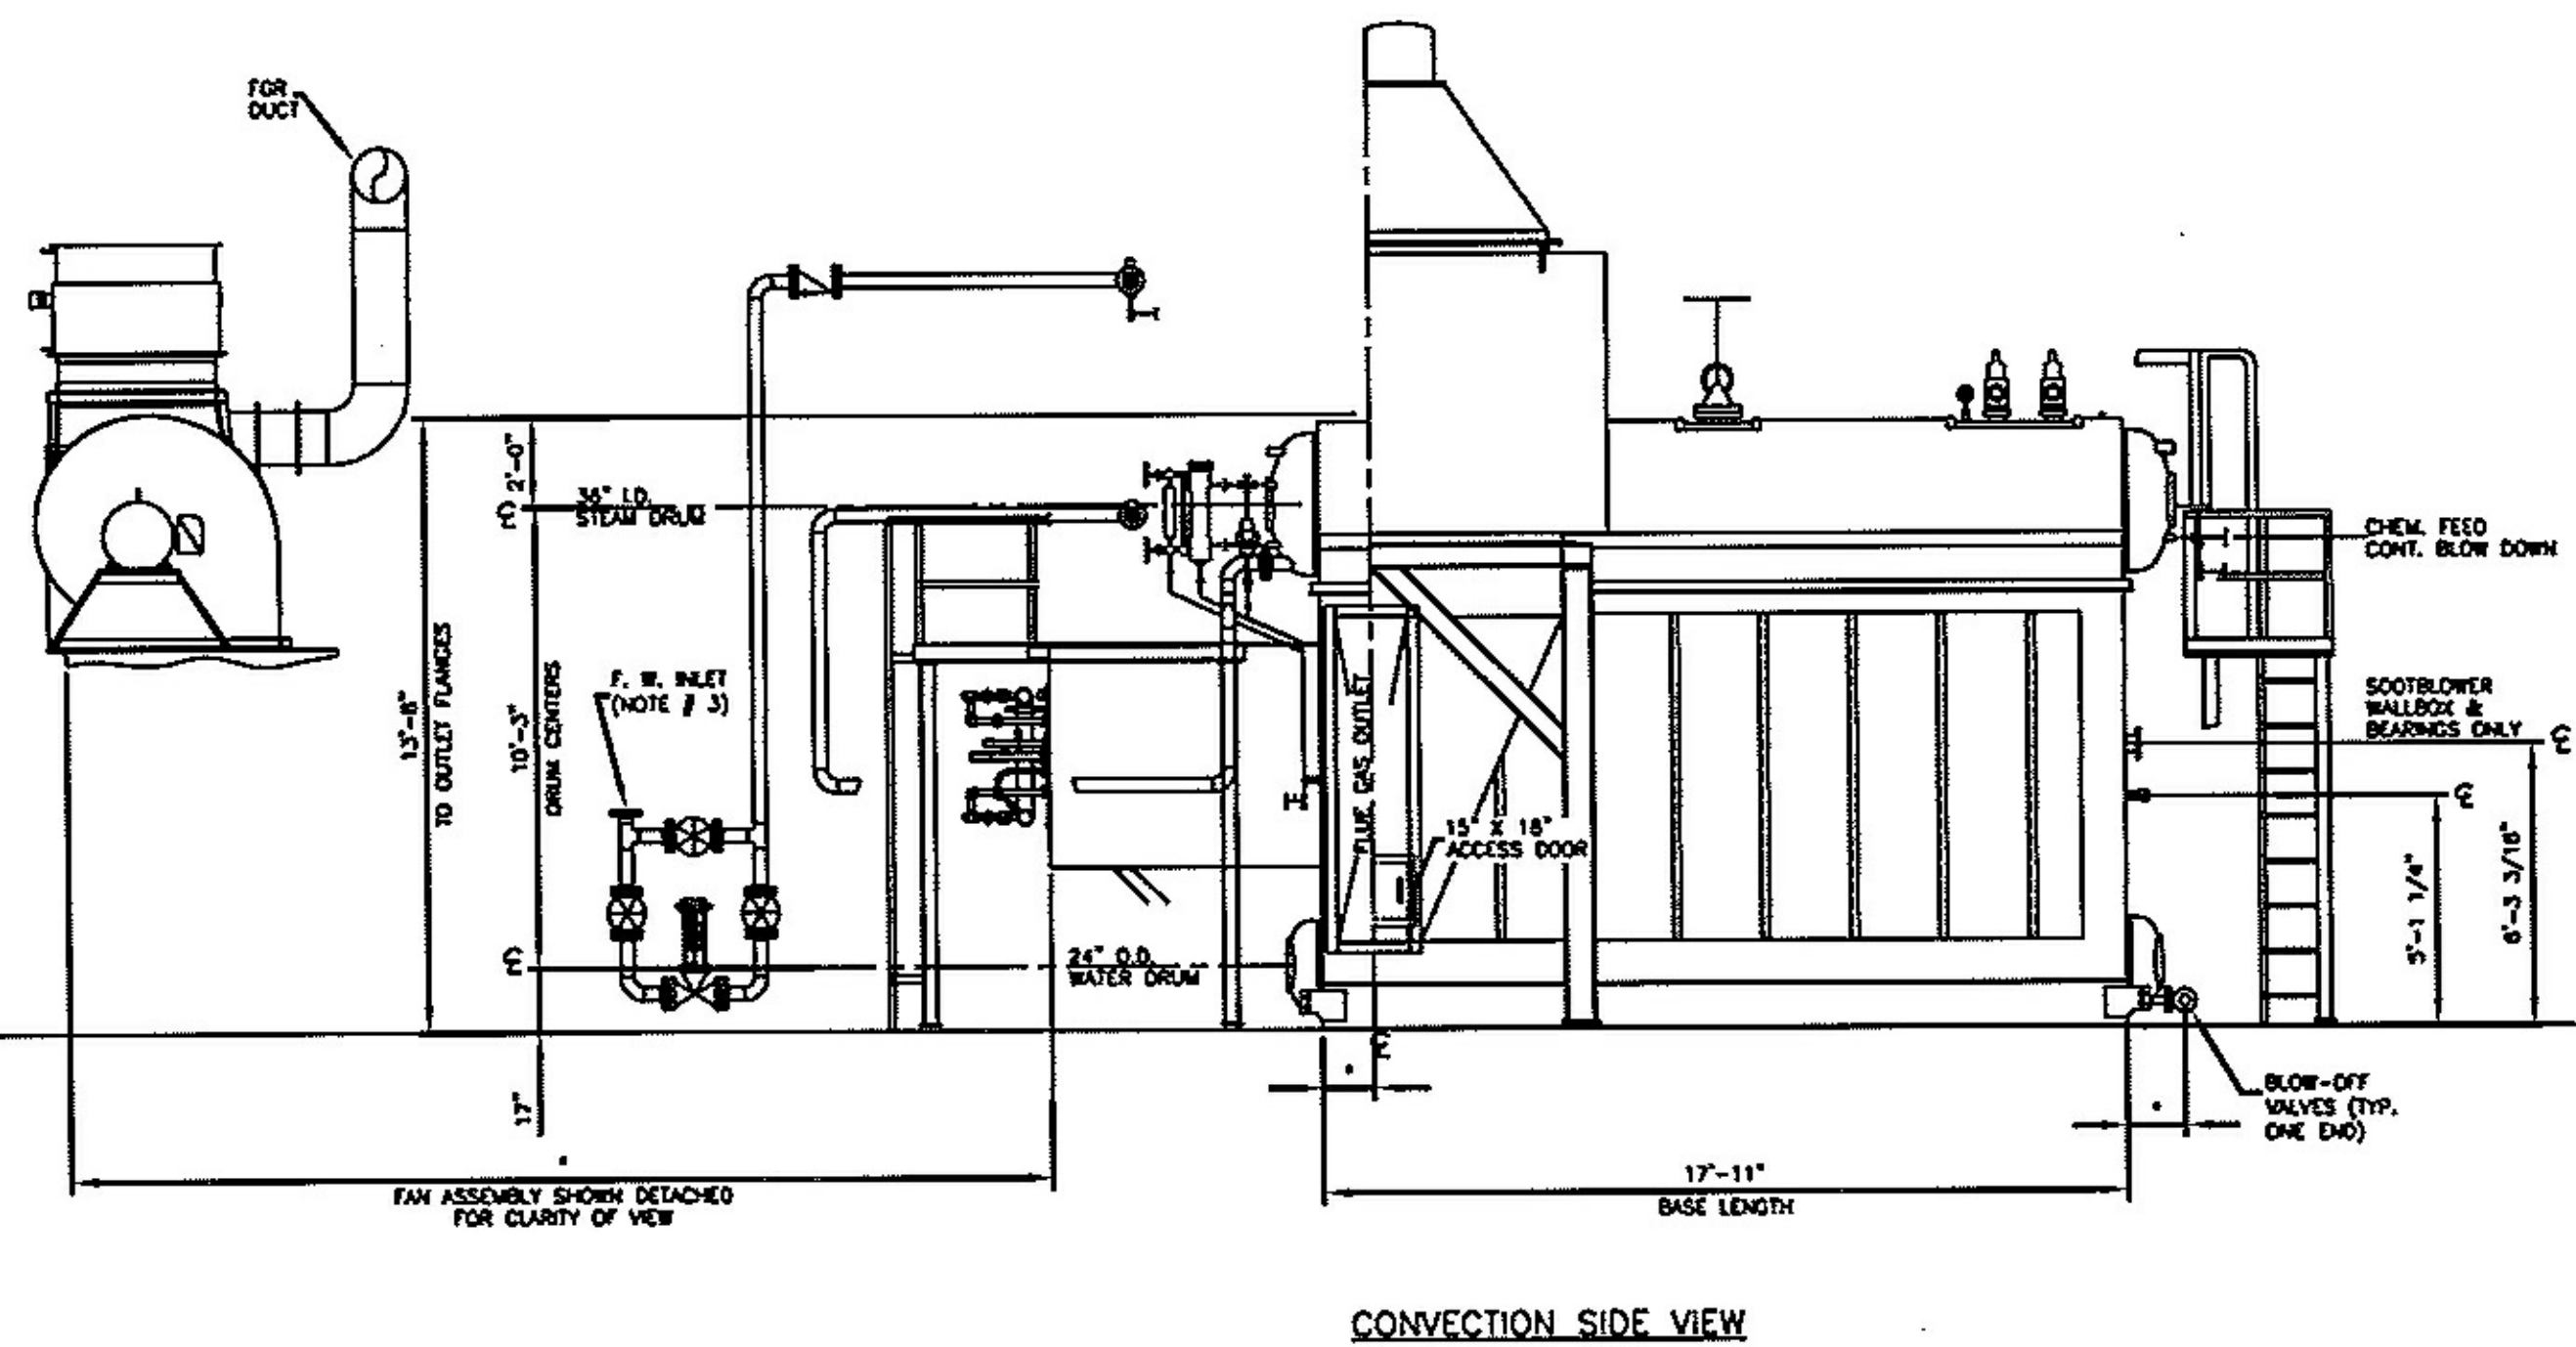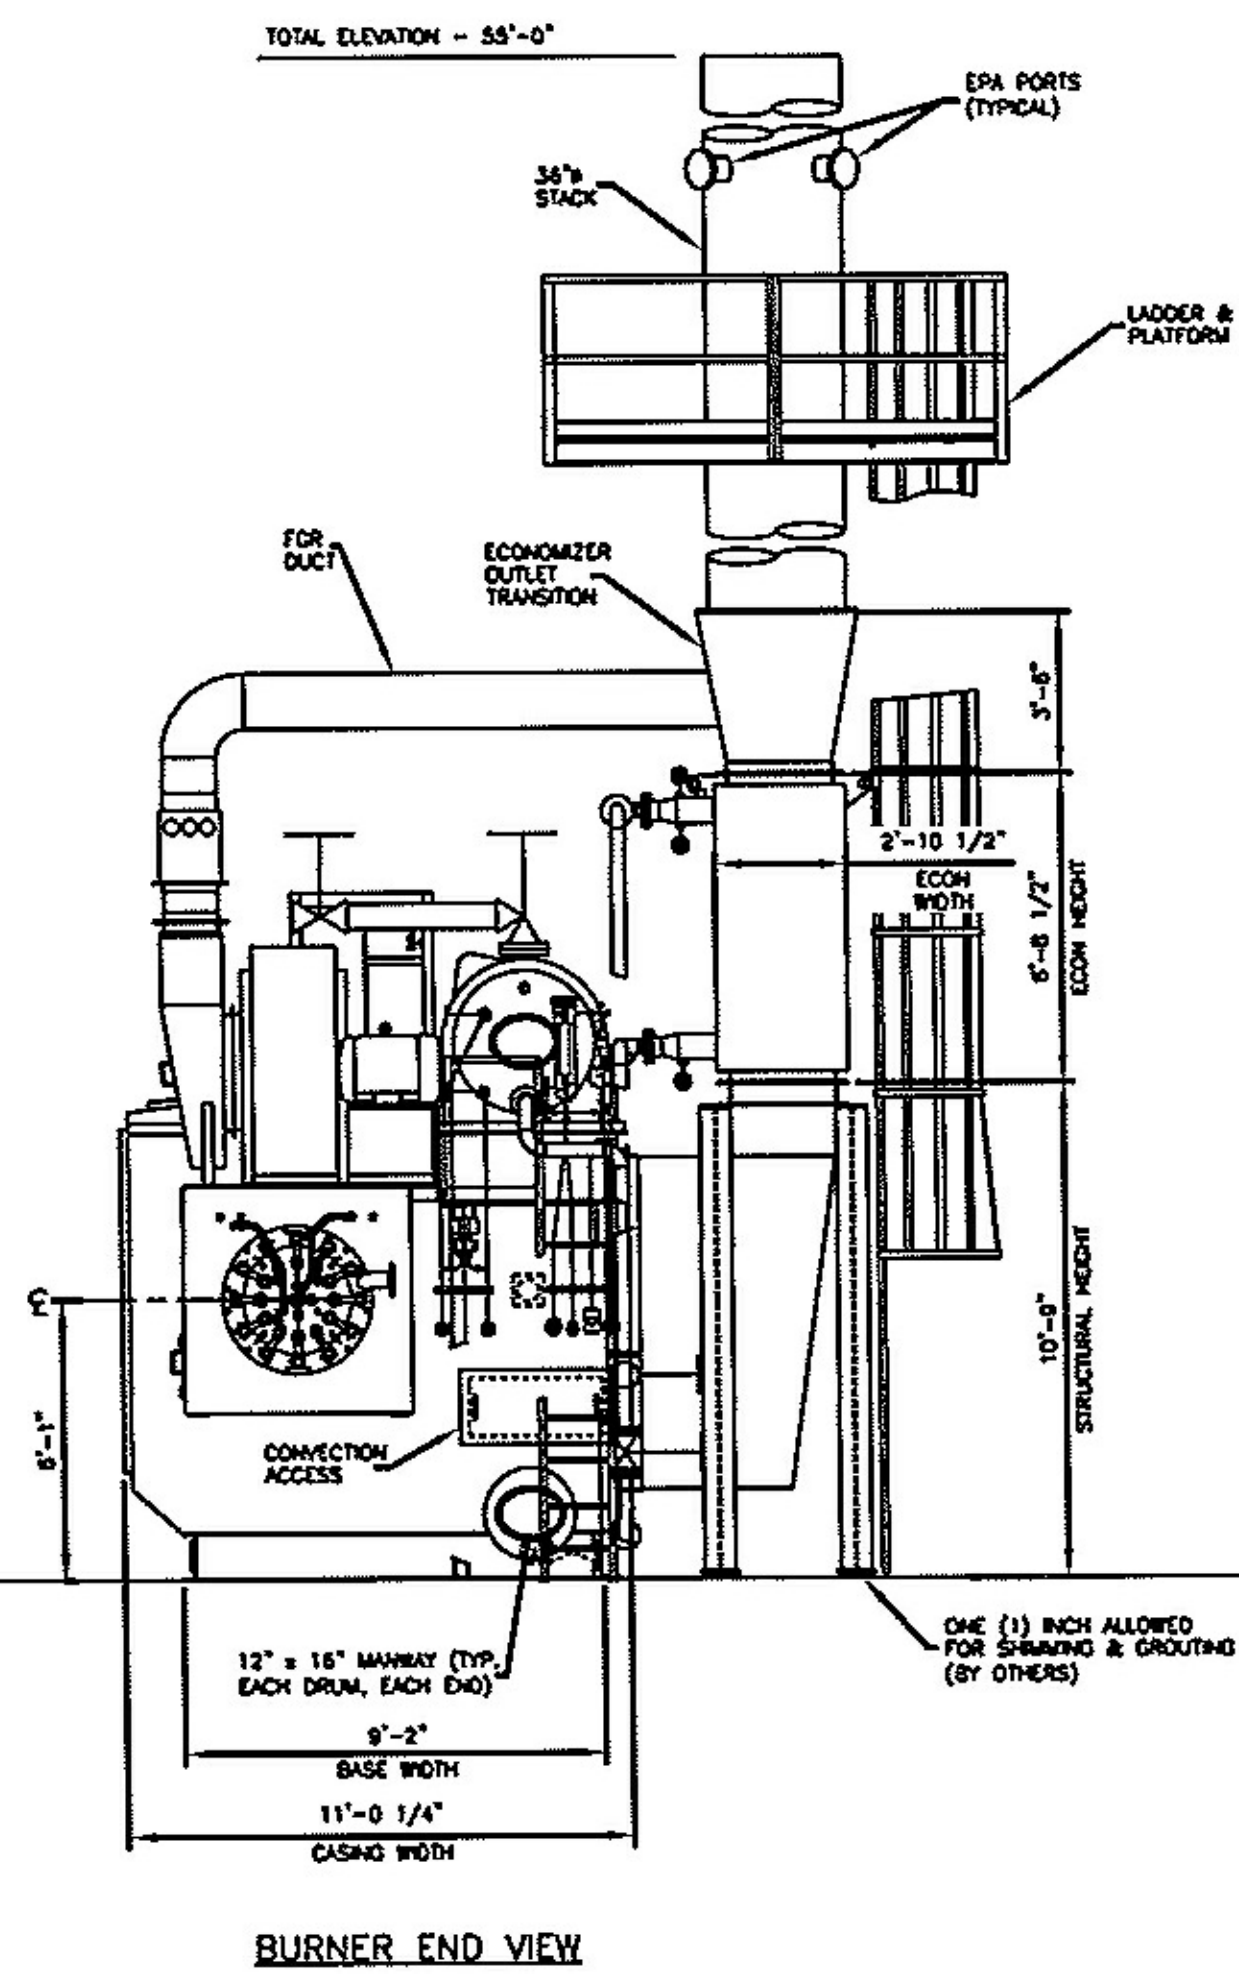

 NEBRASKA BOILER® <i>The power of commitment.™</i>	
GENERAL ARRANGEMENT SERIES: NB-2000-50 W/ECON (H/W-STD)	
SCALE: NONE	DATE: MAY 08, 2008
DRAWN BY: KENB	CHECKED: _____
JOB NO: PROPOSAL	SERIAL NO: _____
QTY: _____	DRAWING NO: N824587

**POWER ENGINEERS
COLLABORATIVE LLC**

150 Sunny Slope Road
Suite 110
Brookfield, Wisconsin 53005
WWW.PECLLC.COM




PÖYRY
PÖYRY (APPLETON) LLC APPLETON, WISCONSIN

middough

Potter Lawson

Project No: 2009.07.00

State of Wisconsin
Department of Administration
Division of State Facilities

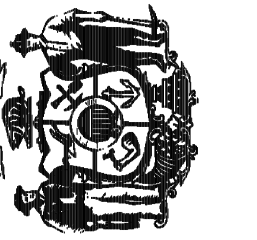

UNIVERSITY OF WISCONSIN SYSTEM

CHARTER STREET REBUILD

MADISON, WI

Unnamed

Revisions:

No.	Date:	By:	Description:
-----	-------	-----	--------------

--	--	--	--

--	--	--	--

--	--	--	--

--	--	--	--

aphic
ele

sale	

SF	09A21
----	-------

Number	007122
--------	--------

et

RR

pe	Fn
----	----

ate	05.24.10
-----	----------

Issued	05-24-10
--------	----------

[illegible]

Boiler

Bolici
